

Exhibit 8

 
 
 
 

Engineering Plans, Maps, and Drawings

J:\CANNONSURG\SHOPS CREEK ROAD AREA\CAD Design\01-69121\DWG.dwg-01 Plotted Mon, 02 Dec 2024 - 10:58am by twaser
J:\CANNONSURG\SHOPS CREEK ROAD AREA\CAD Design\01-69121\DWG.dwg-01, 12/2/2024, 10:58:59 AM, twaser, AutoCAD PDF (General Documentation).pc3

GENERAL LEGEND FOR BOOSTER PUMP STATION

EXISTING	NEW

ASPHALT PAVING	
PAVING OVERLAY	
CONCRETE PAVING	
GRAVEL DRIVE	
ITEMS TO BE DEMOLISHED	
ITEMS TO BE DEMOLISHED/ ABANDONED IN PLACE	

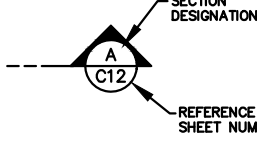STRUCTURES	
	GLASS
	DOOR
	WINDOW
	DOOR/WINDOW IDENTIFICATION
	DOOR/WINDOW IDENTIFICATION
	WATER LEVEL
	GATE/GUIDE IDENTIFICATION
	POLYETHYLENE FILM
	FILTER FABRIC
	SECTION CUT
	ROCK
	EARTH
	CRUSHED STONE
	NEW STRUCTURAL CONCRETE
	EXISTING CONCRETE
	PRECAST CONCRETE
	GROUT 2" THK OR LESS
	GROUT 2" THK OR MORE
	NEW BRICK
	NEW CONC. BLOCK
	NORTH ARROW

LIST OF ABBR

AL.	-	ALUMINUM
ALUM		ALUMINUM SULFATE
APPROX.		ALUMINUM SULFATE
B.FLY		APPROXIMATELY
BFLY		BUTTERFLY VALVE
BY		BUTTERFLY VALVE
CE		BUTTERFLY VALVE
CIRC.		CLARIFIER EFFLUENT
CHK		CIRCULAR
CL		CHECK
CONC.		CLARIFIER INFLUENT
CONT.		CONCRETE
Cu		CONTINUOUS
D		COPPER
CV		CHECK VALVE
DRAIN		DRAIN
DF		DISINFECTANT FEED
DR		DRAIN
DIA.		DIAMETER
DI		DUCTILE IRON
DIMJ		DUCTILE IRON MECHANICAL JOINT
EFF.		ELEVATION
ELEVATION		EFFLUENT
E.F.		EACH FACE
E.S.		EACH SIDE
EX.		EXISTING
FDN.		FOUNDATION
FE		FINAL EFFLUENT
FFE		FINISHED FLOOR ELEVATION
GALV.		GALVANIZED
GV		GATE VALVE
HOPE		HIGH DENSITY POLYETHYLENE
HR		HANDRAIL
HWL		HIGH WATER LEVEL

(OTHER LEGENDS MAY EXIST ON OTHER DRAWINGS WHICH CONTAIN SYMBOLS OR ABBREVIATIONS NOT SHOWN HERE)

VALVES & PIPING (BUILDING PLANS & SECTIONS)

EXISTING OR SCHEMATIC	NEW

NOTE:

EXISTING PIPE FITTINGS TO BE RELOCATED ARE SHOWN AS SINGLE LINE PIPING, DARKER THAN OTHER EXISTING PIPING.

WATER MAIN LEGEND

EXISTING	PROPOSED

BEFORE YOU DIG

The contractor is instructed to call 1-800-752-6007 to reach KY 811, the one-call system for information on the location of existing underground utilities. The call is to be placed a minimum of two (2) and no more than ten (10) business days prior to excavation. The contractor should be aware that owners of underground facilities are not required to be members of the KY 811 one-call Before-U-Dig (BUD) service. The contractor must coordinate excavation with the utility owners, including those whom do not subscribe to KY 811. It may be necessary for the contractor to contact the County Court Clerk to determine what utility companies have facilities in the area.

GENERAL NOTES

- EFFORTS HAVE BEEN MADE TO INDICATE LOCATIONS OF EXISTING STRUCTURES, PIPING AND UTILITIES. HOWEVER, THE CONTRACTOR SHALL FAMILIARIZE HIMSELF WITH THE SITE AND OTHER EXISTING CONDITIONS AND NOTIFY THE ENGINEER OF ANY DISCREPANCIES BETWEEN INFORMATION DEPICTED BY THE CONSTRUCTION DRAWINGS AND ACTUAL FIELD CONDITIONS, WHICH WOULD SIGNIFICANTLY ALTER THE DESIGN INTENT OF CONSTRUCTION DRAWINGS PRIOR TO COMMENCING HIS CONSTRUCTION OPERATIONS. DIMENSIONS OF EXISTING STRUCTURES AND/OR SITE RESTRICTIONS ARE APPROXIMATE. IT IS THE CONTRACTOR'S RESPONSIBILITY TO OBTAIN AND CONFIRM ALL DIMENSIONS AND ELEVATIONS OF EXISTING STRUCTURES AND TOPOGRAPHY IN THE FIELD NECESSARY FOR HIS CONSTRUCTION OPERATION.
- THE CONTRACTOR SHALL USE ALL POSSIBLE CARE DURING EXCAVATION ON THE PROJECT SO AS NOT TO DISTURB OR DAMAGE ANY EXISTING UTILITY OR STRUCTURE NOT SCHEDULED FOR DEMOLITION WHETHER DEPICTED OR NOT IN THE CONSTRUCTION DRAWINGS. ANY DAMAGE TO THE ABOVE MENTIONED ITEMS CAUSED DIRECTLY OR INDIRECTLY BY THE CONTRACTOR SHALL BE REPAIRED OR REPLACED BY THE CONTRACTOR AT NO COST TO THE OWNER TO A CONDITION EQUAL TO THAT WHICH EXISTED PRIOR TO BEING DAMAGED.
- IT IS THE CONTRACTOR'S RESPONSIBILITY TO CONTACT ALL EXISTING UTILITY OWNERS AND HAVE THEM FIELD LOCATE THEIR EXISTING UTILITIES PRIOR TO ANY CONSTRUCTION ACTIVITIES.
- THE CONTRACTOR SHALL CONTACT AND OBTAIN THE PERMISSION OF EXISTING UTILITY OWNERS 48 HOURS (MIN.) PRIOR TO ANY CONSTRUCTION ACTIVITY INTERRUPTING OPERATION OF SAID UTILITY.

KENTUCKY TRANSPORTATION CABINET (KYTC) NOTES


- WATER LINES TO BE CONSTRUCTED WITHIN THE KENTUCKY TRANSPORTATION CABINET RIGHT-OF-WAY. TRENCHES SHALL BE OF A DEPTH SUFFICIENT TO PROVIDE A MINIMUM COVER OF 42" FROM THE GROUND SURFACE TO THE TOP OF THE PIPE AND BE LOCATED APPROXIMATELY AS SHOWN UNLESS OTHERWISE NOTED. SEE INDIVIDUAL SHEETS FOR DETAILS.
- ALL BORES UNDER KYTC RIGHT-OF-WAY SHALL BE A MINIMUM OF 42" DEPTH UNDER BOTTOM OF DITCH LINE TO TOP OF PROPOSED BORE AND/OR CASING PIPE ON BOTH SIDES OF THE HIGHWAY.
- ROCK BLASTING: THERE SHALL BE NO BLASTING WITHIN STATE RIGHT-OF-WAY WITHOUT WRITTEN CONSENT FROM THE KENTUCKY TRANSPORTATION CABINET.
- PROTECTION OF EXISTING PAVING: CARE SHALL BE TAKEN BY THE CONTRACTOR TO AVOID CRACKING OR BREAKING OF THE EXISTING PAVING. ALL DAMAGE TO THE EXISTING PAVING CAUSED BY THE CONTRACTOR'S OPERATION SHALL BE REPAIRED BY THE CONTRACTOR AT NO COST TO THE OWNER. PAVING PROTECTION SHALL BE ACCOMPLISHED BY THE USE OF RUBBER AND STREET PADDED MACHINERY OR OTHER APPROVED EQUIPMENT WELL SUITED FOR THIS TYPE OF CONSTRUCTION.
- BANK AND DITCH PROTECTION EXCAVATION: DURING CONSTRUCTION ALL EMBANKMENTS, REFILLS AND EXCAVATIONS SHALL BE KEPT SHAPED AND DRAINED BY THE CONTRACTOR. DITCHES AND DRAINS ALONG THE HIGHWAYS SHALL BE MAINTAINED IN SUCH A MANNER AS TO DRAIN EFFECTIVELY AT ALL TIMES.
- PRIVATE ENTRANCE ROAD: ALL ROADWAYS AND DRIVEWAYS WITHIN THE WORK LIMITS OF STATE RIGHT-OF-WAYS SHALL BE REFILLED TO THE NATURAL SURFACE OF THE GROUND WITH APPROVED MATERIAL. THE MATERIAL SHALL BE PLACED AND COMPACTED TO A SMOOTHNESS SUITABLE FOR TRAFFIC. THE CONTRACTOR SHALL BE RESPONSIBLE FOR MAINTAINING THESE ROADWAYS UNTIL THE RESTORATION IS APPROVED BY THE ENGINEER. THE CONTRACTOR SHALL NOTE THAT ALL PRIVATE BUSINESS AND RESIDENTS ALONG THE ROUTE OF THE PROPOSED CONSTRUCTION MUST HAVE ACCESS TO THEIR PROPERTIES AT ALL TIMES DURING CONSTRUCTION.
- PROTECTION OF EXISTING DRAINAGE CULVERTS: AT LOCATIONS WHERE THE PROPOSED WATER MAIN IS PARALLEL WITH OR CROSSING AN EXISTING STORM SEWER, THE COST OF RELAYING EXISTING CULVERT PIPES OR THE EXTRA DEPTH REQUIRED TO AVOID THE EXISTING CULVERT IS CONSIDERED INCIDENTAL TO CONSTRUCTION AND IS NOT A PAY ITEM.
- SOME EXISTING UTILITIES HAVE NOT BEEN SHOWN: THE CONTRACTOR SHALL BE RESPONSIBLE FOR LOCATING ALL EXISTING UTILITIES. THE CONTRACTOR SHALL COORDINATE WITH THE REPRESENTATIVES OF THE VARIOUS UTILITIES WHEN WORKING NEAR ANY EXISTING UTILITY. NO ADDITIONAL PAYMENT TO THE CONTRACTOR WILL BE MADE FOR EXTRA DEPTH REQUIRED TO AVOID ANY EXISTING UTILITY.
- FINAL LOCATION OF FLUSHING HYDRANT ASSEMBLIES SHALL BE MADE IN THE FIELD IN CONJUNCTION WITH KYTC PERSONNEL. BREAKAWAY COMPONENTS SHALL BE USED AT NO ADDITIONAL COST TO THE OWNER IF THE FLUSHING HYDRANT ASSEMBLIES CANNOT BE LOCATED OUTSIDE THE CLEAR ZONE.
- PRIOR TO BEGINNING OF WORK ON KENTUCKY TRANSPORTATION RIGHTS-OF-WAY THE CONTRACTOR SHALL HAVE COMPLETED THE KENTUCKY TRANSPORTATION CABINET'S WORK ZONE TRAFFIC CONTROL EMPLOYEE QUALIFICATION PROGRAM. INDIVIDUALS PERFORMING FLAGGING OPERATIONS ON ANY KENTUCKY ROADWAY MUST BE QUALIFIED AND CERTIFIED BY THE KENTUCKY TRANSPORTATION CABINET. INDIVIDUALS WHO PLACE, MONITOR, AND MAINTAIN TRAFFIC CONTROL DEVICES ON PUBLIC ROADWAYS IN KENTUCKY SHALL HAVE SUCCESSFULLY COMPLETED THE WORK ZONE TRAFFIC CONTROL TECHNICIAN PROGRAM. THE CONTRACTOR SHALL ALSO BE RESPONSIBLE FOR PREPARING AND IMPLEMENTING THE TRAFFIC CONTROL PLAN. THE INDIVIDUALS RESPONSIBLE FOR THIS WORK SHALL HAVE SUCCESSFULLY COMPLETED THE WORK ZONE TRAFFIC CONTROL SUPERVISOR PROGRAM. FOR MORE INFORMATION ON THE WORK ZONE TRAFFIC CONTROL EMPLOYEE QUALIFICATION PROGRAM AS PRESENTED BY THE TECHNOLOGY TRANSFER PROGRAM, KENTUCKY TRANSPORTATION CENTER, UNIVERSITY OF KENTUCKY CALL THE CENTER'S TOLL FREE NUMBER 1-800-432-0719 OR CONTACT THE DEPARTMENT OF HIGHWAYS, DISTRICT 9, 822 ELIZAVILLE, FLEMINGSBURG KENTUCKY 41041. PHONE 606-854-2551.
- ALL NEW WATER LINES SHALL BE INSTALLED AT OR BEYOND THE BACK OF THE DITCH LINE. NO VALVES OR LINES SHALL BE INSTALLED IN THE FLOWLINE OF THE DITCH REGARDLESS OF THE DEPTH.
- ALL NEW WATER LINE SHALL BE INSTALLED AROUND ANY KYTC DRAINAGE STRUCTURES AT DISTANCE WHICH WILL NOT INTERFERE WITH MAINTENANCE OPERATIONS. INSTALLING OVER TOP OF DRAINAGE STRUCTURES IS PROHIBITED.
- IN THE EVENT HIGHWAY ENTRANCE PIPES ARE DAMAGED AND OR REMOVED DURING THE CONSTRUCTION PROCESS THEY SHALL BE REPLACED. REPLACEMENT PIPES SHALL HAVE A MINIMUM DIAMETER OF 15 INCHES REGARDLESS OF THE PIPE DIAMETER BEING REPLACED.
- FACILITIES WITHIN THE ROW SHALL BE RESTORED TO THE EQUIVALENT OF THEIR ORIGINAL CONDITION.

NOTE:

PROPERTY INFORMATION IS FOR INFORMATIONAL PURPOSES ONLY. INFORMATION SHOWN IS FROM BOYD COUNTY PVC. NO WARRANTIES, EXPRESSED OR IMPLIED ARE PROVIDED FOR THIS DATE HEREIN, ITS USE OR INTERPRETATION.

NOTE:

HIGH DENSITY POLYETHYLENE DIRECTIONAL DRILLS UNDER STREAMS, CREEKS, DRAINAGE STRUCTURES, ETC., ARE TO BE BID LUMP SUM. DISTANCE/STATION NUMBERS LISTED IS APPROXIMATE HORIZONTAL DISTANCE ONLY. CONTRACTOR IS RESPONSIBLE TO DETERMINE THE ACTUAL LENGTH OF THE DRILL AND PIPE REQUIRED WHICH SHALL BE INCLUDED IN THE LUMP SUM BID COMPLETE, INCLUDING ALL TRANSITION FITTINGS. NO ADDITIONAL PAYMENT WILL BE MADE.

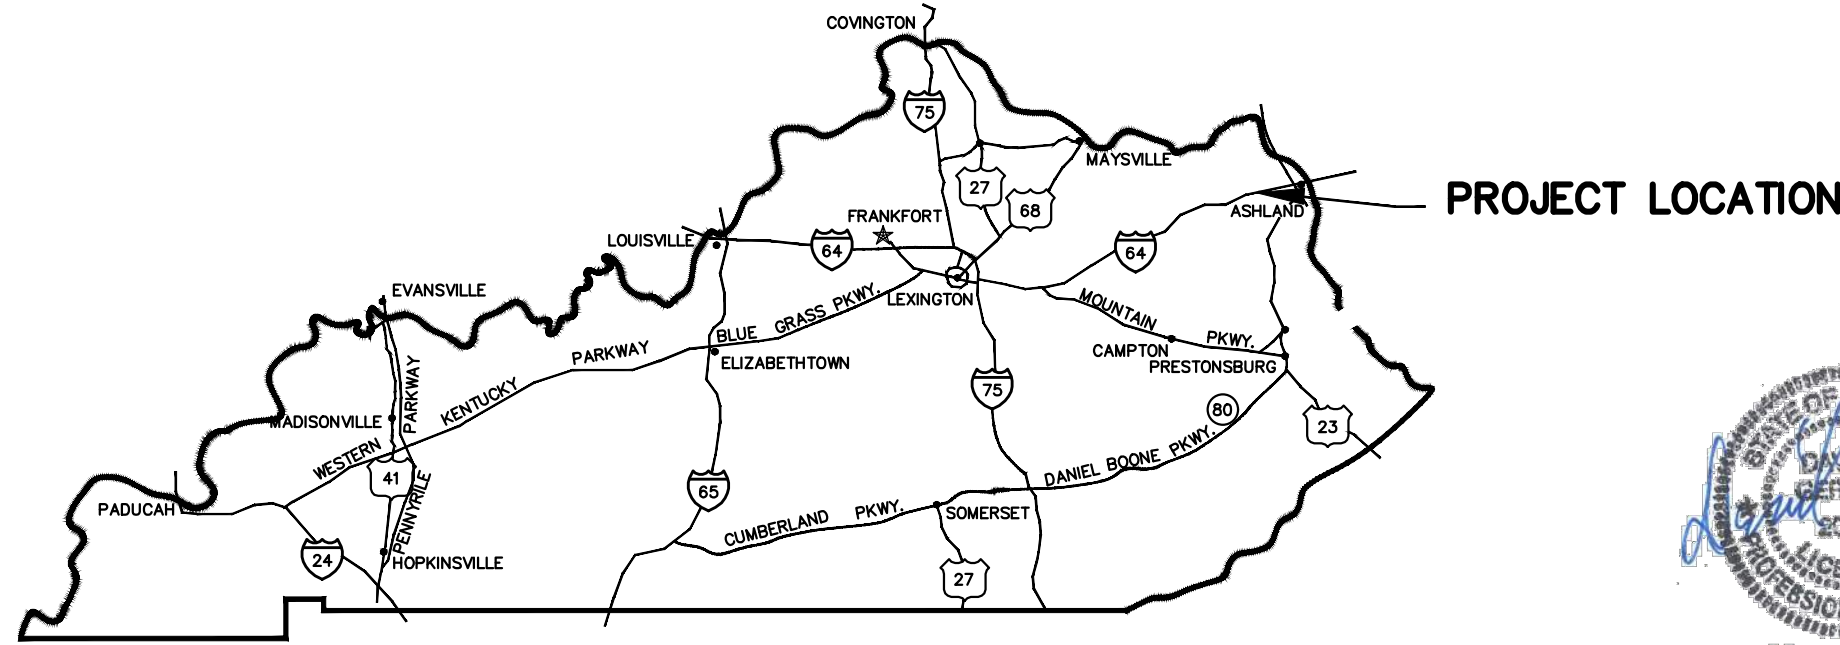


STATE MAP
NOT TO SCALE

DESIGNER	DEG	DATE	BY	REVISION
DRAWN	TEW			
CHECKED	DEG			
APPROVED	DEG			

GRAPHIC SCALE
SCALE: AS NOTED

ALL RIGHTS RESERVED
THIS DOCUMENT IS THE PROPERTY OF BELL ENGINEERING AND SHALL NOT BE REPRODUCED IN WHOLE OR IN PART OR USED FOR CONSTRUCTION OF OTHER THAN THIS SPECIFIC PROJECT WITHOUT THE WRITTEN PERMISSION OF BELL ENGINEERING. FACSIMILES OF LICENSED PROFESSIONAL ENGINEER AND/OR LAND SURVEYOR SEALS, IF AFFIXED TO THIS DOCUMENT, SHALL BE CONSIDERED LEGITIMATE ONLY IF SIGNED AND DATED BY THE REGISTRANT.


Lexington, KY (502) 278-5412
Hopkinsville, KY (270) 886-5466
Somerset, KY (606) 485-4011

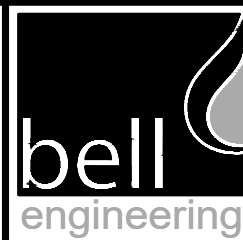

WATER SYSTEM IMPROVEMENTS
SHOPE'S CREEK ROAD AREA
CANNONSBURG WATER DISTRICT
CANNONSBURG, KENTUCKY

PROJECT MAP, GENERAL NOTES & LEGEND

DIVISION	-
CONTRACT NO.	691-21-01
DATE	SEPTEMBER 2021
SHEET NO.	01 OF 17

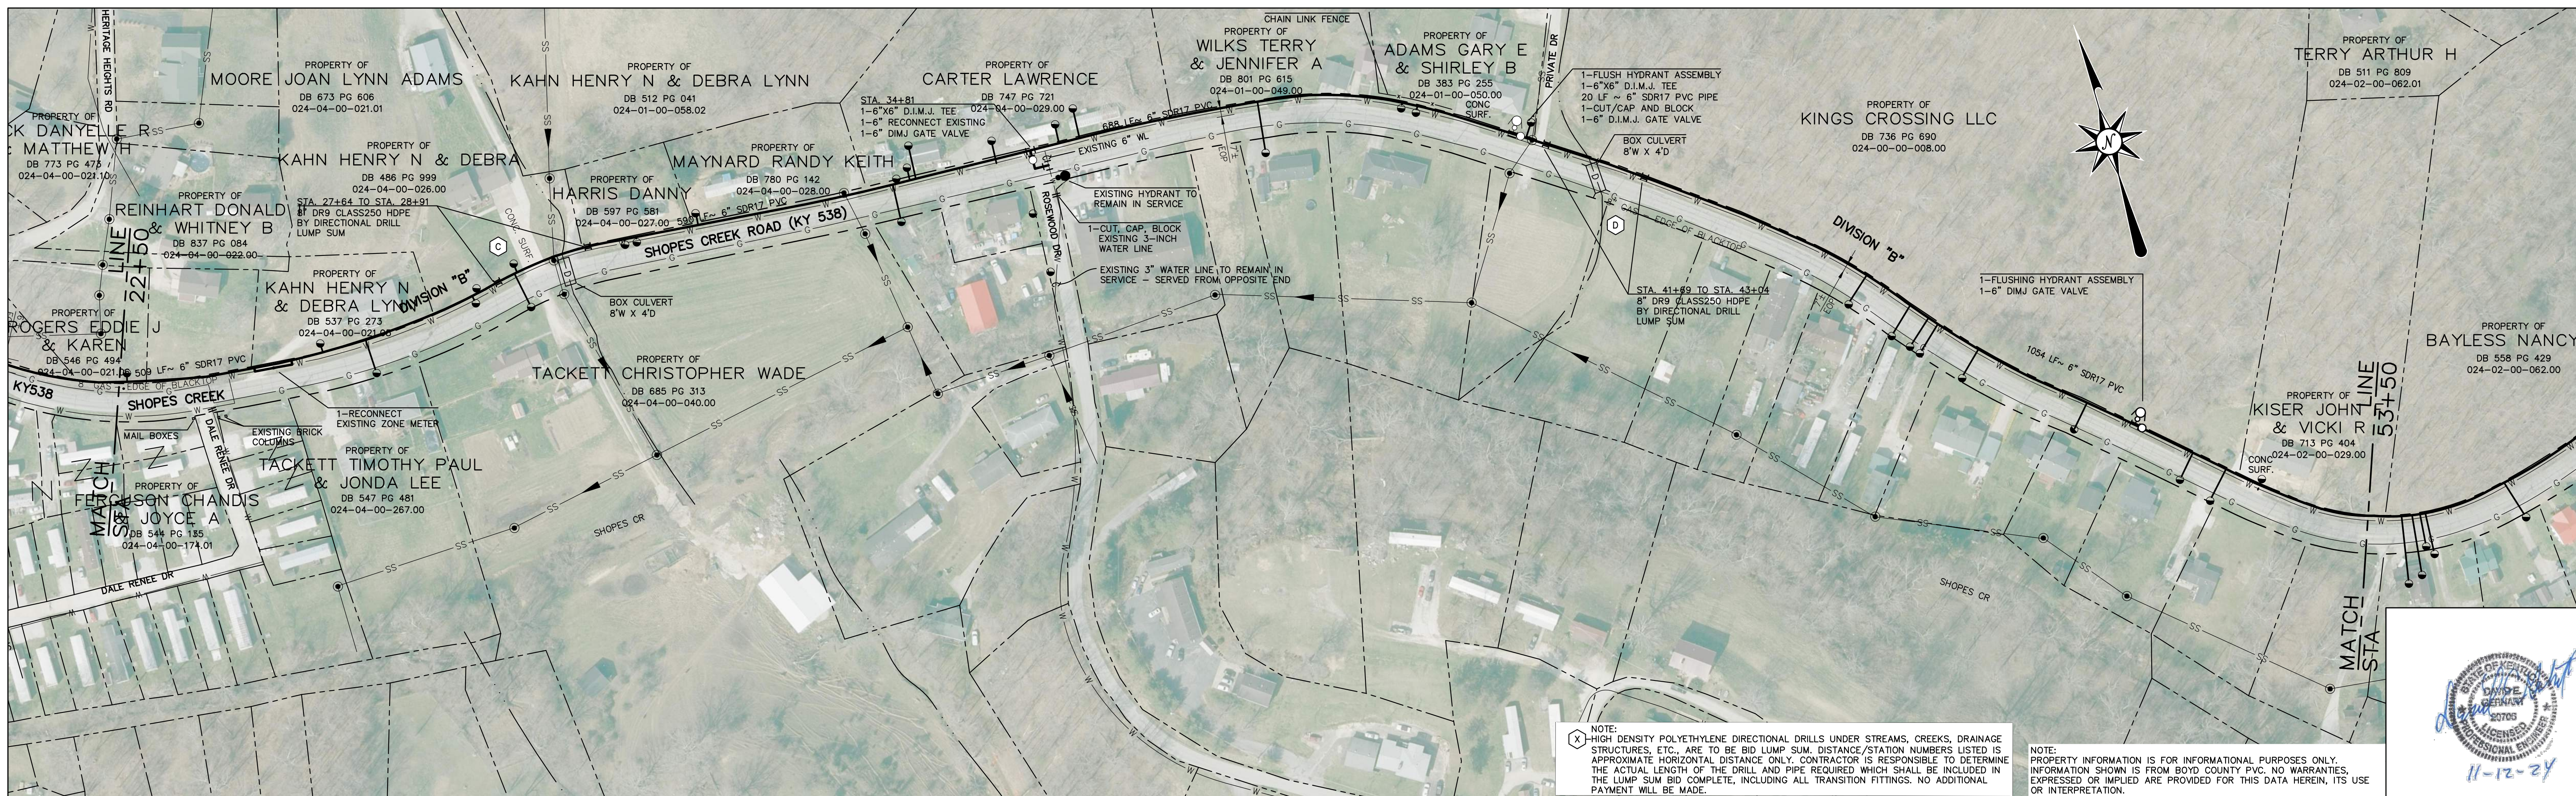


DESIGNER	ELL	DATE	BY	REVISION
DRAWN	CRB			
CHECKED	ELL			
APPROVED	DEG			

GRAPHIC SCALE

SCALE: 1" = 100'

THIS WORK DOES NOT REPRESENT A BOUNDARY SURVEY

ALL RIGHTS RESERVED THIS DOCUMENT IS THE PROPERTY OF BELL ENGINEERING AND SHALL NOT BE REPRODUCED IN WHOLE OR IN PART OR USED FOR CONSTRUCTION OF OTHER THAN THIS SPECIFIC PROJECT WITHOUT THE WRITTEN PERMISSION OF BELL ENGINEERING. FACSIMILES OF LICENSED PROFESSIONAL ENGINEER AND/OR LAND SURVEYOR SEALS, IF AFFIXED TO THIS DOCUMENT, SHALL BE CONSIDERED LEGITIMATE ONLY IF SIGNED AND DATED BY THE REGISTRANT.

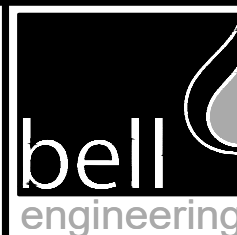


Lexington, KY (859) 278-5412
Hopkinsville, KY (270) 886-5466
Somerset, KY (606) 485-4011

WATER SYSTEM IMPROVEMENTS
SHOPE'S CREEK ROAD AREA
CANNONBURG WATER DISTRICT
CANNONBURG, KENTUCKY

ALONG KY 638 MIDLAND TRAIL ROAD
AND KY 538 SHOPES CREEK ROAD


DIVISION	"A" & "B"		
CONTRACT NO.	691-21-01		
DATE	SEPTEMBER 2021		
SHEET NO.	02	OF	17

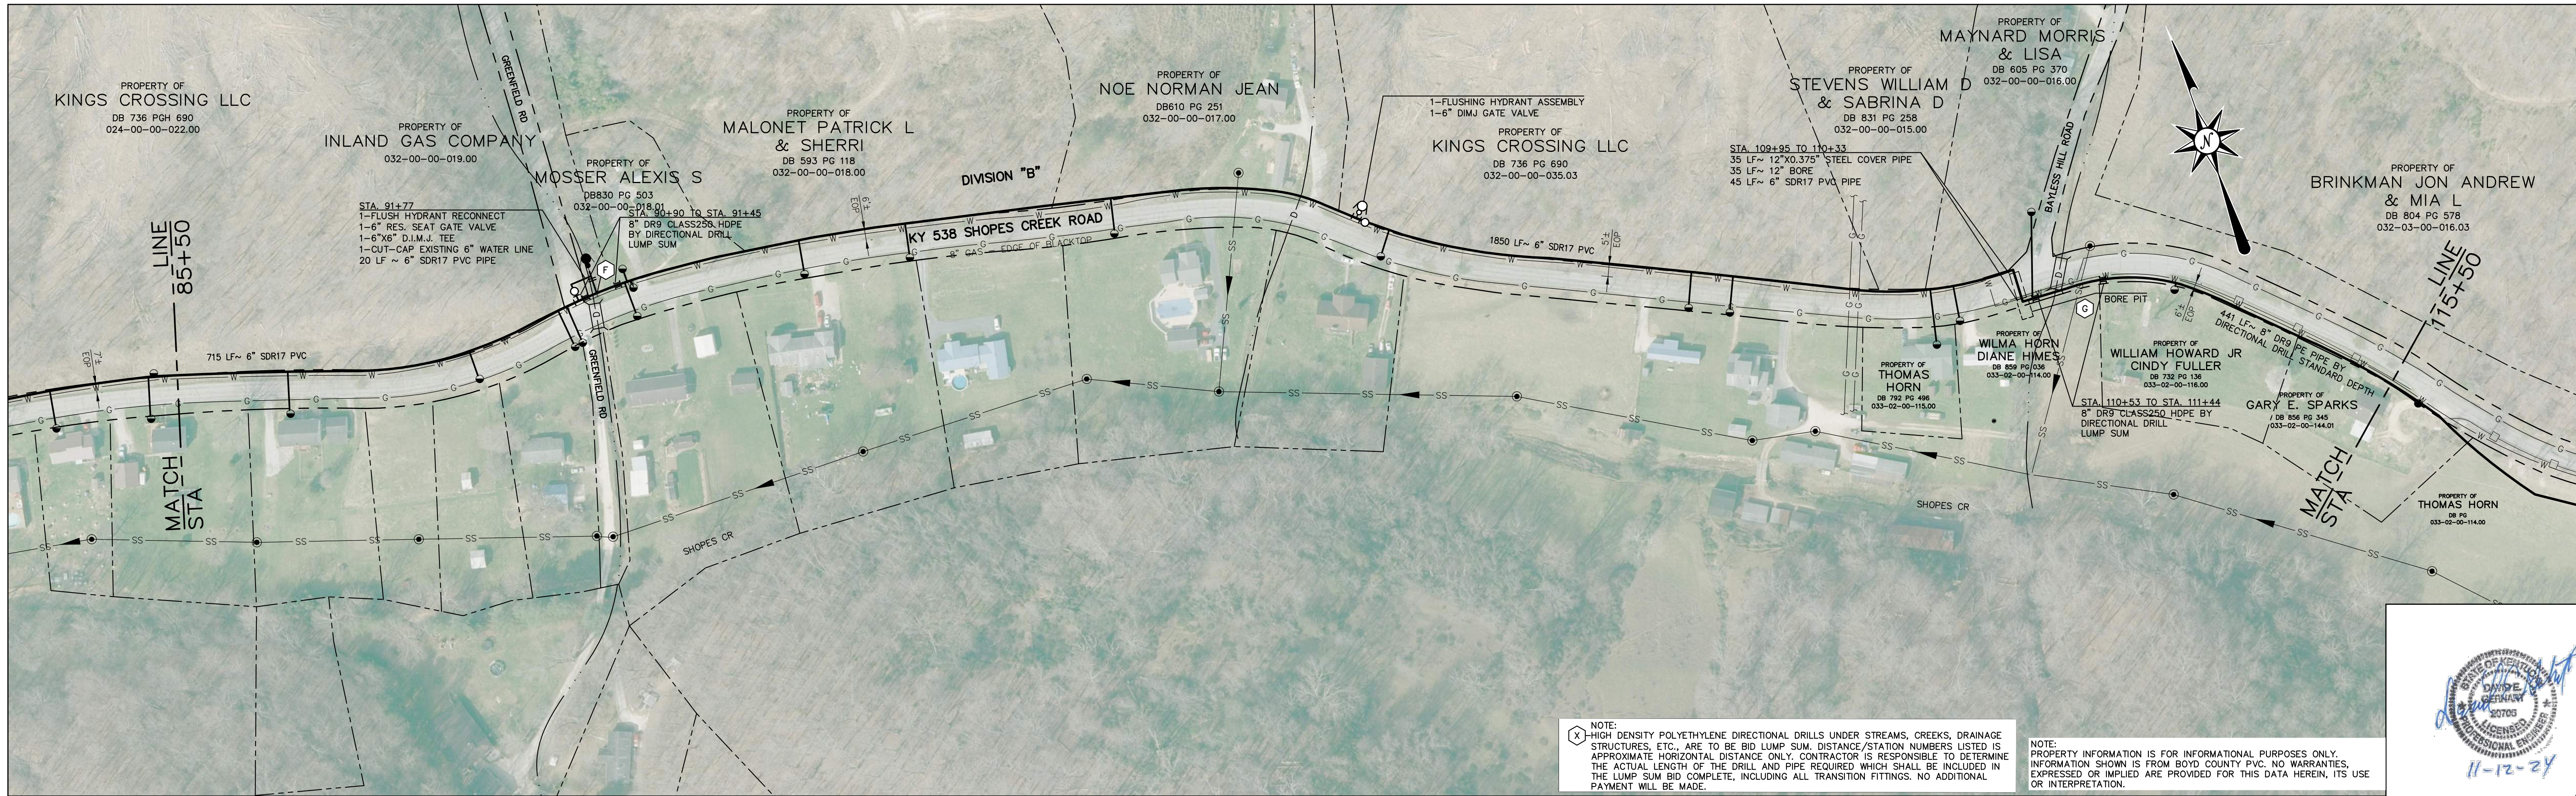


THIS WORK DOES NOT REPRESENT A BOUNDARY SURVEY.

NOTE:
X HIGH DENSITY POLYETHYLENE DIRECTIONAL DRILLS UNDER STREAMS, CREEKS, DRAINAGE STRUCTURES, ETC., ARE TO BE BID LUMP SUM. DISTANCE/STATION NUMBERS LISTED IS APPROXIMATE HORIZONTAL DISTANCE ONLY. CONTRACTOR IS RESPONSIBLE TO DETERMINE THE ACTUAL LENGTH OF THE DRILL AND PIPE REQUIRED WHICH SHALL BE INCLUDED IN THE LUMP SUM BID COMPLETE, INCLUDING ALL TRANSITION FITTINGS. NO ADDITIONAL PAYMENT WILL BE MADE.


NOTE:
PROPERTY INFORMATION IS FOR INFORMATIONAL PURPOSES ONLY. INFORMATION SHOWN IS FROM BOYD COUNTY PVC. NO WARRANTIES, EXPRESSED OR IMPLIED ARE PROVIDED FOR THIS DATA HEREIN, ITS USE OR INTERPRETATION.

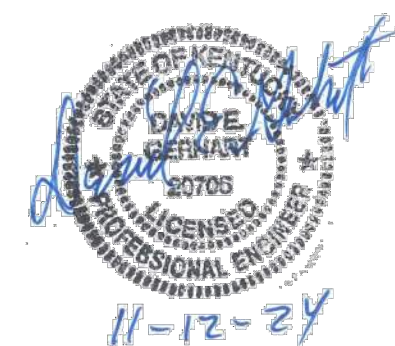

DESIGNER	ELL	DATE		BY		REVISION	
DRAWN	CRB						
CHECKED	ELL						
APPROVED	DEG						

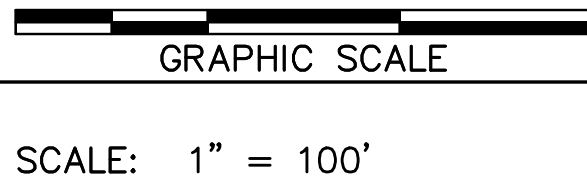

ALL RIGHTS RESERVED
THIS DOCUMENT IS THE PROPERTY OF BELL ENGINEERING AND SHALL NOT BE REPRODUCED IN WHOLE OR IN PART OR USED FOR CONSTRUCTION OF OTHER THAN THIS SPECIFIC PROJECT WITHOUT THE WRITTEN PERMISSION OF BELL ENGINEERING. FACSIMILES OF LICENSED PROFESSIONAL ENGINEER AND/OR LAND SURVEYOR SEALS, IF AFFIXED TO THIS DOCUMENT, SHALL BE CONSIDERED ULTIMATE ONLY IF SIGNED AND DATED BY THE REGISTRANT.


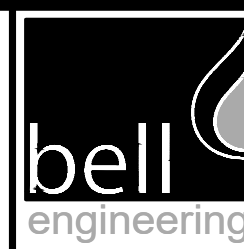


Lexington, KY (859) 278-5412
Hopkinsville, KY (270) 886-5466
Somerset, KY (606) 485-4011

WATER SYSTEM IMPROVEMENTS
SHOPPES CREEK ROAD AREA
CANNONSBURG WATER DISTRICT
CANNONSBURG, KENTUCKY


ALONG KY 538 SHOPPES CREEK ROAD

DIVISION	"B"
CONTRACT NO.	691-21-01
DATE	SEPTEMBER 2021
SHEET NO.	03 OF 17

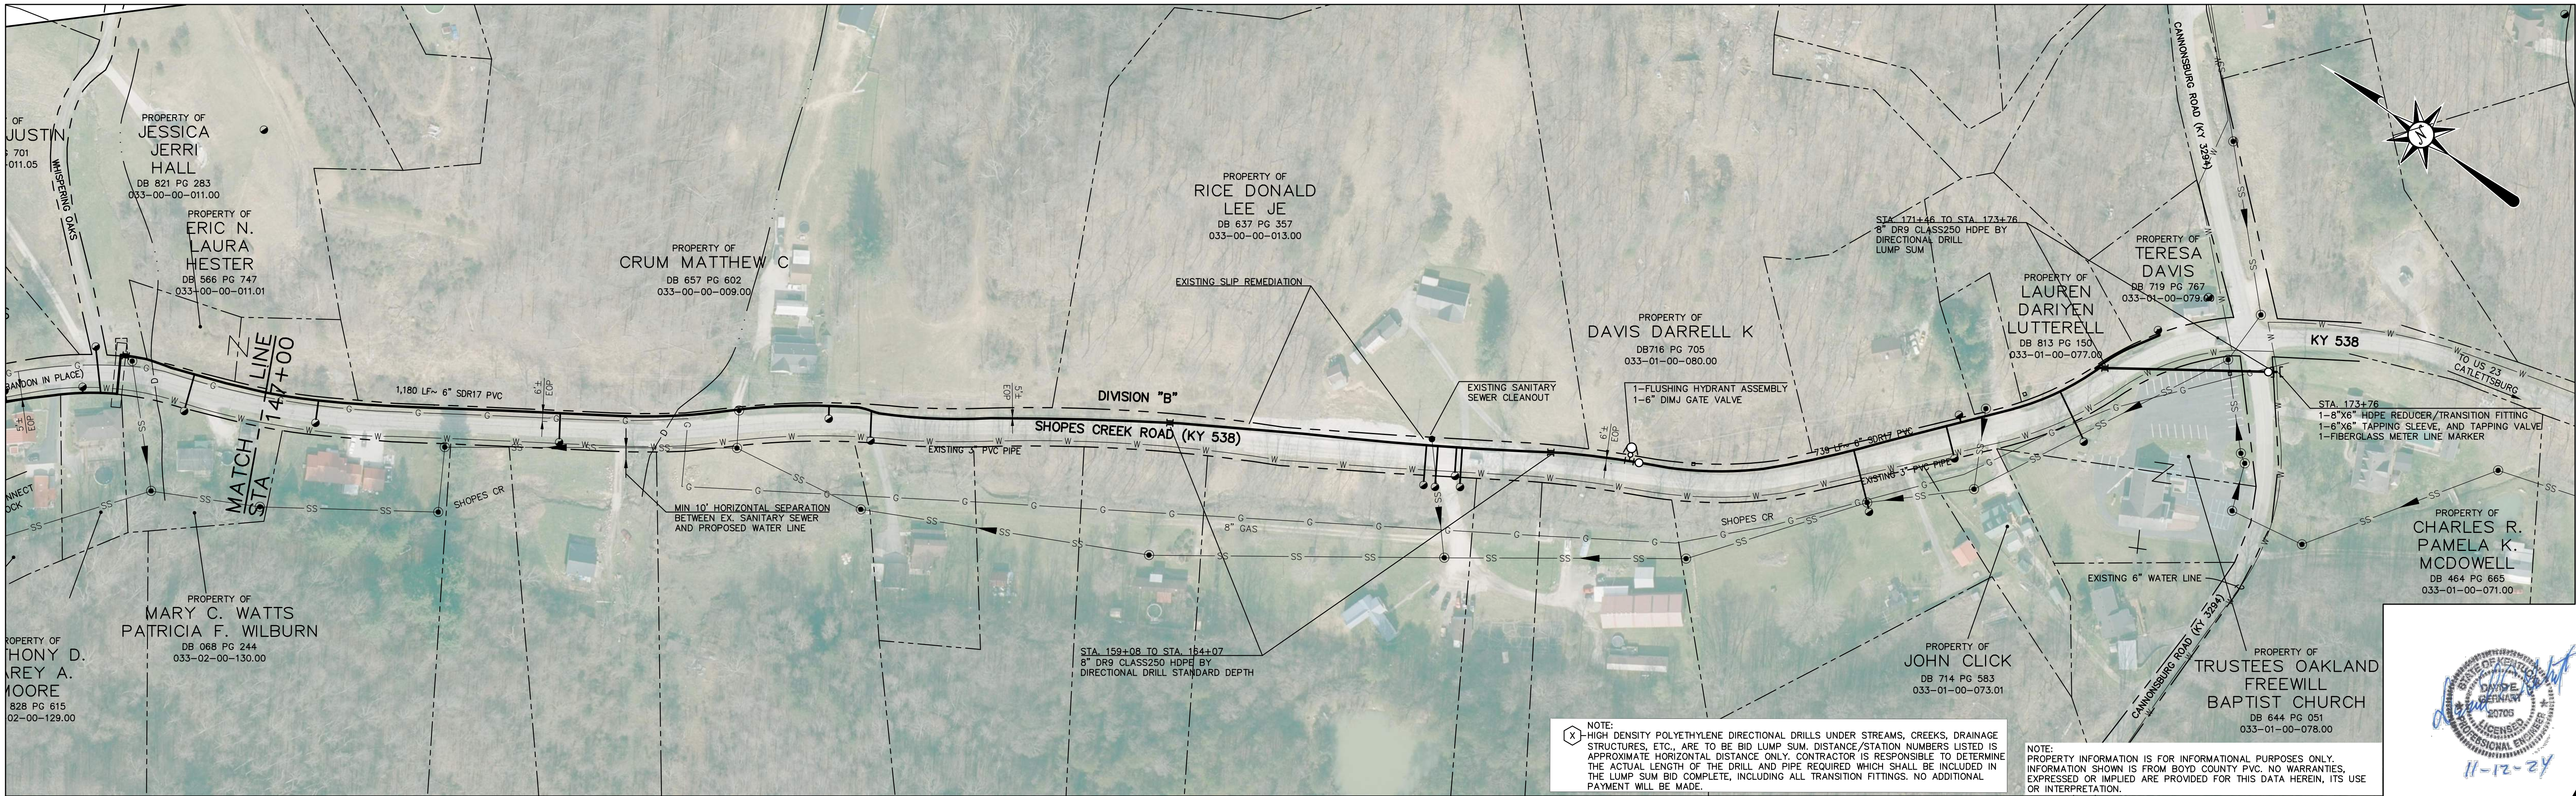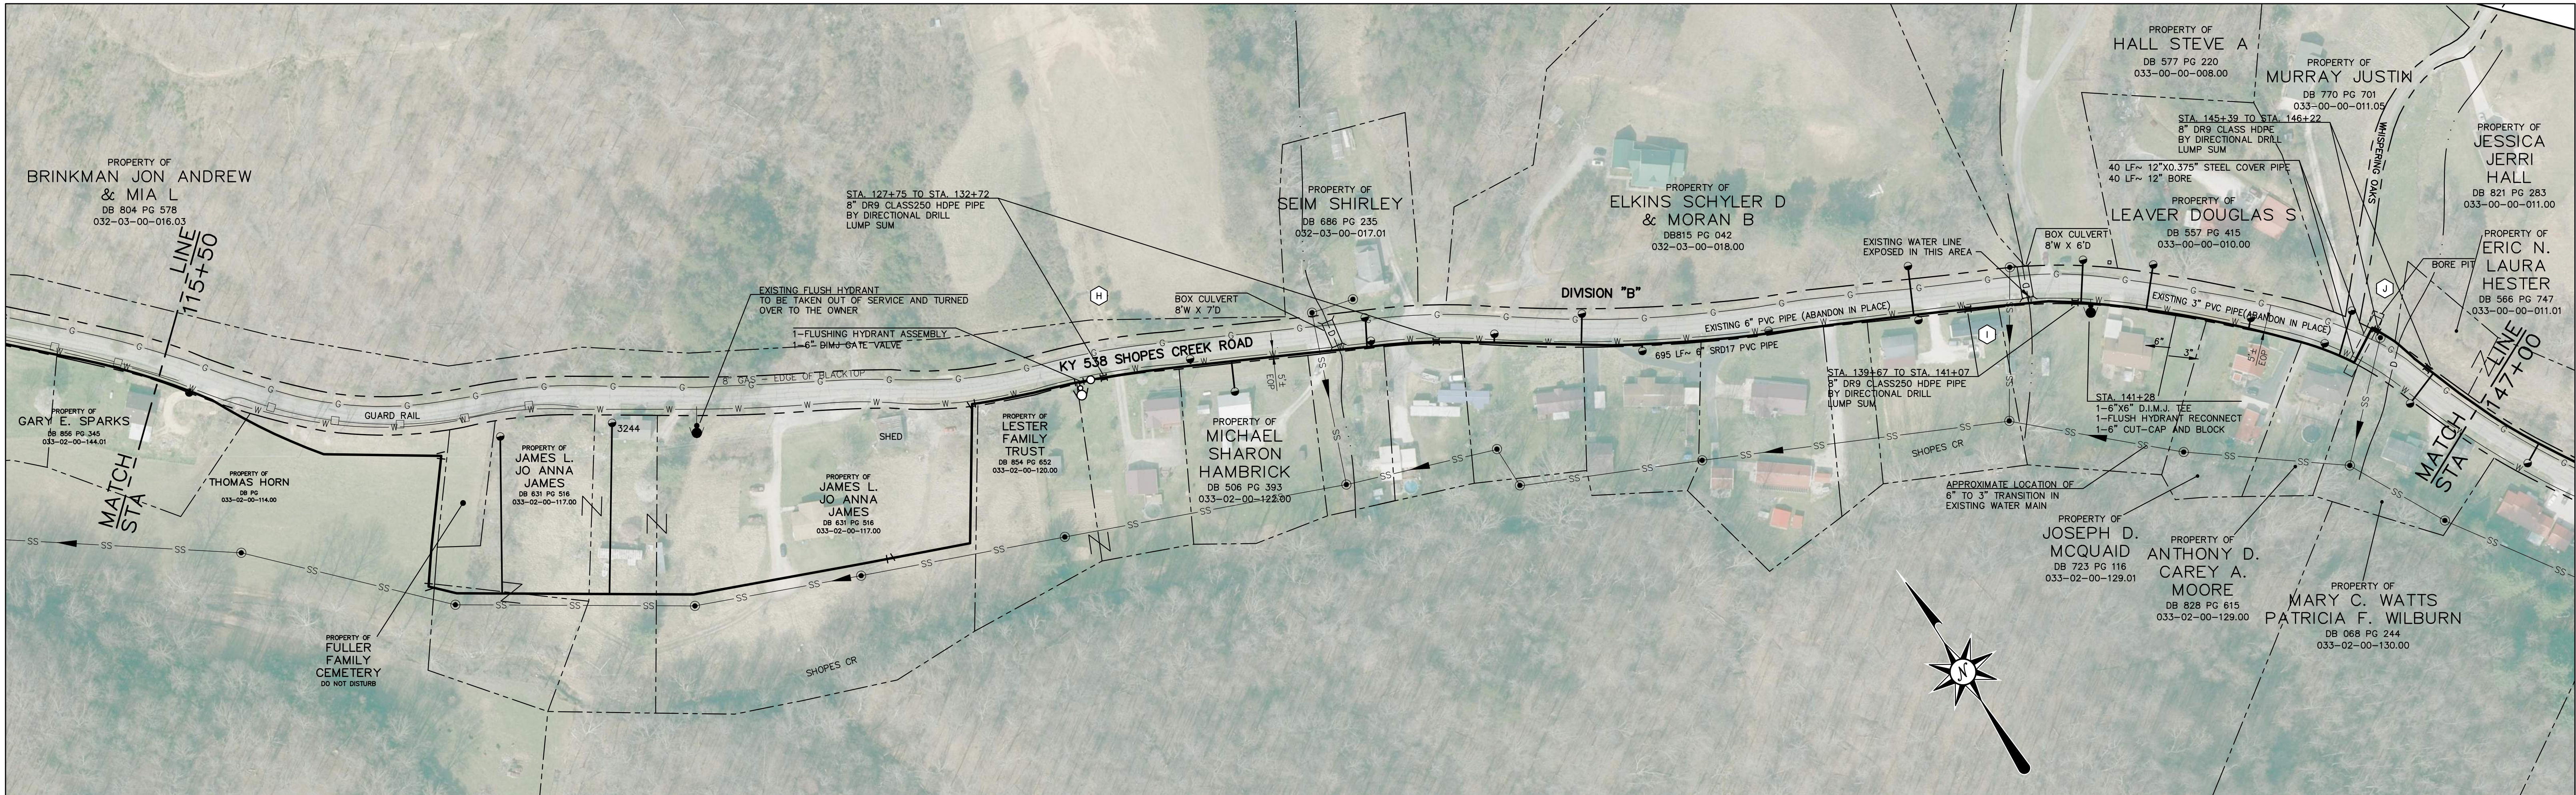


THIS WORK DOES NOT REPRESENT A BOUNDARY SURVEY.

DESIGNER	ELL	DATE	BY	REVISION
DRAWN	CRB			
CHECKED	ELL			
APPROVED	DEG			

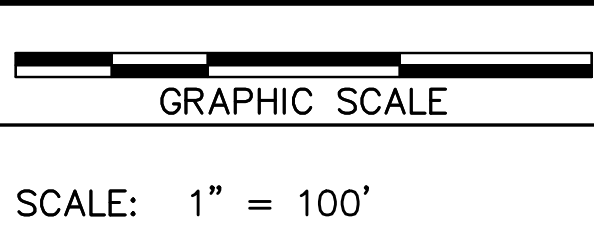

ALL RIGHTS RESERVED
THIS DOCUMENT IS THE PROPERTY OF BELL ENGINEERING AND SHALL NOT BE REPRODUCED IN WHOLE OR IN PART OR USED FOR CONSTRUCTION OF OTHER THAN THIS SPECIFIC PROJECT WITHOUT THE WRITTEN PERMISSION OF BELL ENGINEERING. FACSIMILES OF LICENSED PROFESSIONAL ENGINEER AND/OR LAND SURVEYOR SEALS, IF AFFIXED TO THIS DOCUMENT, SHALL BE CONSIDERED ULTIMATE ONLY IF SIGNED AND DATED BY THE REGISTRANT.

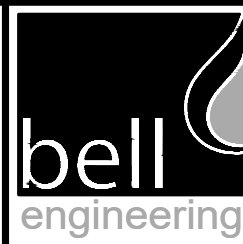


Lexington, KY (859) 278-5412
Hopkinsville, KY (270) 886-5466
Somerset, KY (606) 485-4011

WATER SYSTEM IMPROVEMENTS
SHOPE CREEK ROAD AREA
CANNONBURG WATER DISTRICT
CANNONBURG, KENTUCKY

ALONG KY 538 SHOPE CREEK ROAD


DIVISION	"B"
CONTRACT NO.	691-21-01
DATE	SEPTEMBER 2021
SHEET NO.	04 OF 17

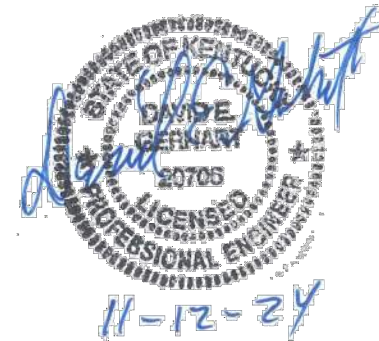


THE WORK SHOWN ON THESE PLANS WAS CREATED FOR CANNONBURG WATER DISTRICT TO SHOW AN APPROXIMATE SITE LOCATION FOR INFORMATIONAL PURPOSES ONLY. THE PLANS SHOW COMPILED INFORMATION FROM THE BOYD COUNTY PVA AND CANNONBURG WATER DISTRICT. THE WORK PERFORMED ON THIS DOCUMENT DOES NOT REPRESENT A BOUNDARY SURVEY.




NOTE:
PROPERTY INFORMATION IS FOR INFORMATIONAL PURPOSES ONLY.
INFORMATION SHOWN IS FROM BOYD COUNTY P.V.C. NO WARRANTIES,
EXPRESSED OR IMPLIED ARE PROVIDED FOR THIS DATA HEREIN, ITS USE
OR INTERPRETATION.

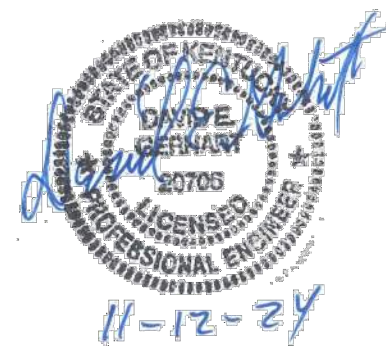

DESIGNER	ELL	DATE		BY		REVISION	
DRAWN	CRB						
CHECKED	ELL						
APPROVED	DEG						

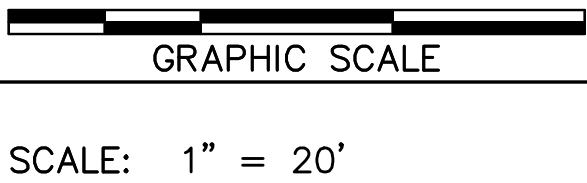

THIS DOCUMENT IS THE PROPERTY OF BELL ENGINEERING AND SHALL NOT BE REPRODUCED IN WHOLE OR IN PART OR USED FOR CONSTRUCTION OF OTHER THAN THIS SPECIFIC PROJECT WITHOUT THE WRITTEN PERMISSION OF BELL ENGINEERING. FACSIMILES OF LICENSED PROFESSIONAL ENGINEER AND/OR LAND SURVEYOR SEALS, IF AFFIXED TO THIS DOCUMENT, SHALL BE CONSIDERED UTTIMATE ONLY IF SIGNED AND DATED BY THE REGISTRANT.

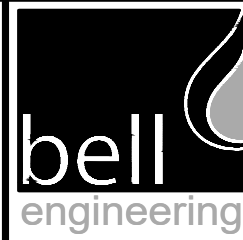

Lexington, KY (859) 278-5412
Hopkinsville, KY (270) 886-5466
Somerset, KY (606) 485-4011

WATER SYSTEM IMPROVEMENTS
SHOPS CREEK ROAD AREA
CANNONBURG WATER DISTRICT
CANNONBURG, KENTUCKY

DEMO SHEET ALONG KY 638 MIDLAND
TRAIL ROAD AND KY 538 SHOPS CREEK
ROAD


DIVISION	-
CONTRACT NO.	691-21-01
DATE	SEPTEMBER 2021
SHEET NO.	05 OF 17



THIS WORK DOES NOT REPRESENT A BOUNDARY SURVEY.

ALL RIGHTS RESERVED

THIS DOCUMENT IS THE PROPERTY OF BELL ENGINEERING AND SHALL NOT BE REPRODUCED IN WHOLE OR IN PART OR USED FOR CONSTRUCTION OF OTHER THAN THIS SPECIFIC PROJECT WITHOUT THE WRITTEN PERMISSION OF BELL ENGINEERING. FACSIMILES OF LICENSED PROFESSIONAL ENGINEER AND/OR LAND SURVEYOR SEALS, IF AFFIXED TO THIS DOCUMENT, SHALL BE CONSIDERED LEGITIMATE ONLY IF SIGNED AND DATED BY THE REGISTRANT.

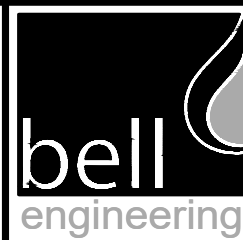


Lexington, KY (859) 278-5412
Hopkinsville, KY (270) 886-5466
Somerset, KY (606) 485-4011


WATER SYSTEM IMPROVEMENTS
SHOPES CREEK ROAD AREA
CANNONSURG WATER DISTRICT
CANNONSURG, KENTUCKY

PROPOSED PUMP STATION, MASTER
METER, BOOSTER CHLORINATOR, AND
ZONE METER
KY 638 MIDLAND TRAIL








NOTE:
PROPERTY INFORMATION IS FOR INFORMATIONAL PURPOSES ONLY.
INFORMATION SHOWN IS FROM BOYD COUNTY PVC. NO WARRANTIES,
EXPRESSED OR IMPLIED ARE PROVIDED FOR THIS DATA HEREIN, ITS USE
OR INTERPRETATION.

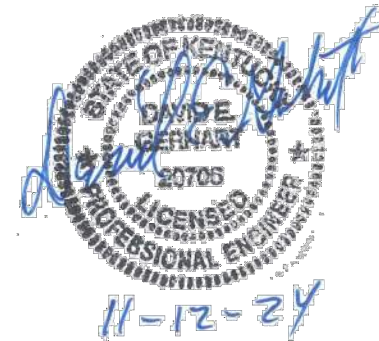


DESIGNER	DEG	DATE	BY	REVISION
DRAWN	TEW			
CHECKED	DEG			
APPROVED	DEG			

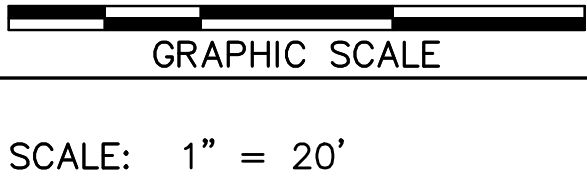

DIVISION	-
CONTRACT NO.	691-21-01
DATE	SEPTEMBER 2021
SHEET NO.	06 OF 17

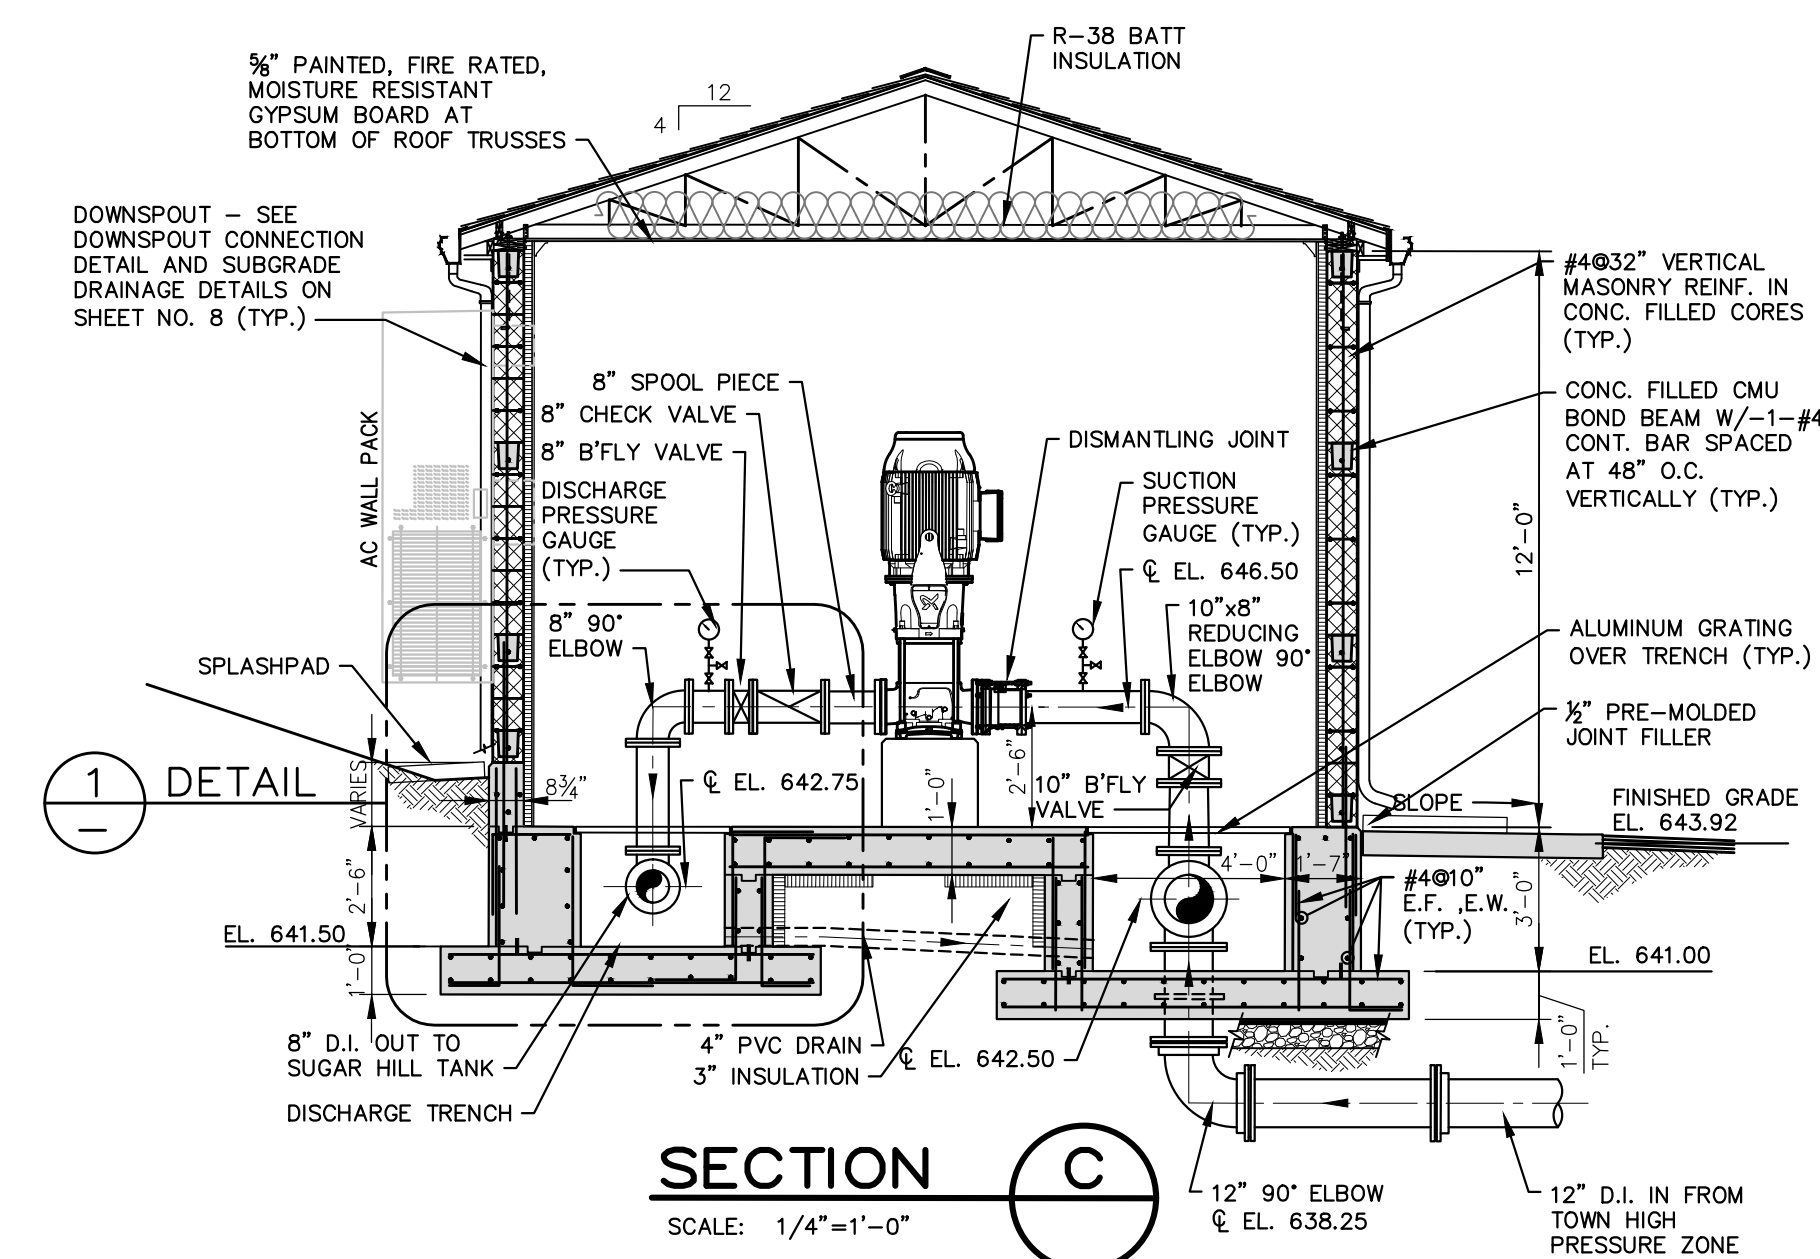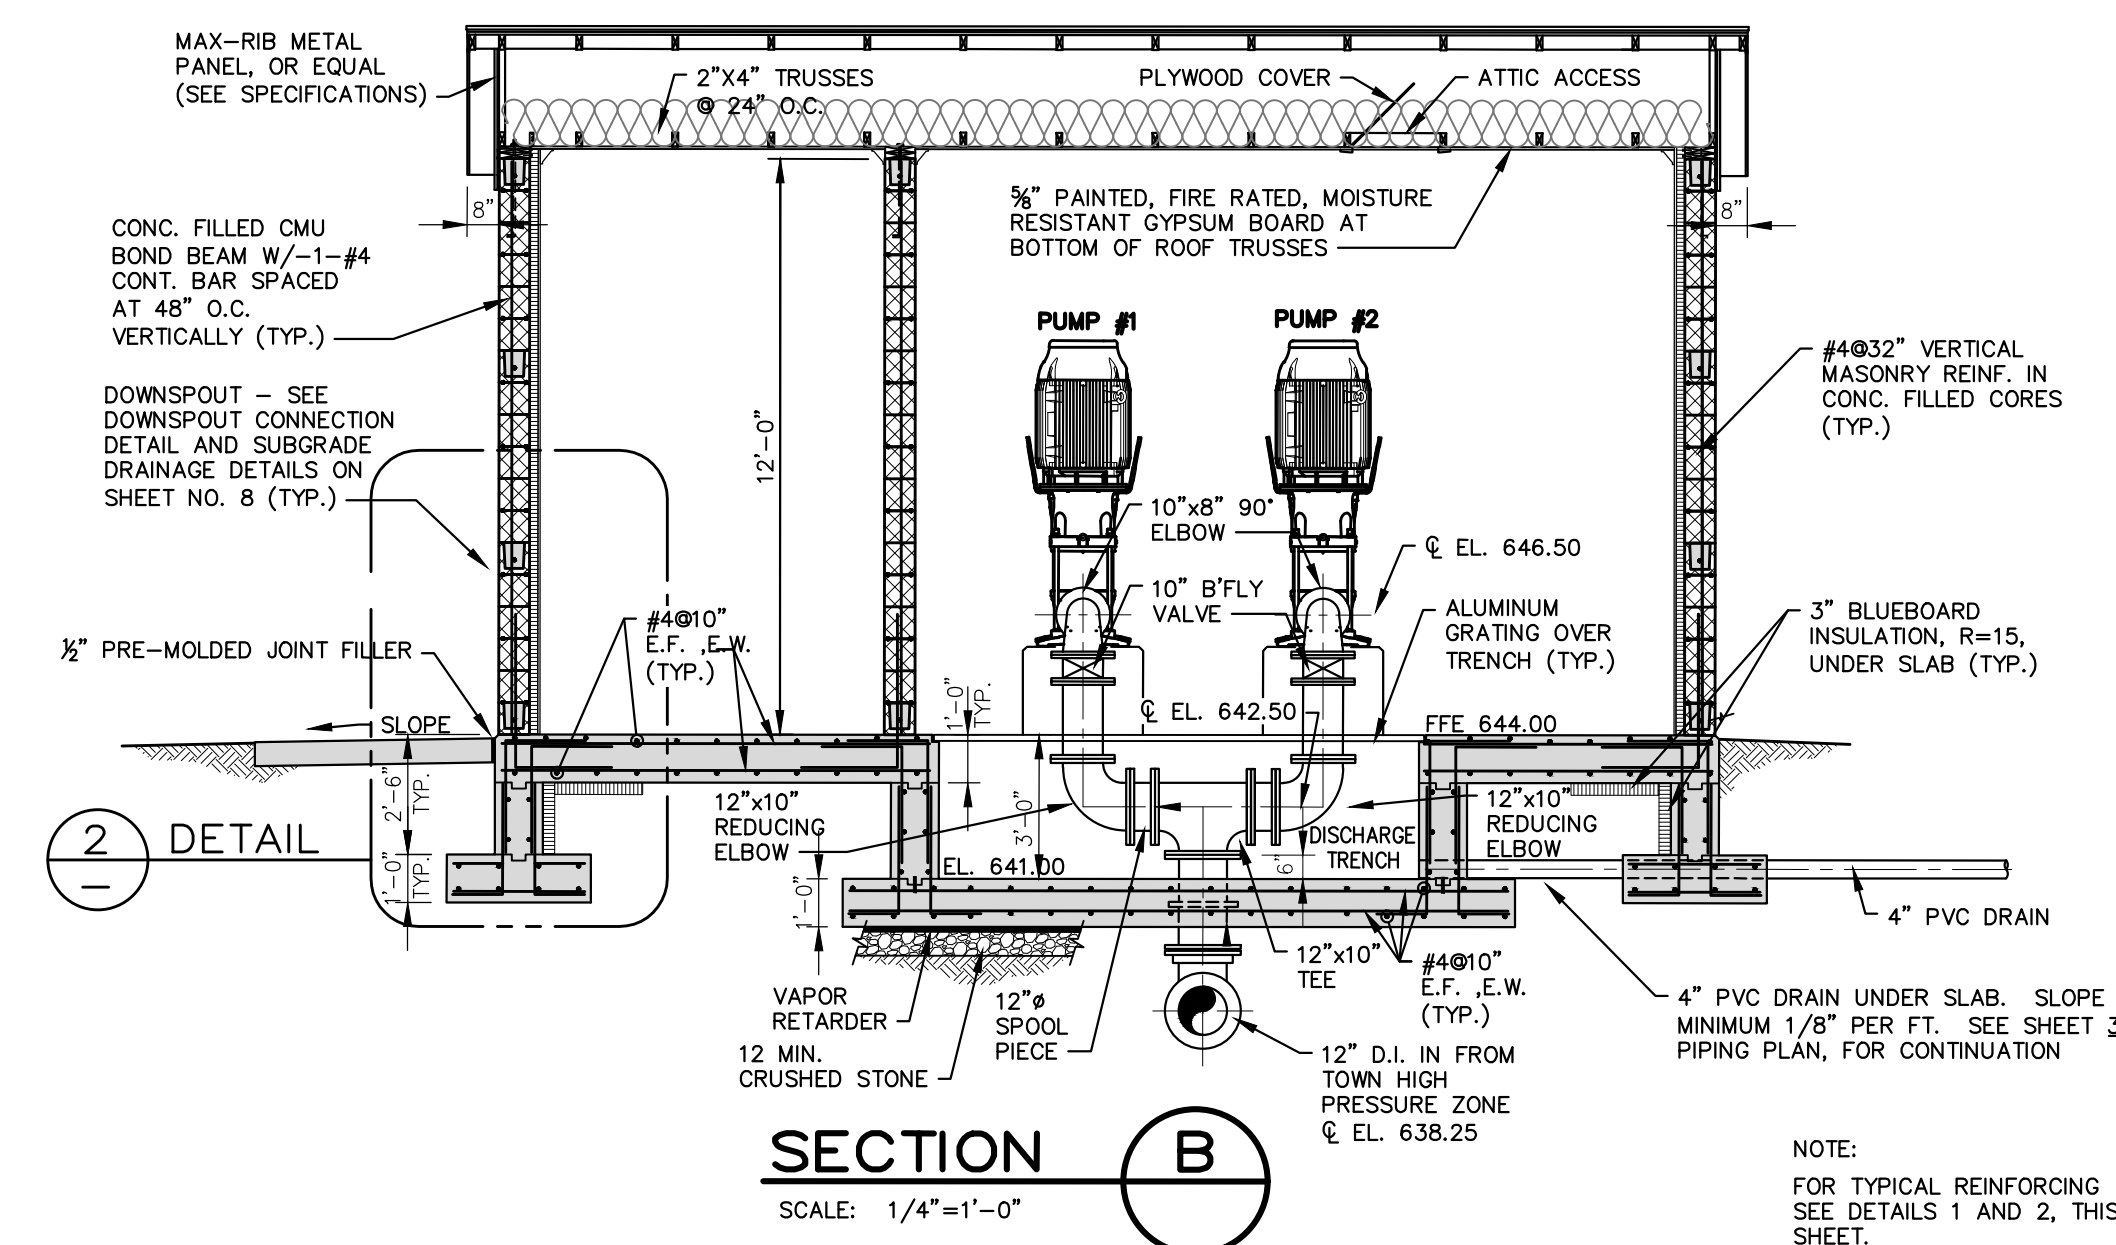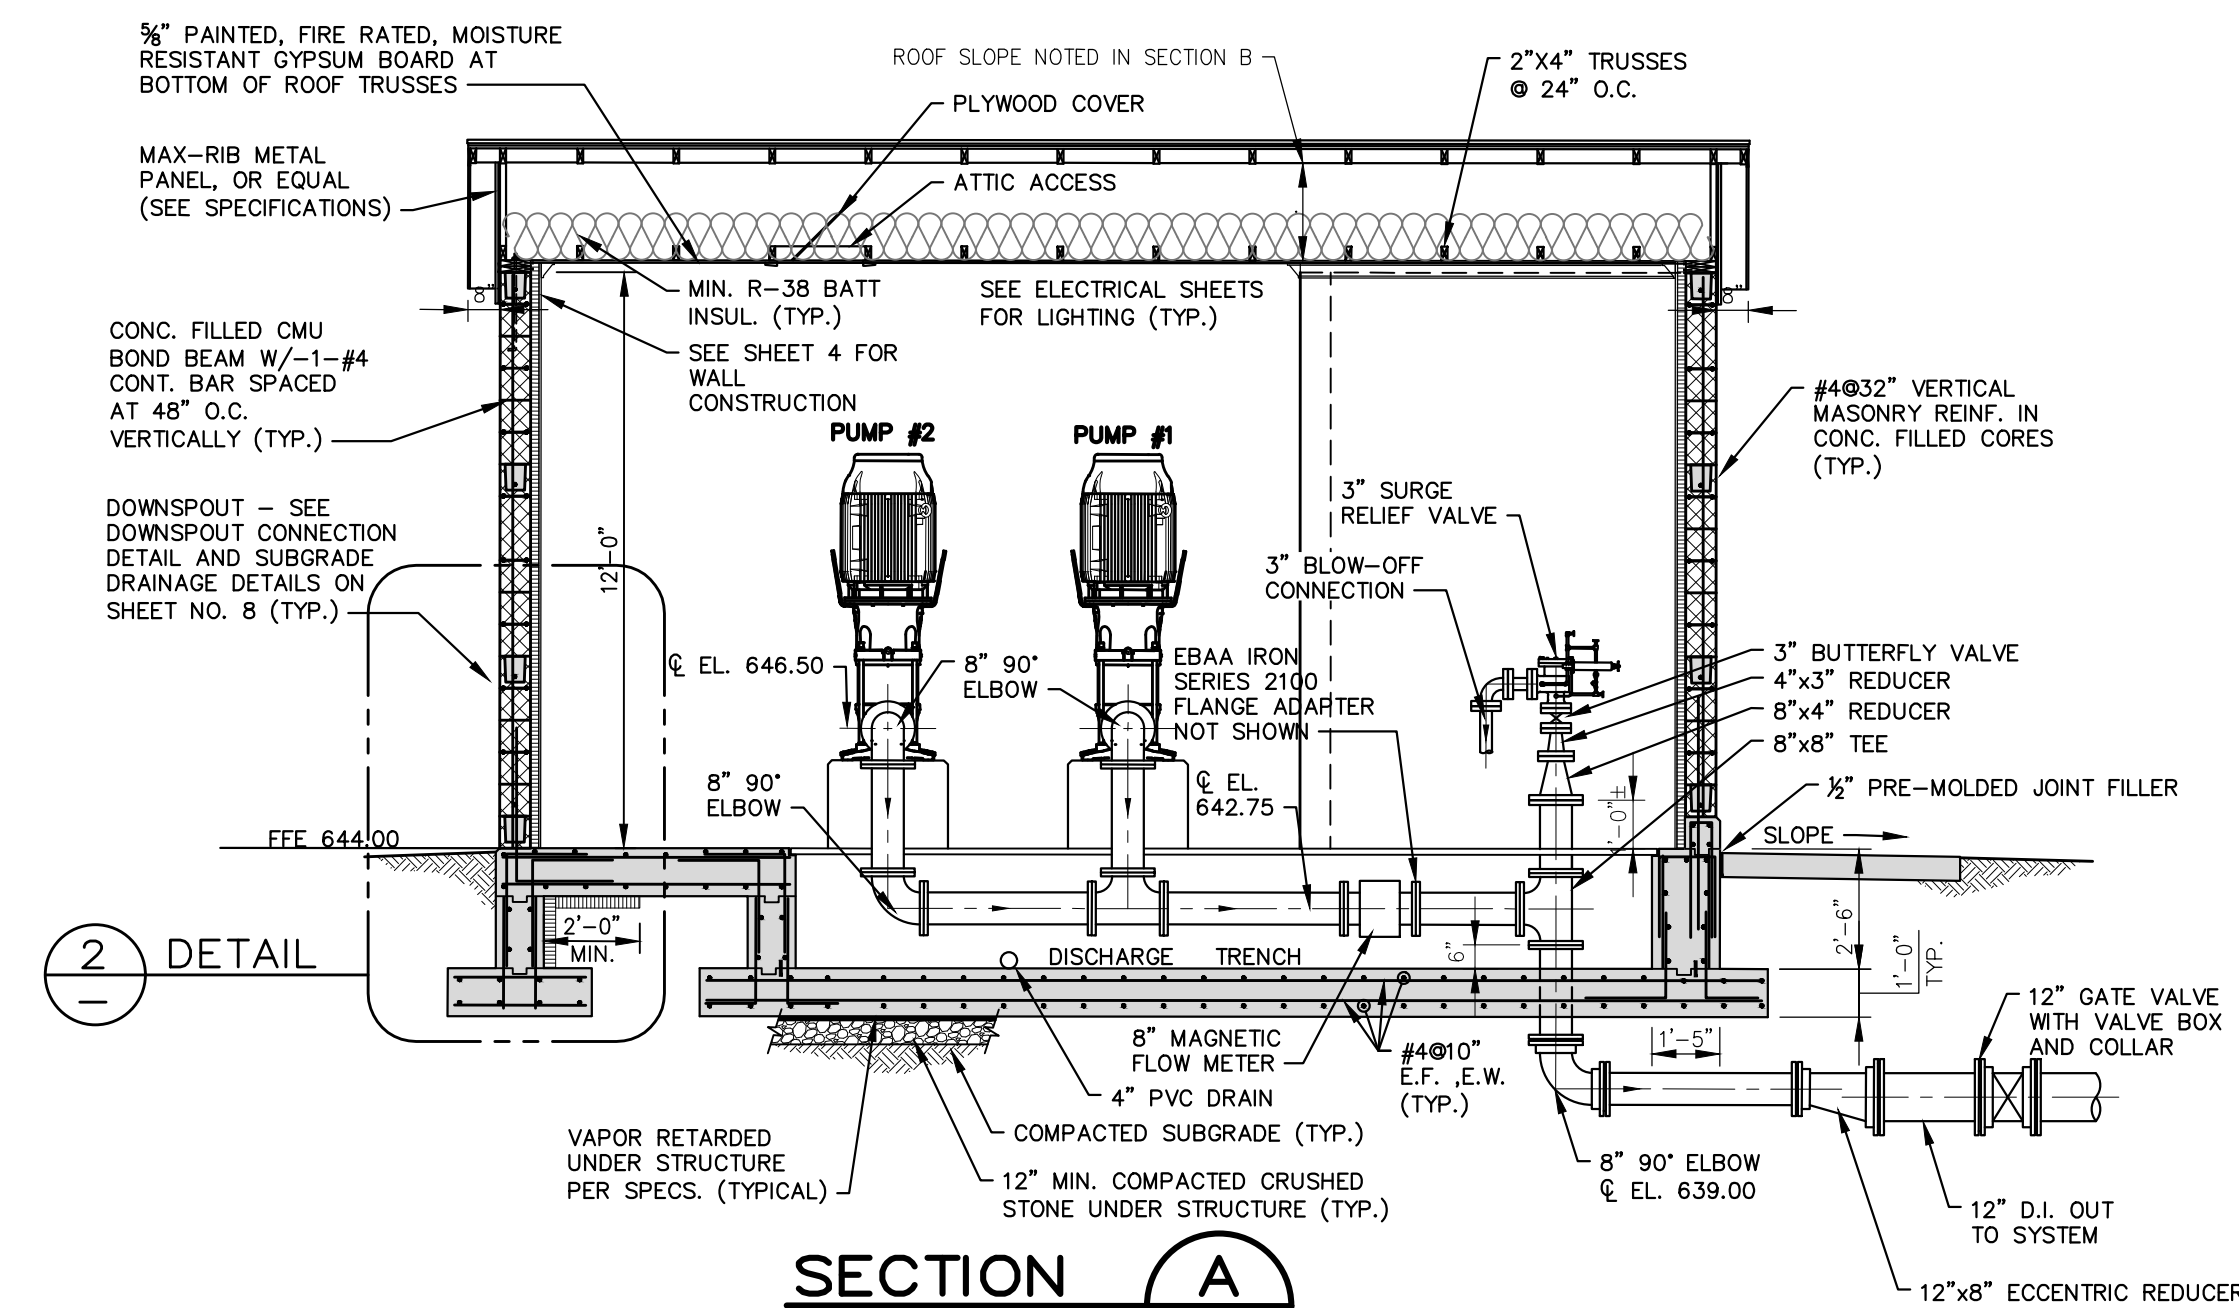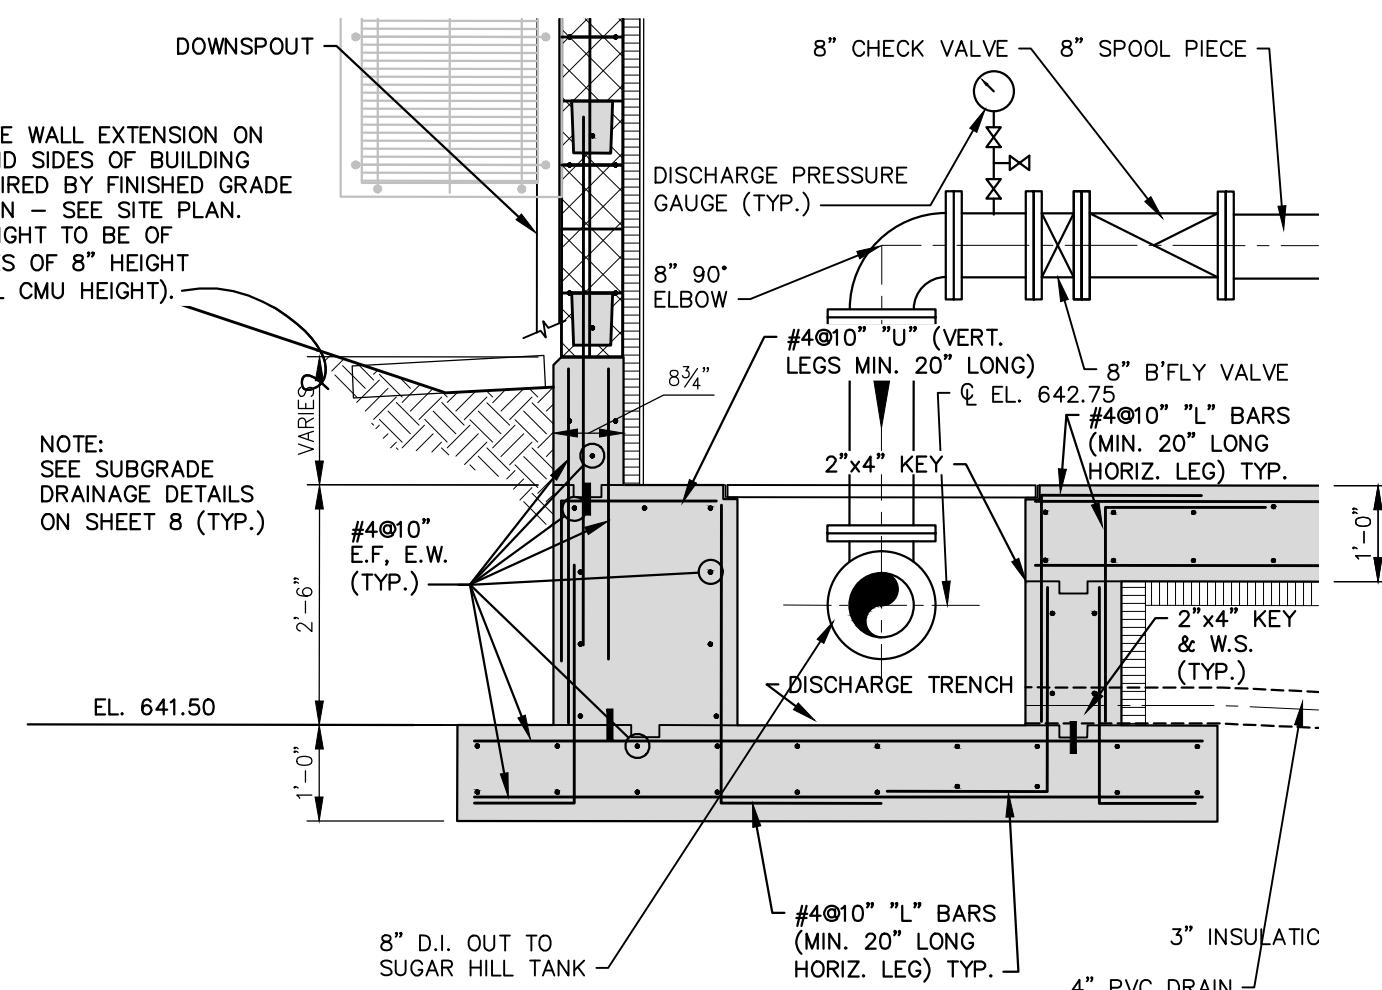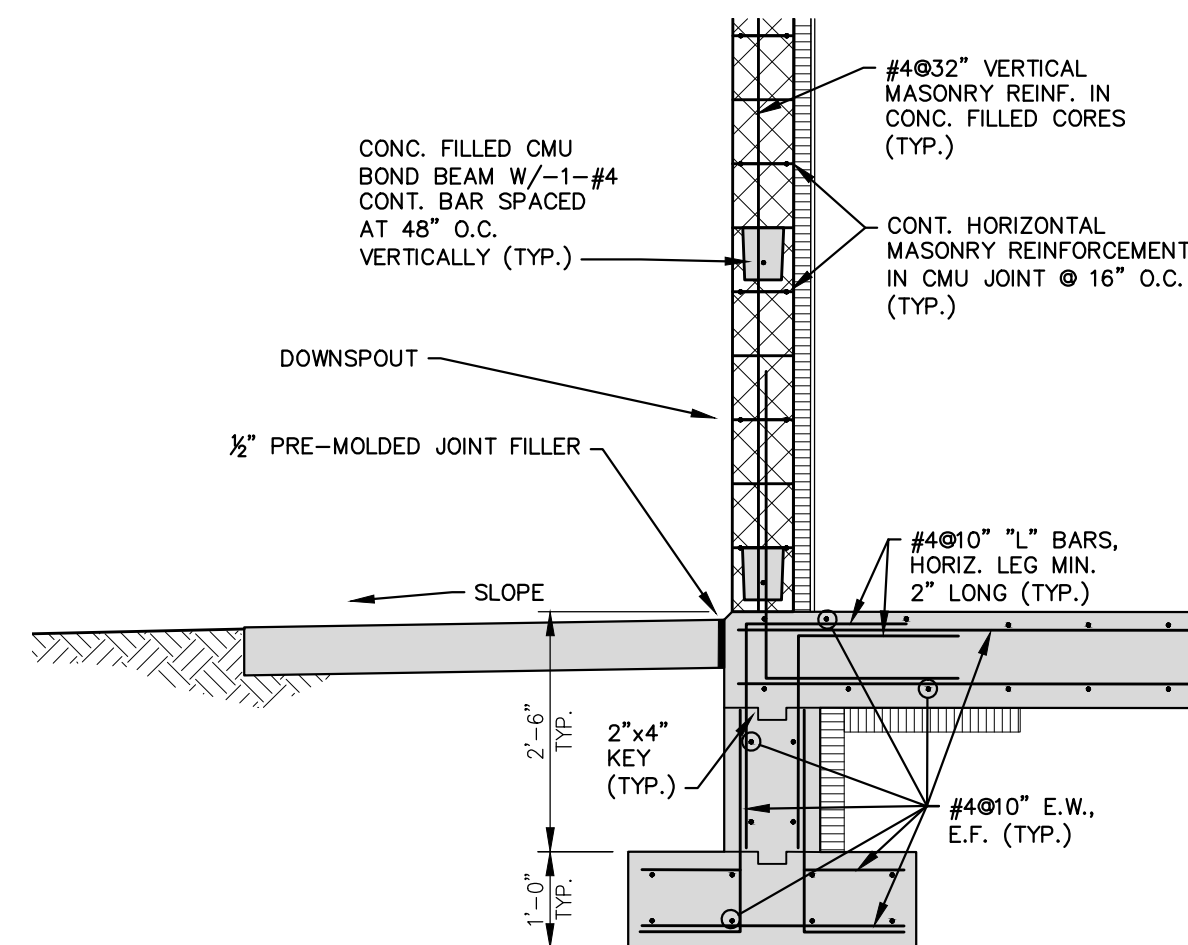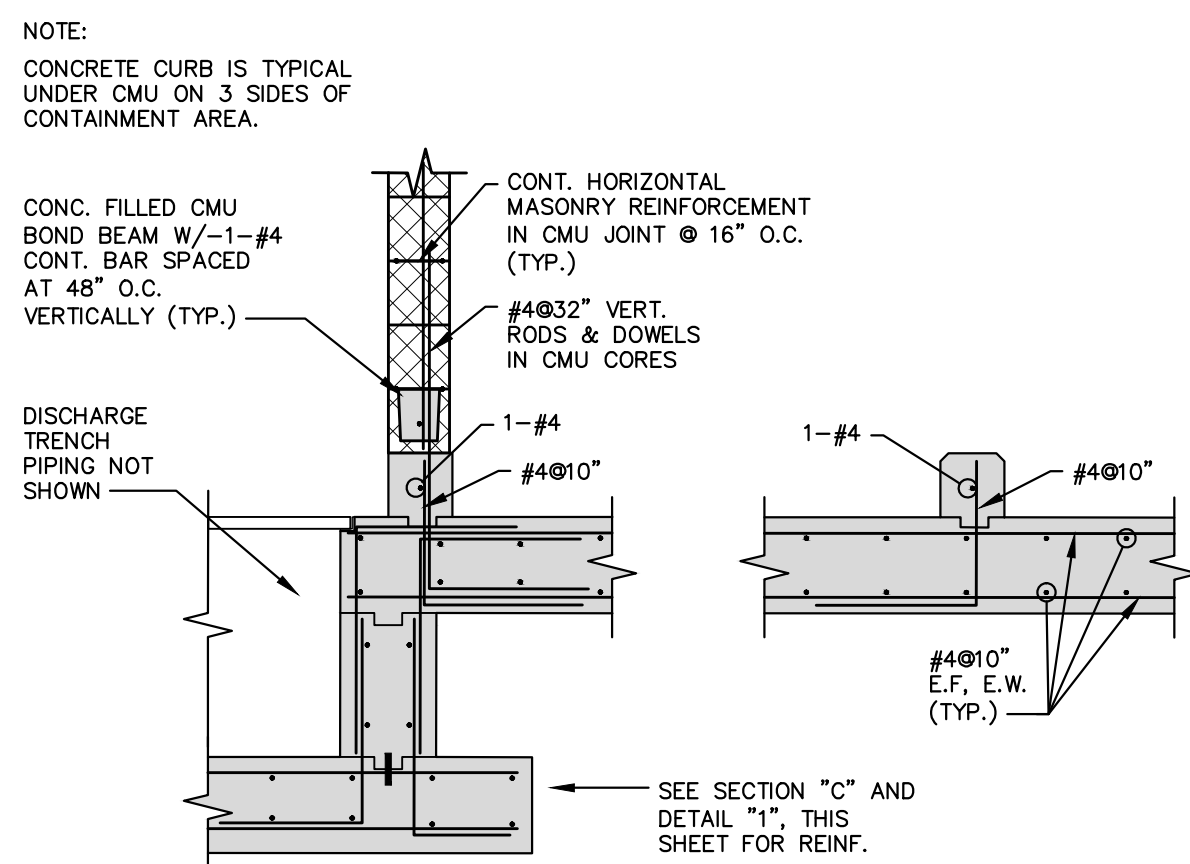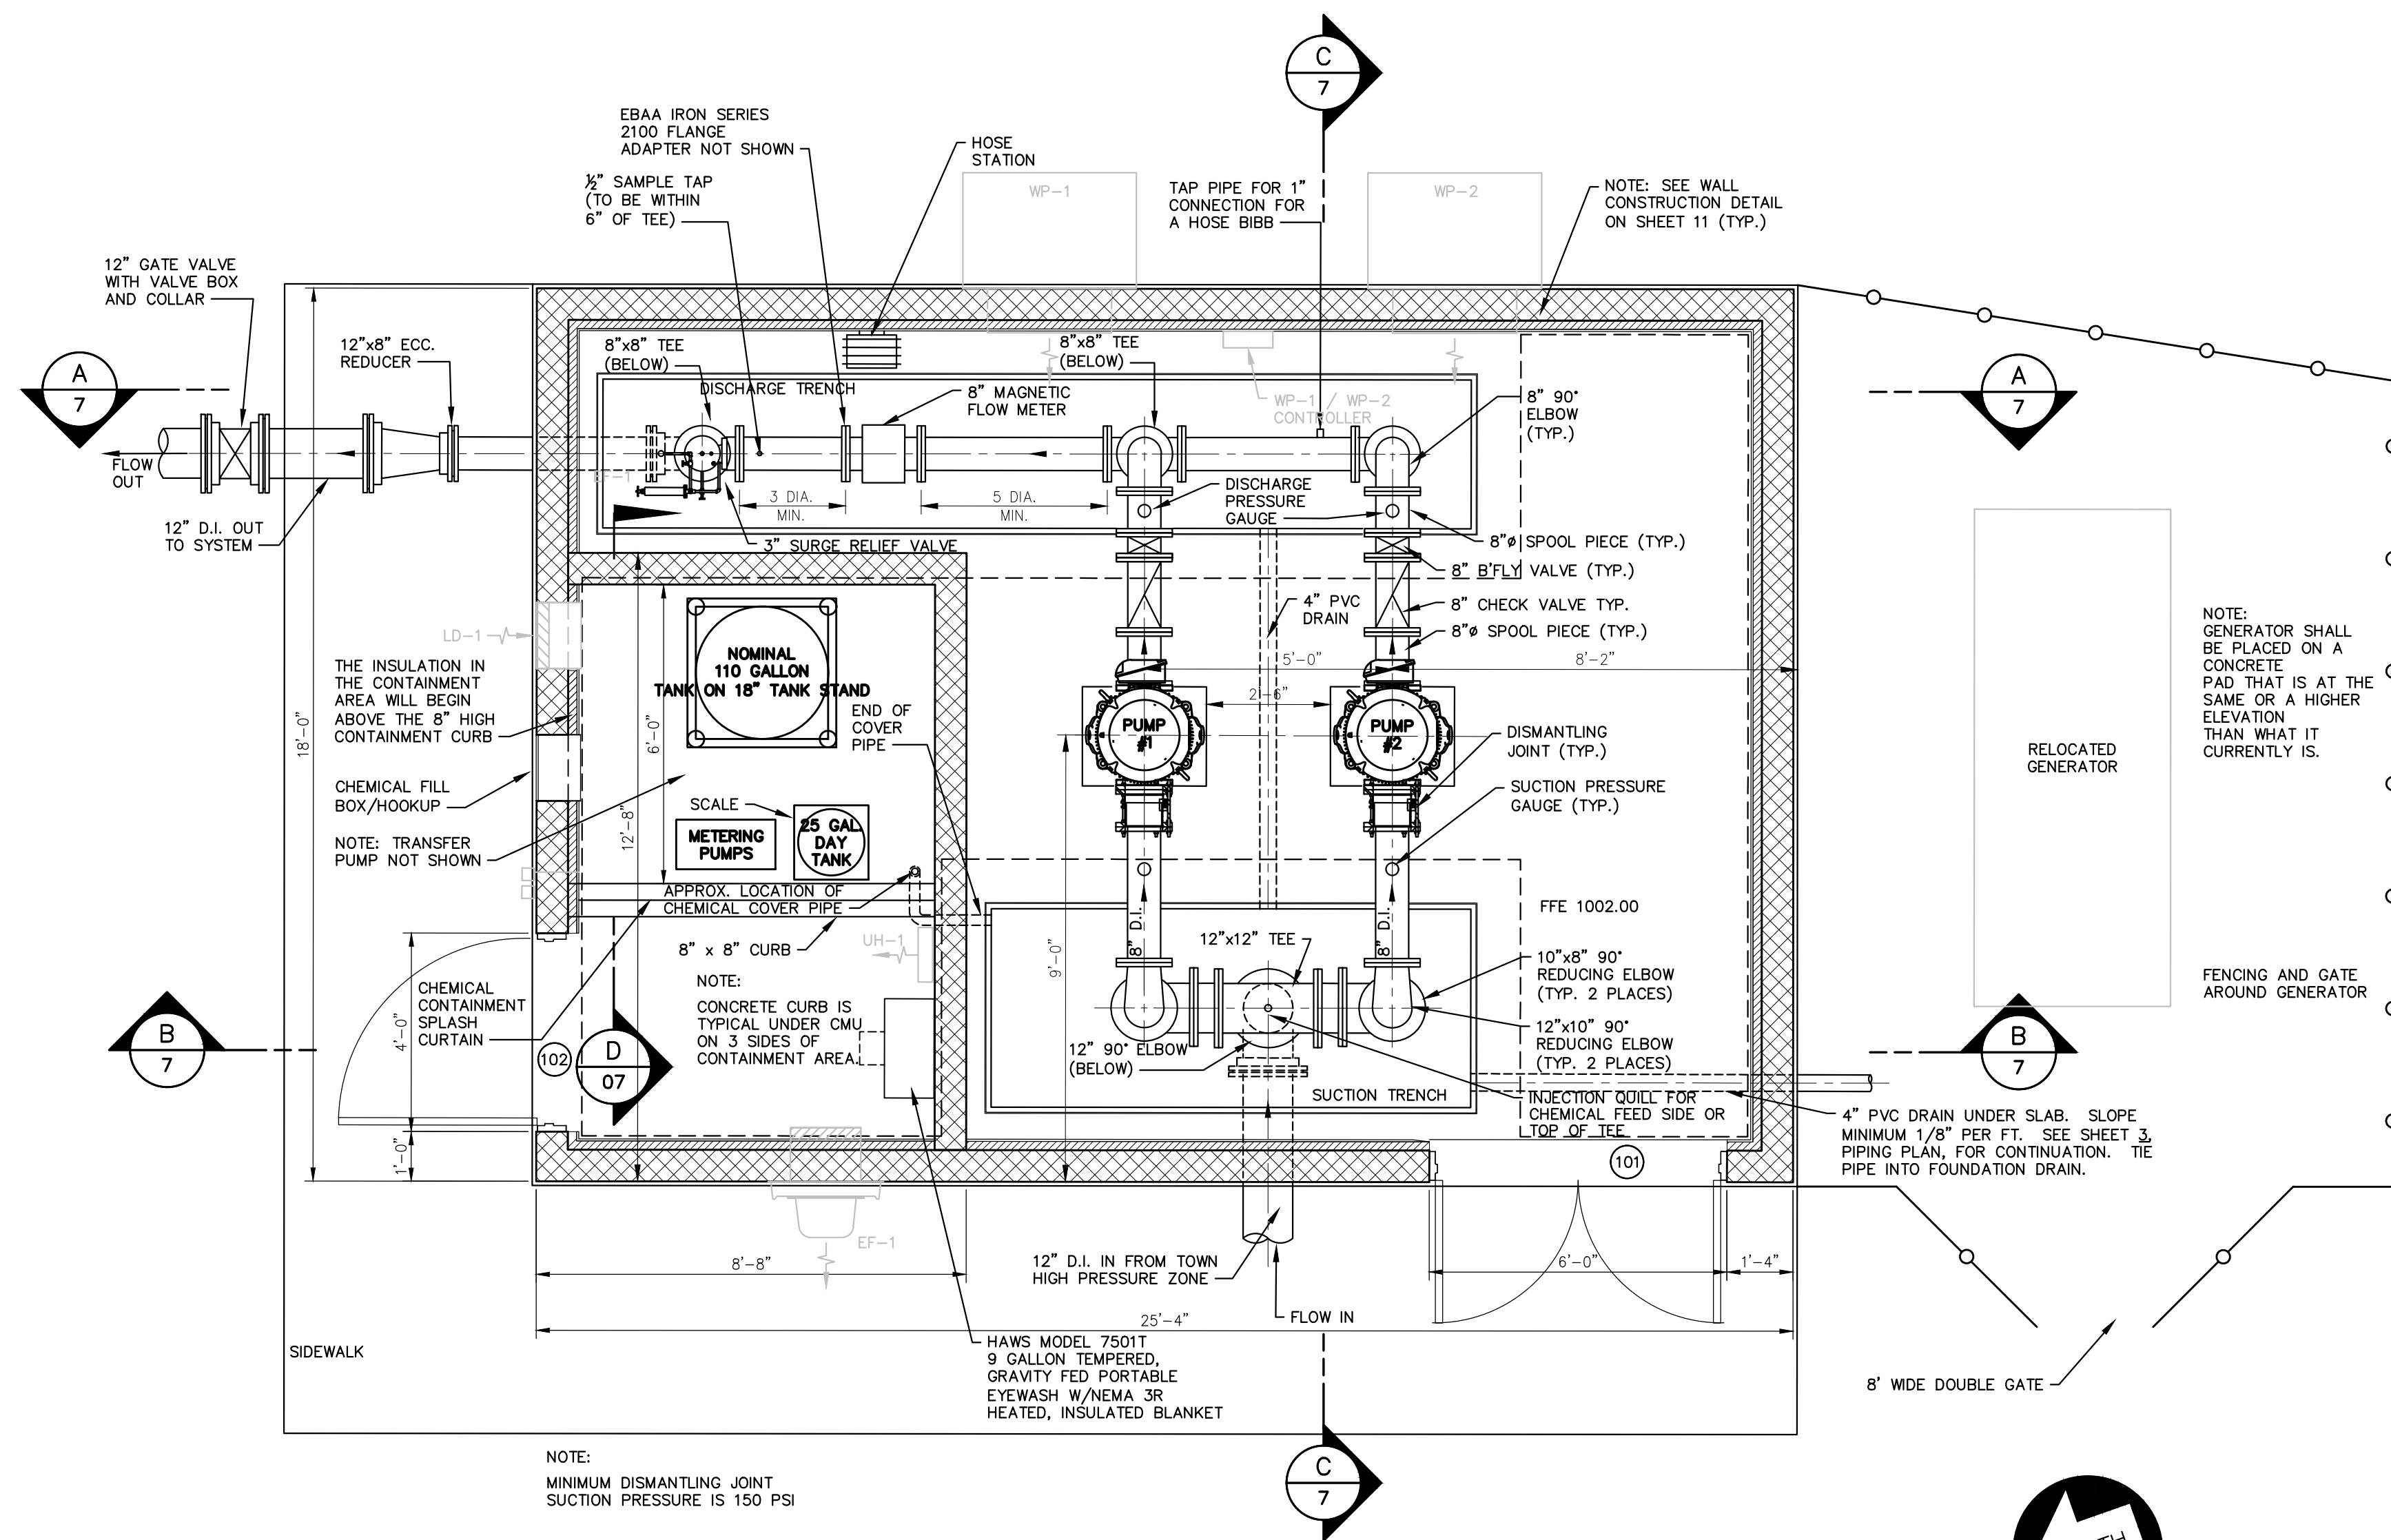


DESIGNER	DEG	DATE	BY	REVISION
DRAWN	TEW			
CHECKED	DEG			
APPROVED	DEG			

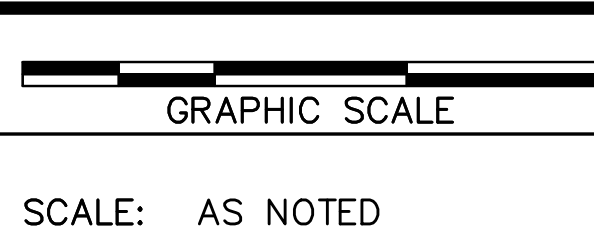

ALL RIGHTS RESERVED

THIS DOCUMENT IS THE PROPERTY OF BELL ENGINEERING AND SHALL NOT BE REPRODUCED IN WHOLE OR IN PART OR USED FOR CONSTRUCTION OF OTHER THAN THIS SPECIFIC PROJECT WITHOUT THE WRITTEN PERMISSION OF BELL ENGINEERING.

FACSIMILES OF LICENSED PROFESSIONAL ENGINEER AND/OR LAND SURVEYOR SEALS, IF AFFIXED TO THIS DOCUMENT, SHALL BE CONSIDERED LEGITIMATE ONLY IF SIGNED AND DATED BY THE REGISTRANT.

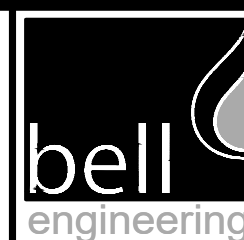


Lexington, KY (859) 278-5412
Hopkinsville, KY (270) 886-5466
Somerset, KY (606) 485-4011

WATER SYSTEM IMPROVEMENTS
SHOPE'S CREEK ROAD AREA
CANNONBURG WATER DISTRICT
CANNONBURG, KENTUCKY

SHOPES CREEK BOOSTER PUMP STATION PLAN AND SECTIONS

DIVISION	—
CONTRACT NO.	691-21-01
DATE	SEPTEMBER 2021
SHEET NO.	07 OF 17

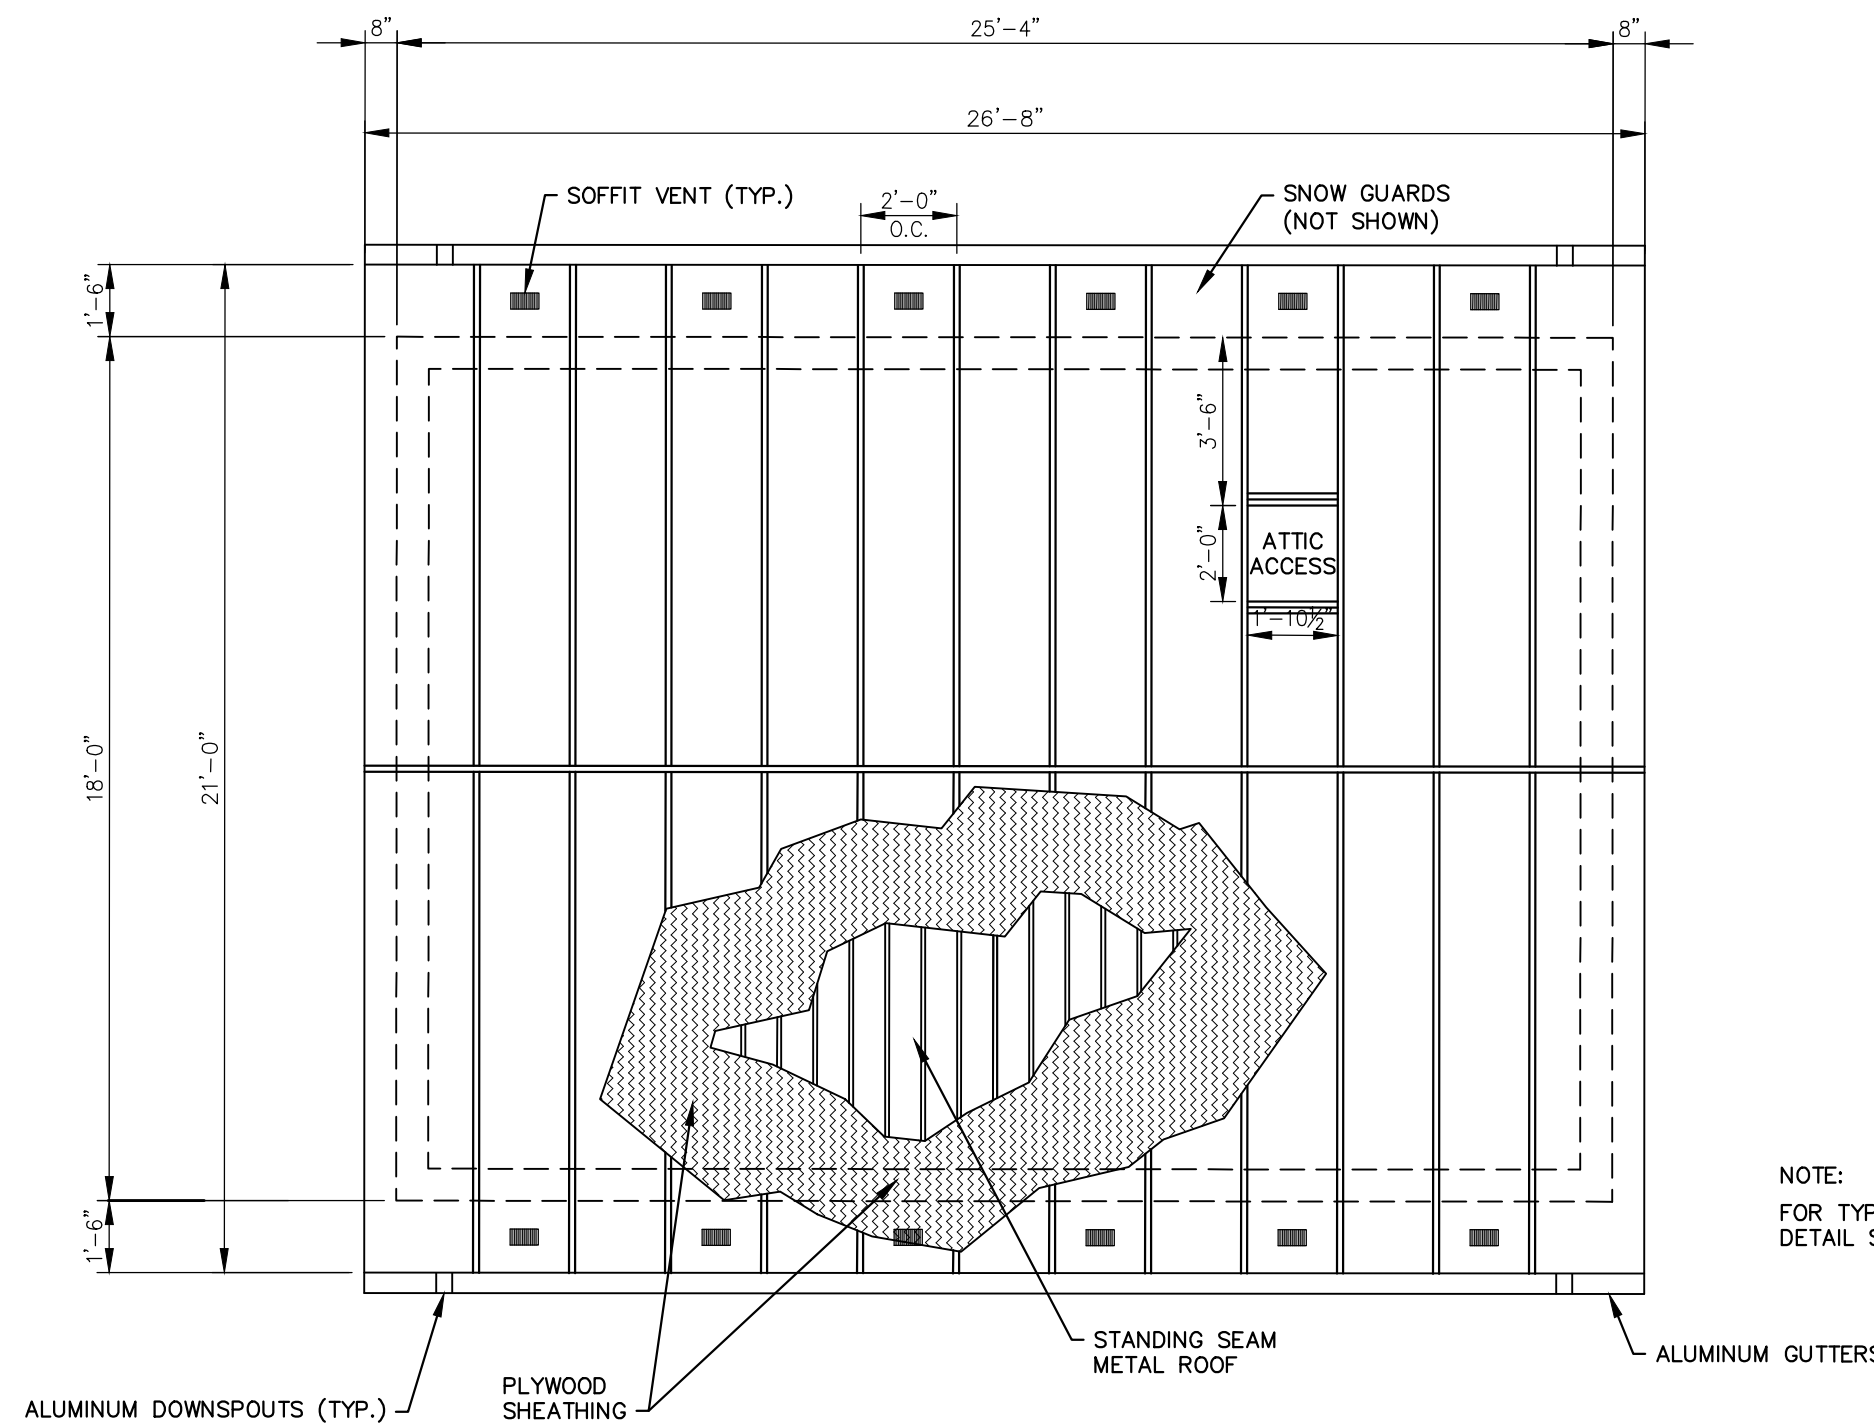

NOTE:
THE NUMBER AND SIZE OF THE ROOF VENTS THAT NEED TO BE PROVIDED SHALL BE BASED ON TOTAL ROOF VENT AND RIDGE VENT AREA BEING AT LEAST 0.75 SF OF FREE AREA. THE NUMBER OF SOFFIT VENTS NEEDED SHALL BE BASED ON PROVIDING AT LEAST 0.85 SF OF FREE AREA.



ROOF PLAN

SCALE: 1/4"=1'-0"

NOTE:
FOR ROOF CONSTRUCTION NOTES SEE SHEET 12.






NOTE:
FOR TYPICAL ROOF EDGE DETAIL SEE SHEET NO. 11

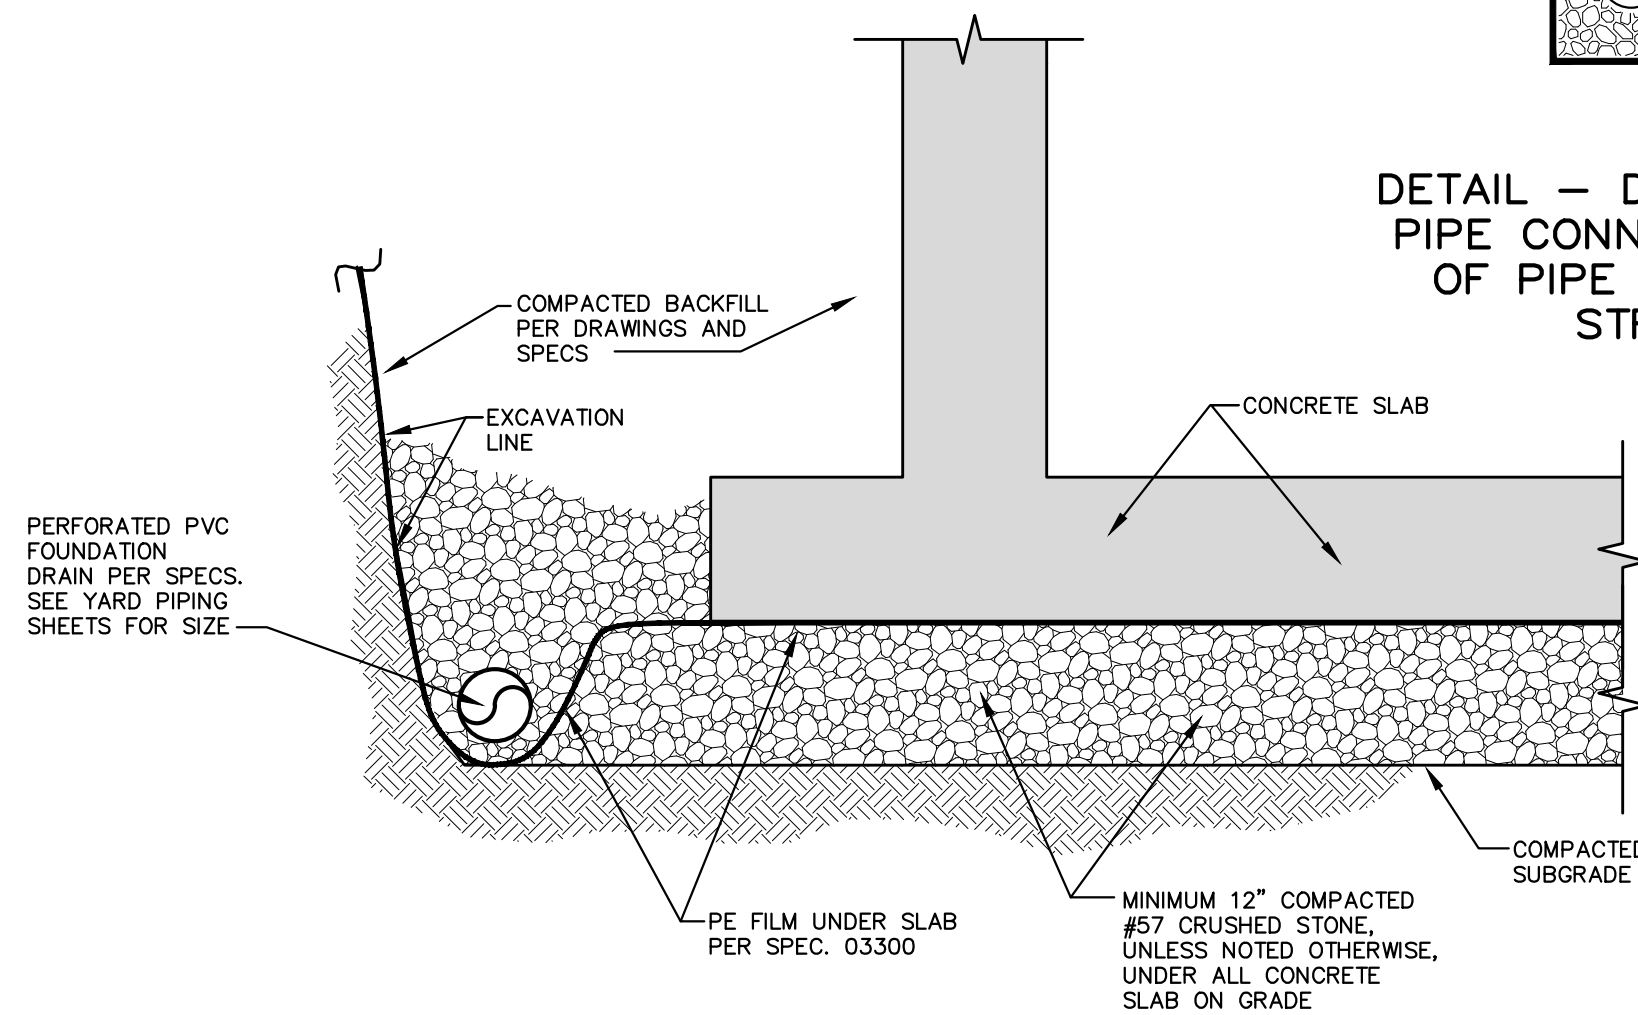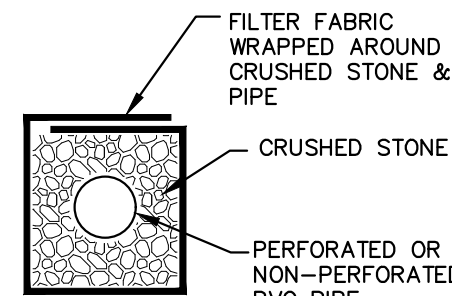


TYPICAL STRUCTURE SUBGRADE TREATMENT AND DRAINAGE CARRIER PIPE DETAIL


NOT TO SCALE

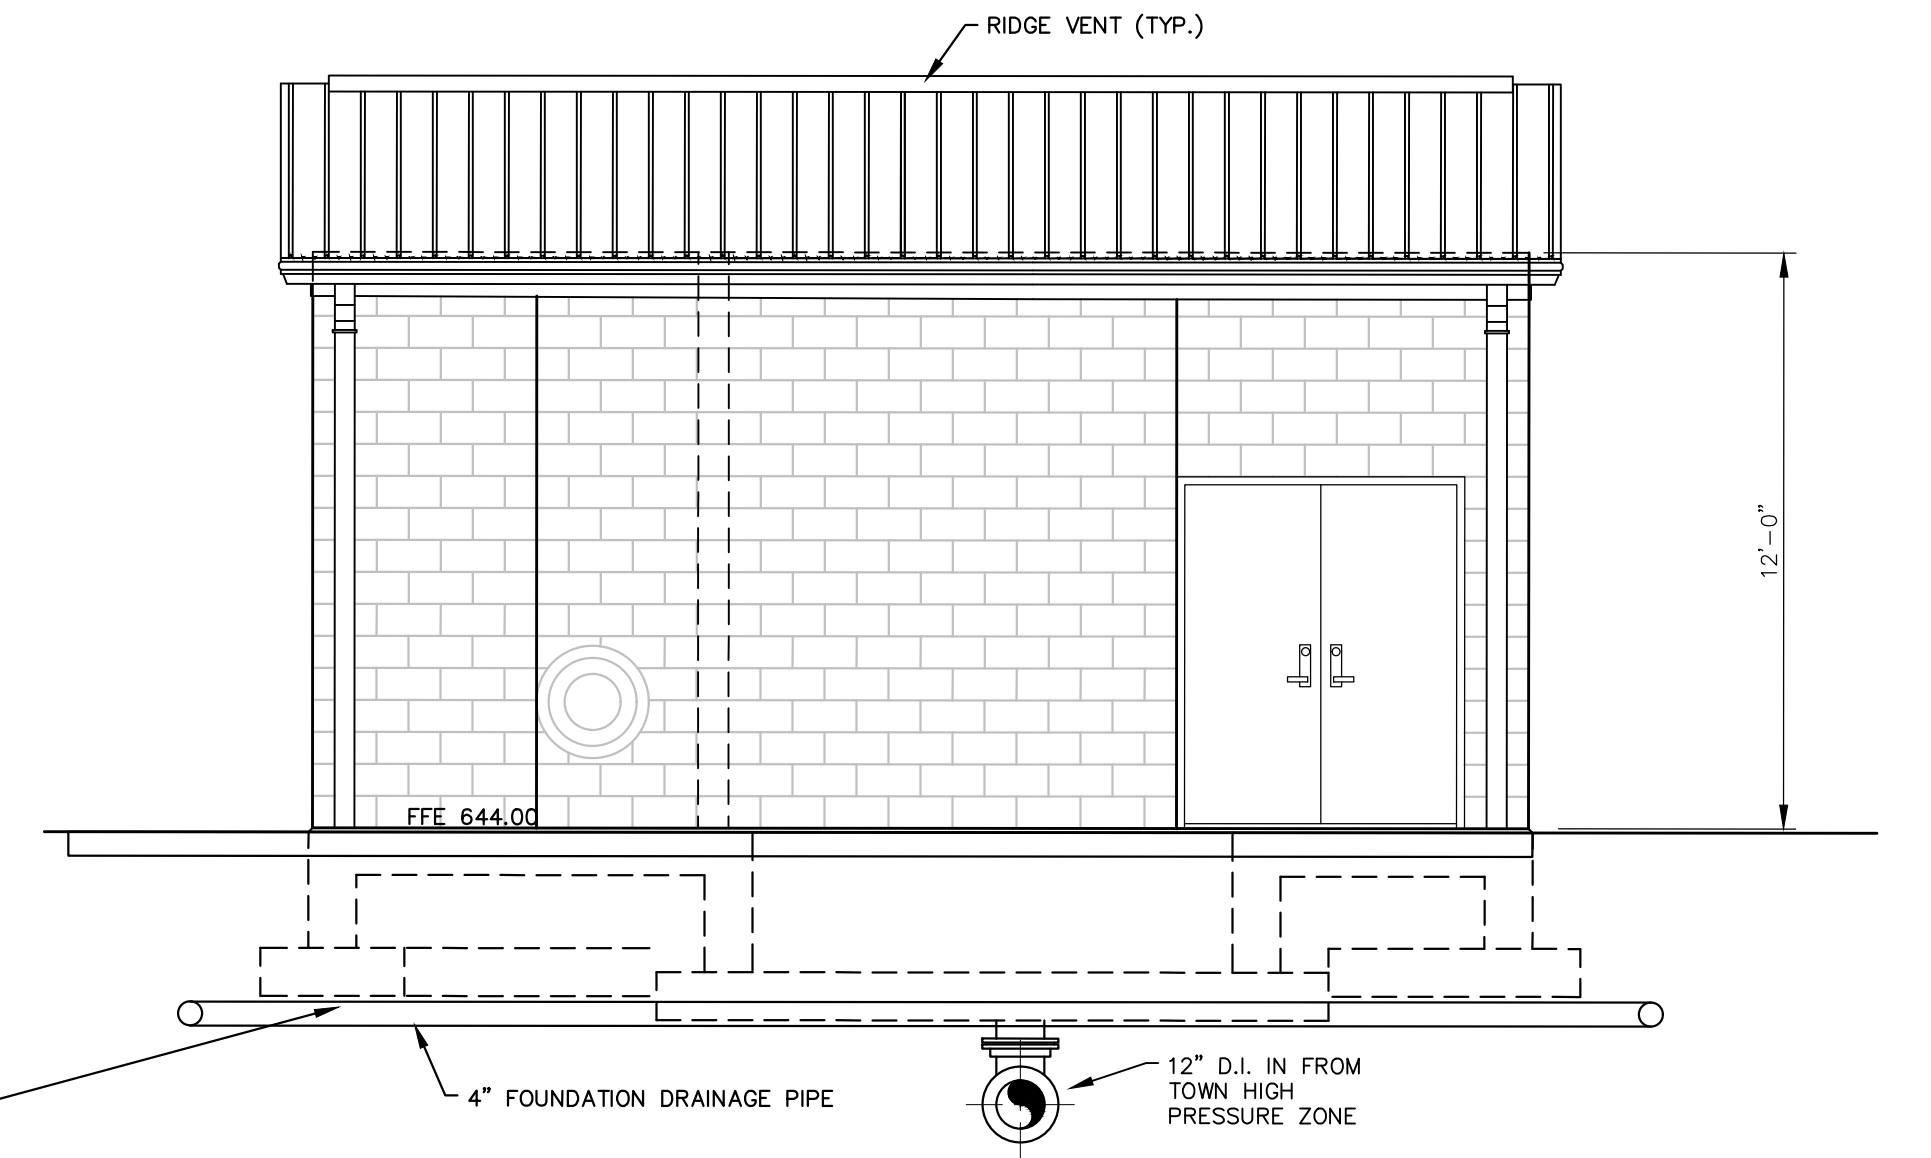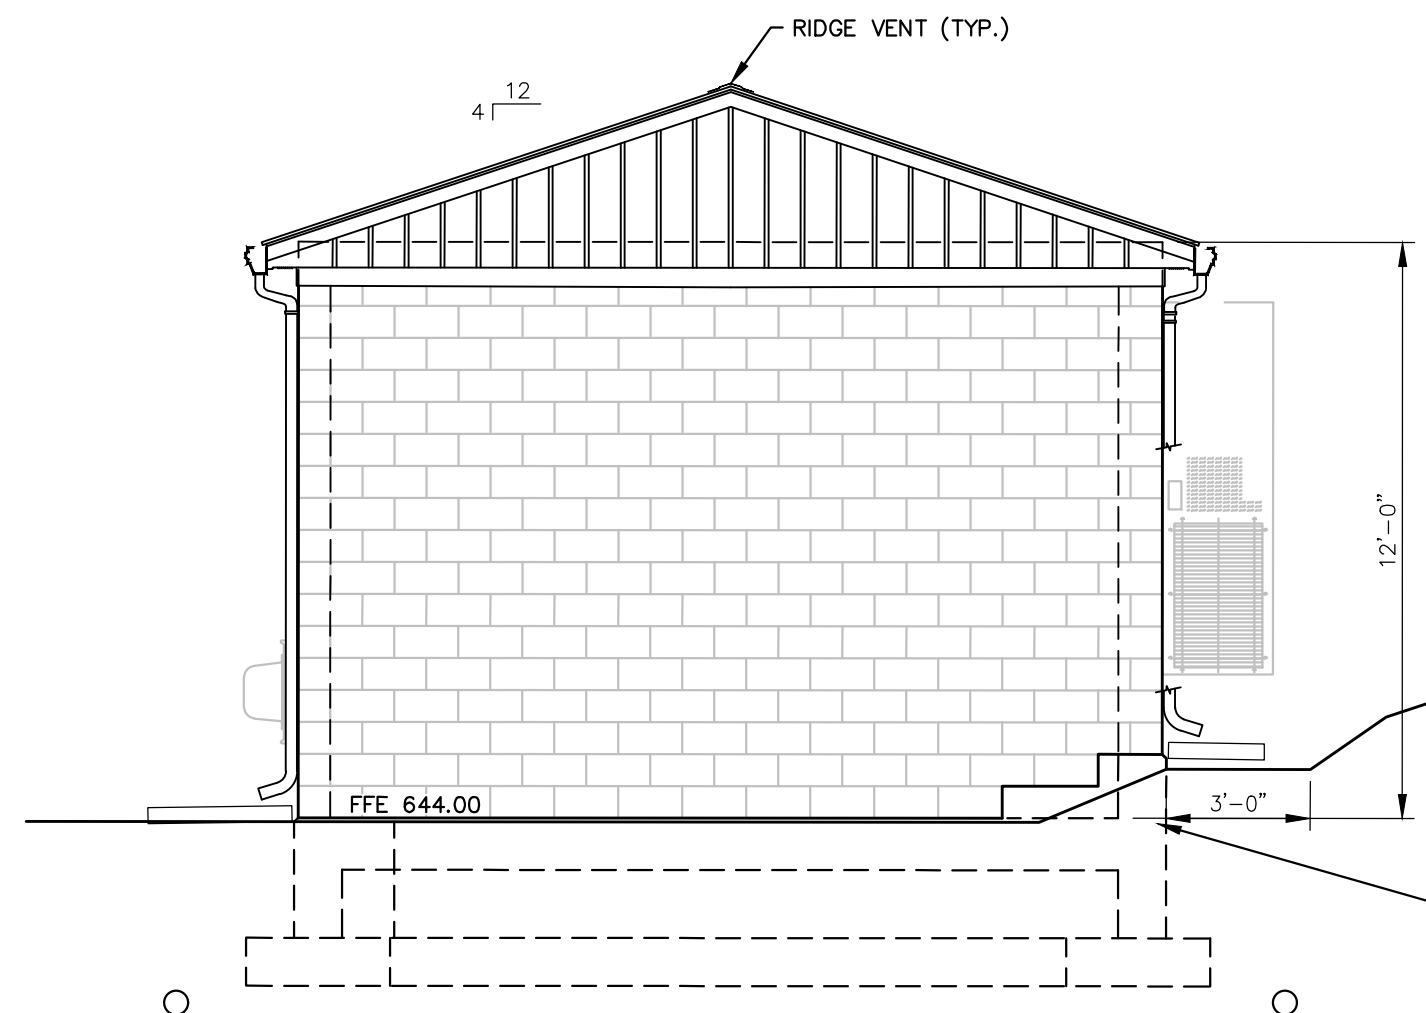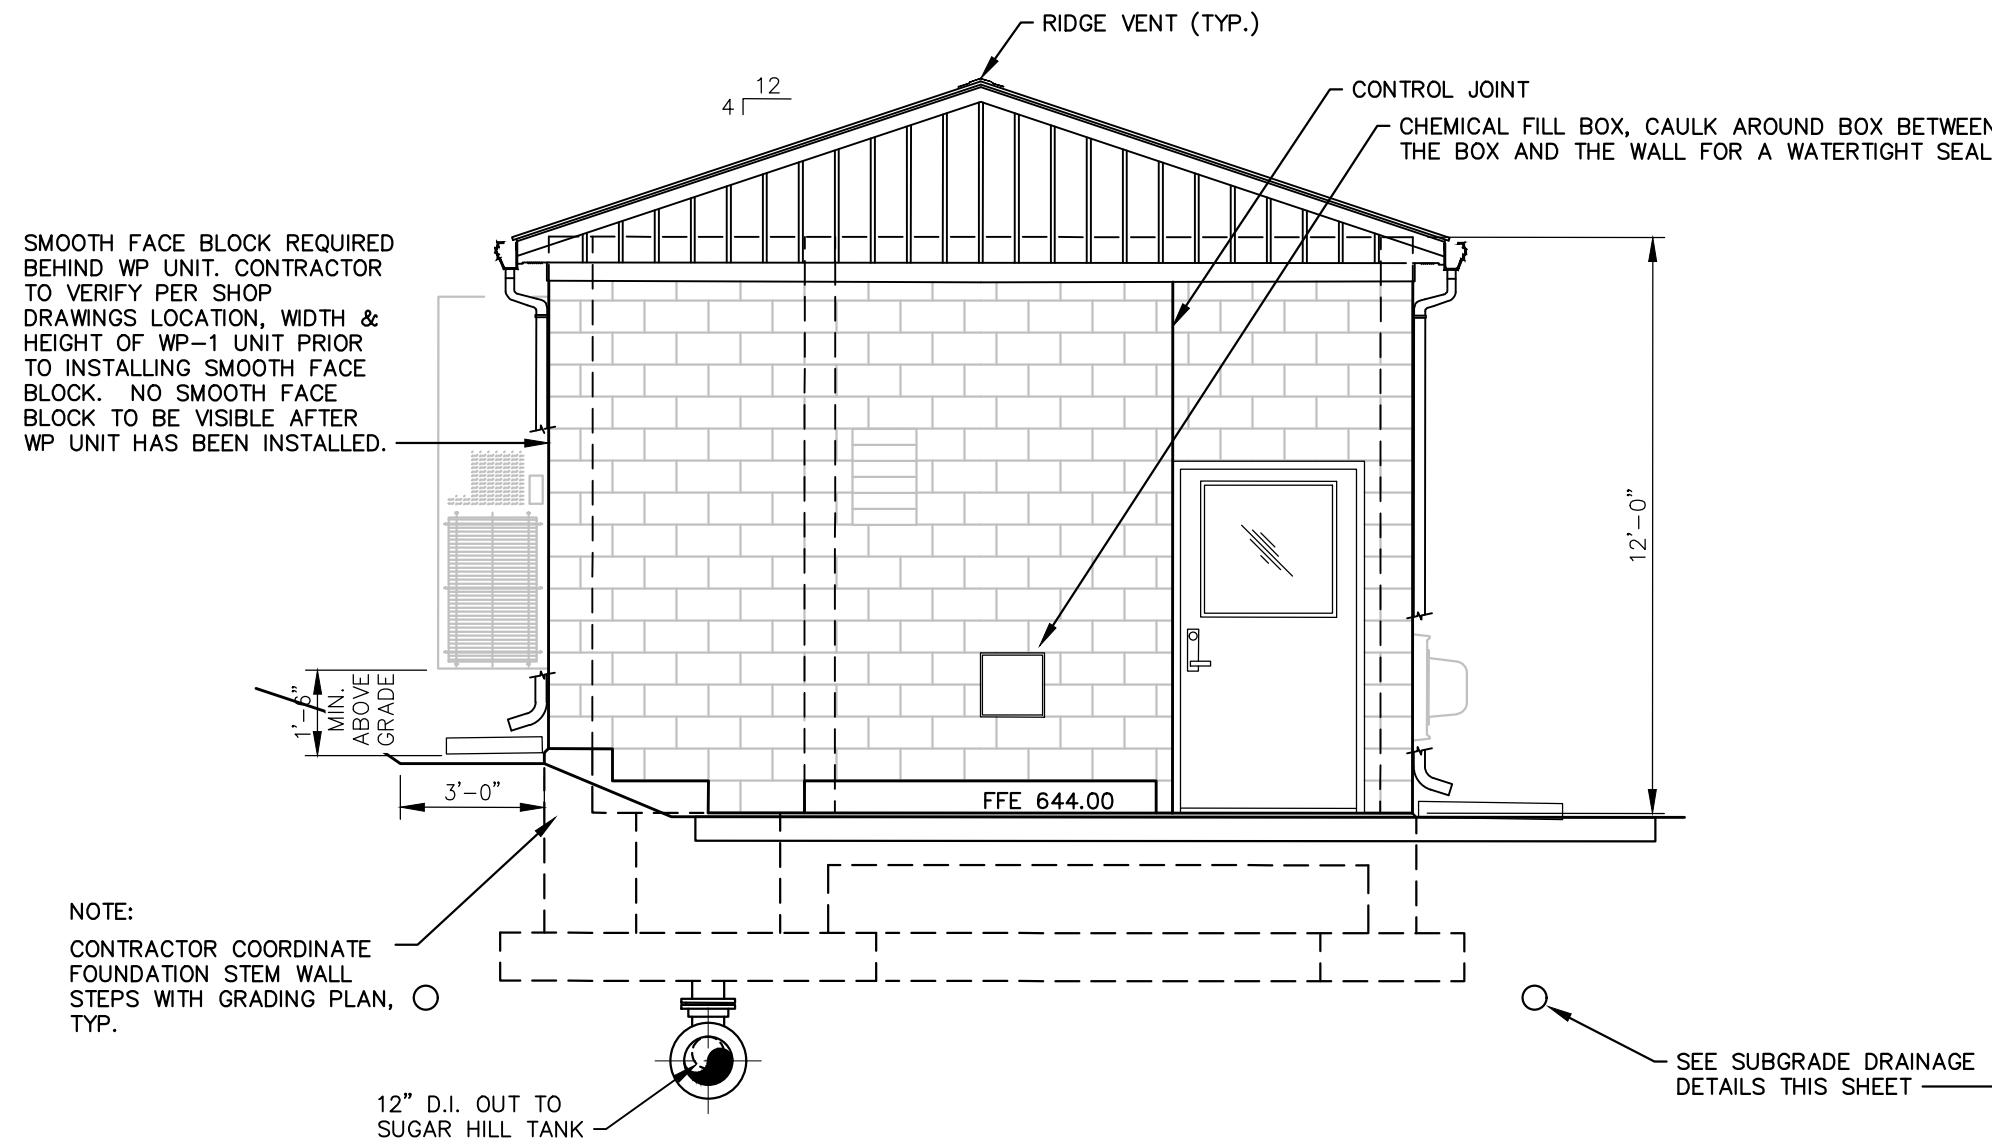

NOTE:
DOWNSPOUTS SHALL COME TO WITHIN 3 INCHES OF SPASH BLOCKS

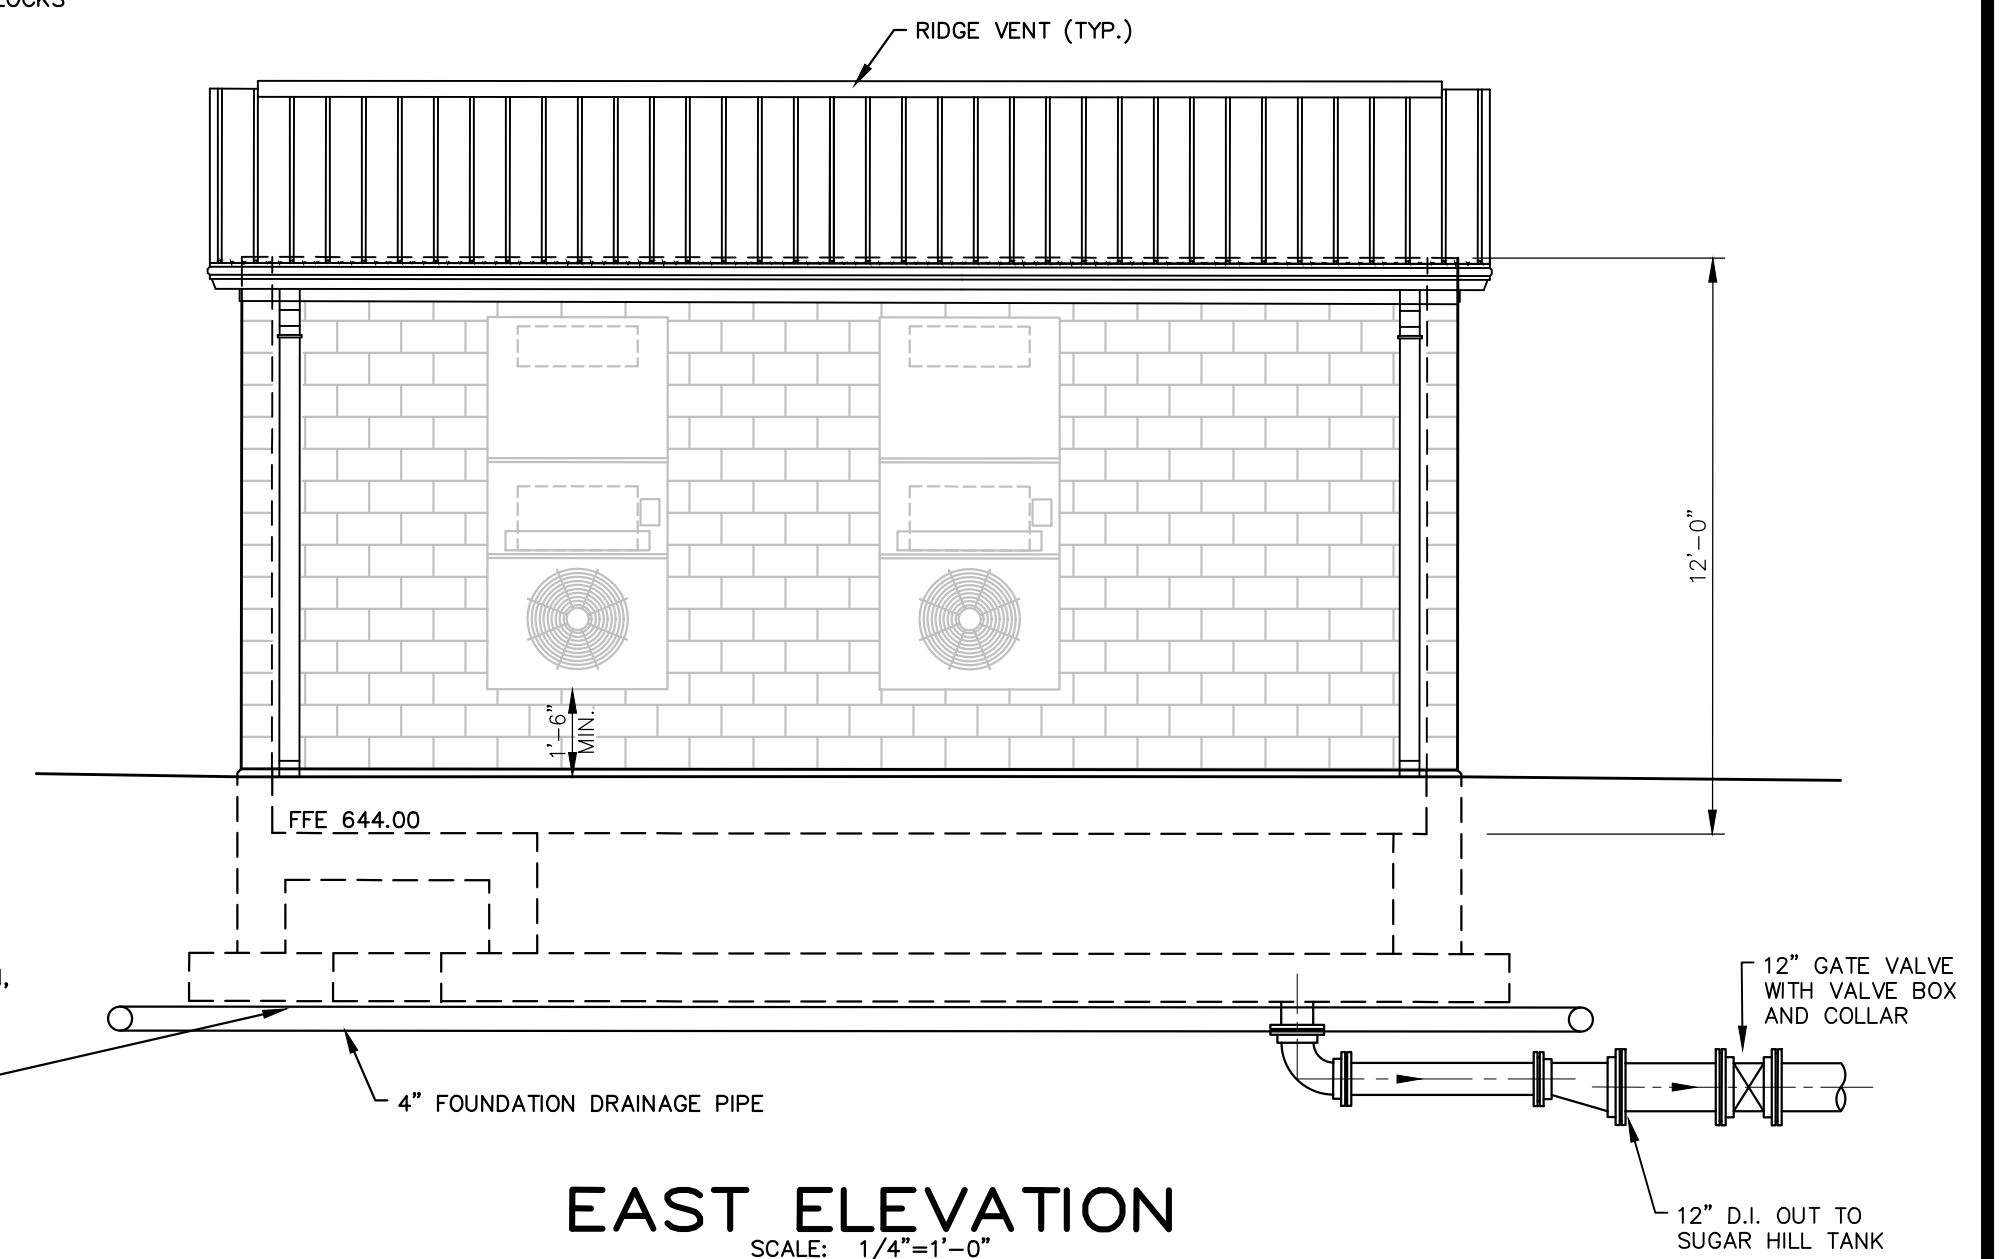


DESIGNER	DEG	DATE	BY	REVISION
DRAWN	TEW			
CHECKED	DEG			
APPROVED	DEG			

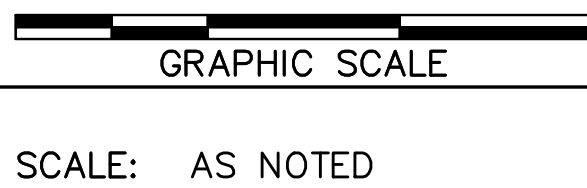

ALL RIGHTS RESERVED

THIS DOCUMENT IS THE PROPERTY OF BELL ENGINEERING AND SHALL NOT BE REPRODUCED IN WHOLE OR IN PART OR USED FOR CONSTRUCTION OF OTHER THAN THIS SPECIFIC PROJECT WITHOUT THE WRITTEN PERMISSION OF BELL ENGINEERING.

FACSIMILES OF LICENSED PROFESSIONAL ENGINEER AND/OR LAND SURVEYOR SEALS, IF AFFIXED TO THIS DOCUMENT, SHALL BE CONSIDERED LEGITIMATE ONLY IF SIGNED AND DATED BY THE REGISTRANT.

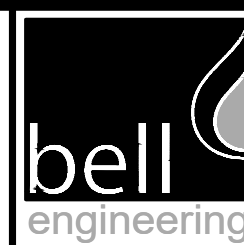


Lexington, KY (859) 278-5412
Hopkinsville, KY (270) 886-5466
Somerset, KY (606) 485-4011

WATER SYSTEM IMPROVEMENTS
SHOPS CREEK ROAD AREA
CANNONSURG WATER DISTRICT
CANNONSURG, KENTUCKY

SHOPS CREEK
BOOSTER PUMP STATION
BUILDING ELEVATIONS
AND ROOF PLAN

DIVISION	-
CONTRACT NO.	691-21-01
DATE	SEPTEMBER 2021
SHEET NO.	08 OF 17

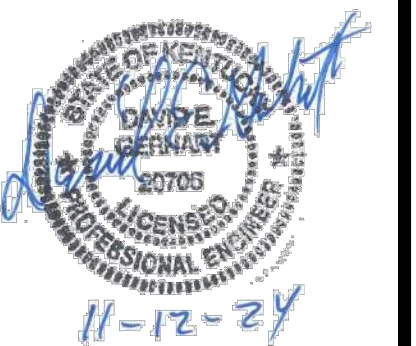

- BULK TANK FILL LINES ARE 2" UNLESS NOTED OTHERWISE. DAY TANK FILL LINES ARE AS NOTED IN THE TANK SCHEDULES.
- BULK TANK VENT LINES ARE 2.5 OR 3", DAY TANK VENT LINES ARE 1 SIZE LARGER THAN THEIR FILL LINE OR 2", WHICHEVER IS LARGER.
- OVERFLOW LINES ARE MINIMUM 1 SIZE LARGER THAN THE TANK'S FILL LINE UNLESS NOTED OTHERWISE.
- DRAIN LINES ARE MINIMUM 3" FOR TANKS 2,500 GALLONS OR LARGER, 2" FOR TANKS 500 TO 2,499 GALLONS AND 1.5" FOR TANKS SMALLER THAN 500 GALLONS. TANK DRAIN NOZZLES SHALL HAVE INVERTS FLUSH WITH THE TANK BOTTOM OR WITHIN INCH OF THE BOTTOM AND WHERE THIS IS NOT POSSIBLE THE NOZZLE'S INVERT SHALL BE EQUAL OR LOWER THAN THE PUMP SUCTION NOZZLE, 2" TO 3" ABOVE THE TANK BOTTOM.
- BULK TANK AND DAY TANK SUCTION LINES ARE AS NOTED ON THE TANK SCHEDULES.
- DAY TANK AND BULK TANK VENT LINES FOR THE SAME CHEMICAL SHALL NOT BE TIED TOGETHER. BULK TANK VENT LINES FOR THE SAME CHEMICAL MAY BE TIED TOGETHER.
- TANK STANDS SHALL BE CONSTRUCTED OF PAINTED STEEL, STAINLESS STEEL, FRP OR OTHER COMPATIBLE MATERIAL. STANDS MADE OF CONCRETE OR CONCRETE BLOCK ARE NOT ACCEPTABLE.
- BULK TANK AND MINI-BULK TANK ARE INTERCHANGEABLE UNLESS OTHERWISE NOTED.
- DAY TANKS AND THEIR STANDS SHALL BE LOCATED AT LEAST 6 INCHES FROM THE CONTAINMENT WALLS IF THE TANK BOTTOM IS LESS THAN 6 INCHES BELOW THE TOP OF THE WALL, AND 12 INCHES FROM THE CONTAINMENT WALLS IF THE TANK BOTTOM IS LESS THAN 6 INCHES BELOW THE TOP OF THE WALL. IF THE TANK'S BOTTOM IS LOCATED AT 6 INCHES OR MORE ABOVE THE CONTAINMENT WALLS, THE TANK SHALL BE LOCATED AT LEAST 18 INCHES FROM THE WALLS OR AS FAR AS POSSIBLE.
- CONCRETE PADS UNDER BULK TANKS AND DAY TANKS SHALL BE THE SIZE SHOWN IN THE BULK/SUPPLY TANK AND DAY TANK DETAILS. THEY SHALL NOT BE ENLARGED WITHOUT WRITTEN PERMISSION FROM THE ENGINEER. CONCRETE PADS SHALL HAVE BOXED OUT AREAS FOR NOZZLES AS REQUIRED.
- BULK TANKS SHALL BE LOCATED WHERE SHOWN. FINAL TANK NOZZLE LOCATION SHALL BE PER THE CONTRACTOR UNLESS A SPECIFIC NOZZLE LOCATION IS NOTED IN THE DRAWINGS OR SPECIFICATIONS. THE CONTAINMENT WALL SHALL BE LOCATED SO THE OPERATOR CAN EASILY SEE THE GAUGE FROM THE METERING PUMP AND TANK FILL AREA. IF THERE IS NO CLEAR VIEW FROM THE TANK FILL AREA, I.E., THROUGH A SOLID WALL WITHOUT A TANK ACCESS DOOR, THEY SHALL BE VISIBLE FROM THE METERING PUMP AREA. NOZZLES SHALL BE NOT LOCATED IN TIGHT CONFINED SPACES.
- TANK VENT LINES SHALL BE LOCATED AT LEAST 10 FEET FROM HVAC AIR INTAKE LOUVERS.

NOT TO SCALE

NOT TO SCALE

NOT TO SCALE

NOT TO SCALE

NOT TO SCALE

SCALE: AS NOTED





WATER SYSTEM IMPROVEMENTS
SHOPE'S CREEK ROAD AREA
CANNONBURG WATER DISTRICT
CANNONBURG, KENTUCKY

CHEMICAL FEED DETAILS

DIVISION	—
CONTRACT NO.	691-21-01
DATE	SEPTEMBER 2021
SHEET NO.	09 OF 17

DAVID E. GERMANY
20706
11-12-24

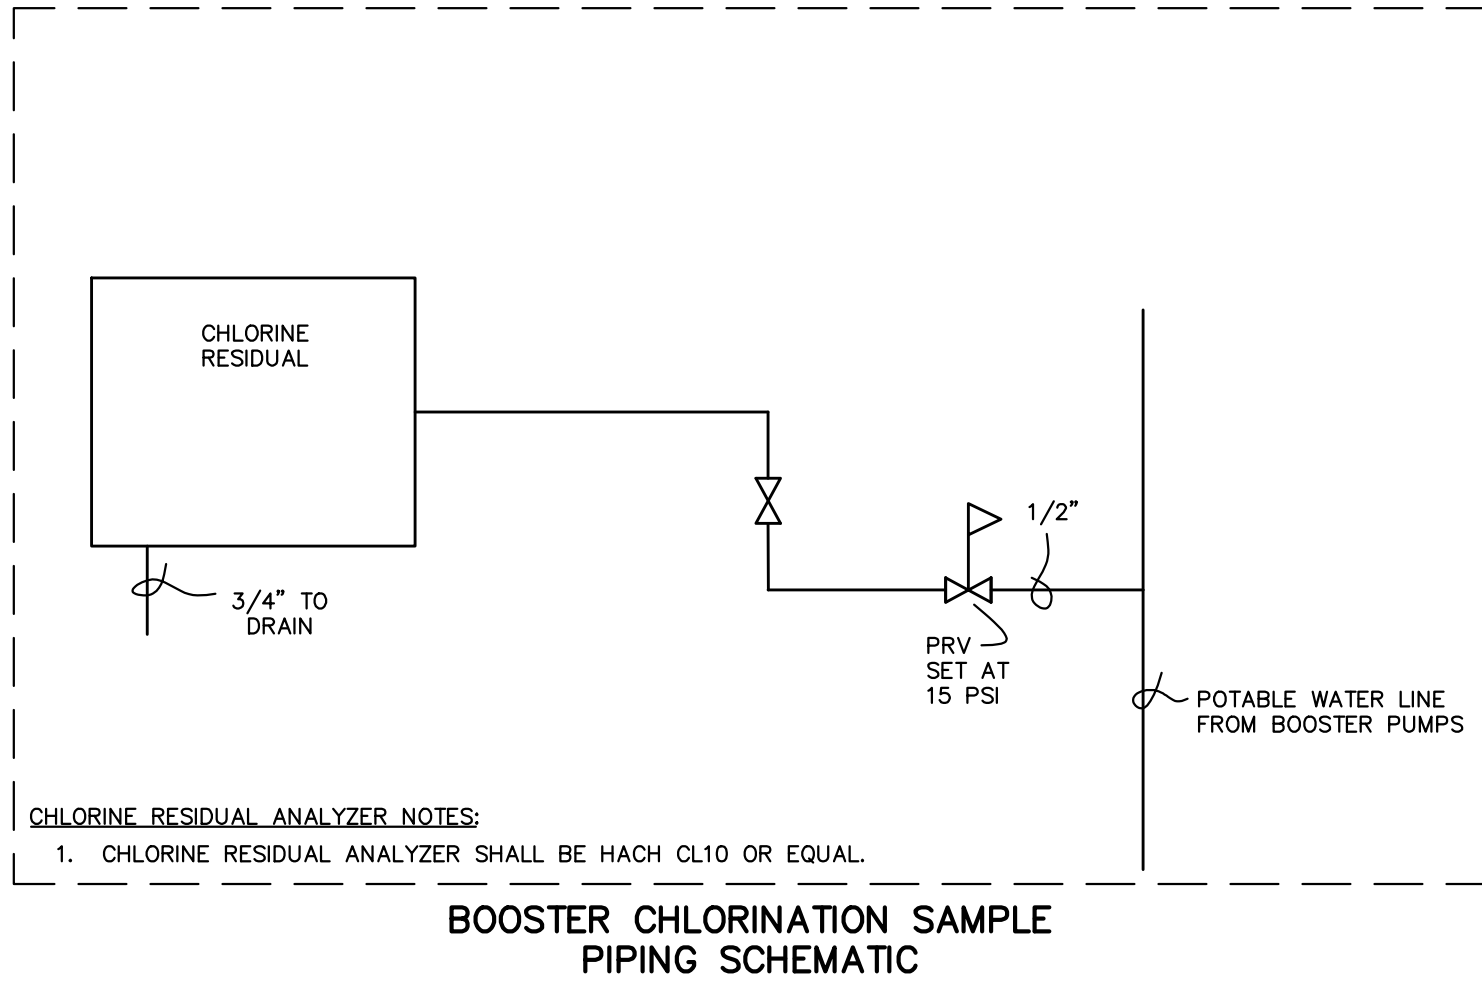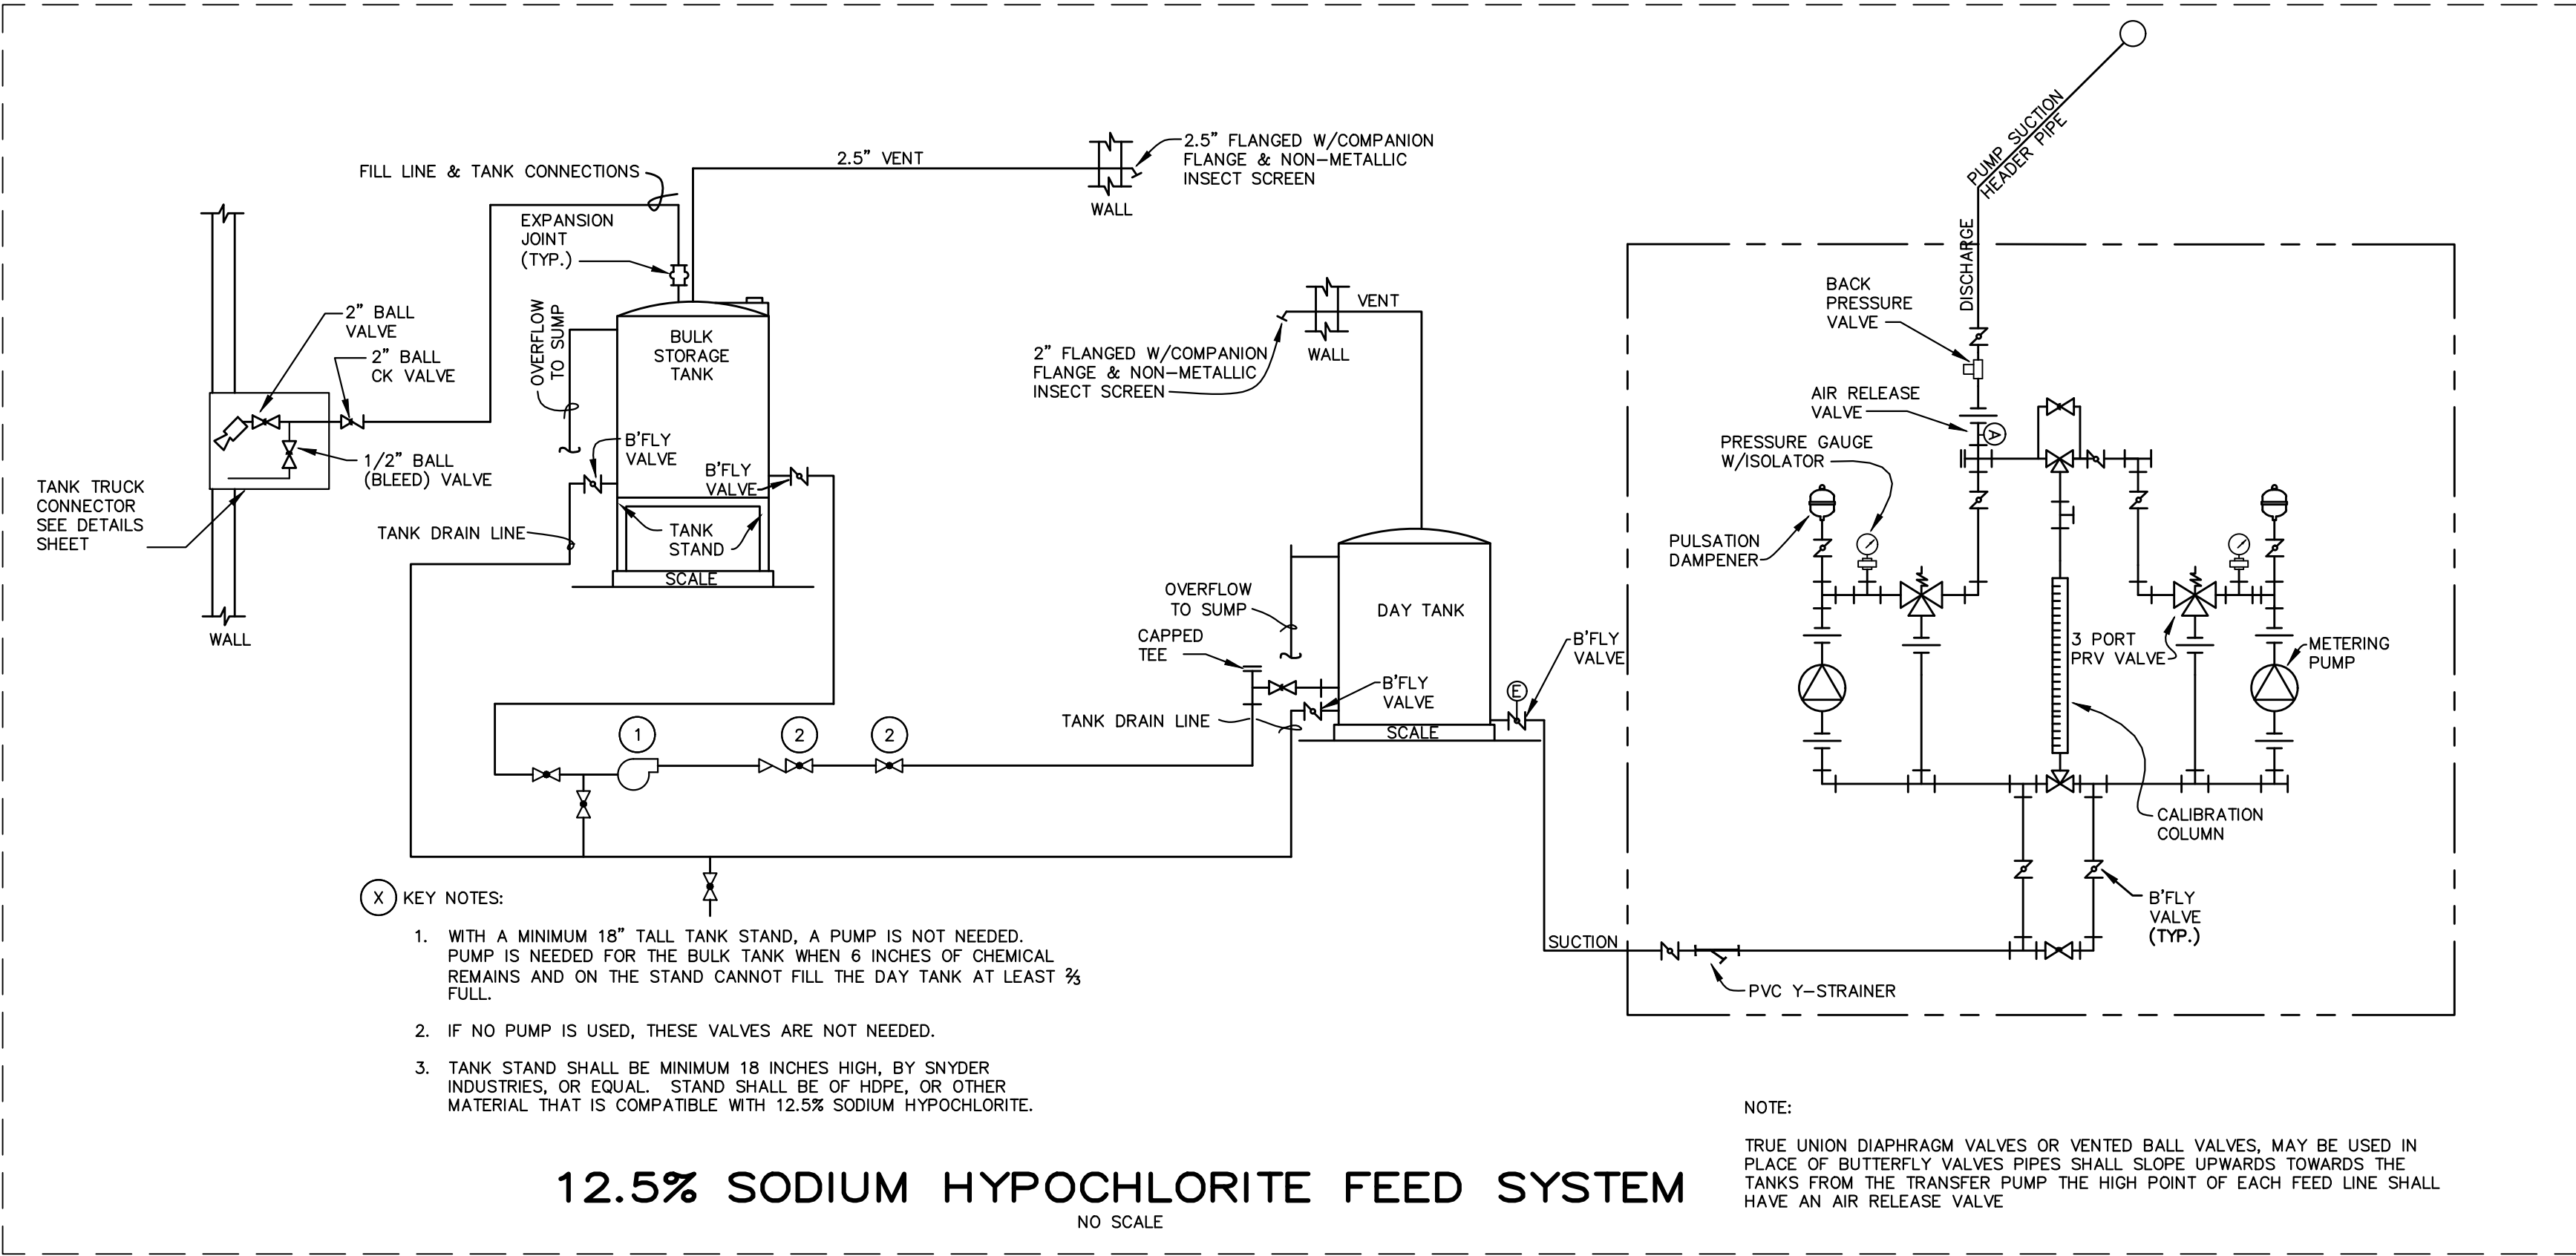

METERING PUMPS											
NO.	FEED SYSTEM PROVIDED BY	CHEMICAL SYSTEM	NOMINAL METERING PUMP OR FEEDER SUCTION / DISCHARGE LINE SIZE	MINIMUM PUMP DESIGN PRESSURE PSIG	NOMINAL FEED RATE GPH (mg/l)**	MINIMUM PUMP RATE SUPPLIED GPH**	MINIMUM NOMINAL TURNDOWN RATIO	NUMBER OF PUMPS SUPPLIED / INSTALLED	METERING PUMP OR EQUAL TO BE SUPPLIED	COMMENTS ¹	CHEMICAL SYSTEM
1	Contractor	12.5% Sodium Hypochlorite	3/8" /3/8"	45	*0.8 (2.0)	1,000	1000 : 1 .00	2 / 2	Watson-Marlow Qdos	The minimum pump output shall be no more than 0.004 gph	12.5% Sodium Hypochlorite
** The nominal feed rate of 2.0 mg/l at 1000 gpm (1.44 MGD) is equal to 0.7619 gph (18.29 GPD) and the nominal feed rate of 2.0 mg/l at 100 gpm is equal to 0.008 gph 1.829 GPD). The feed pump shall be able to handle these flows and everything in between.											

DAY/FEED TANKS											
NO.	TANK PROVIDED BY *	CHEMICAL SYSTEM	DAY TANK MINIMUM NOMINAL CAPACITY AND SIZE	DAY TANK MINIMUM USABLE ² VOLUME	DAY TANK MATERIAL OF CONSTRUCTION	DAY TANK LEVEL MEASUREMENT TYPE ⁴	I & C METERING PROVIDED BY	SIGHT GAUGE DISPLAY INCREMENTS (gal)	MINIMUM SCALE CAPACITY (lbs)	COMMENTS	CHEMICAL SYSTEM
1	Contractor	12.5% Sodium Hypochlorite	25 gallons (14" dia x 40" OTH)	19 gallons	HDPE	21-3/4" x 15-3/4" Scale	Contractor	N/A	0.2	Minimum scale capacity is 400 lbs	12.5% Sodium Hypochlorite
2											
¹ SS = Straight Side Height, OTH = Overall Tank Height ² The minimum usable volume is the volume in the straight side area of the tank minus volume lost to pump suction and overflow nozzle placement. ³ Sight gauge consisting of clear tube & valves or semi-transparent tank. ⁴ The scale size may increase if a day tank with a larger diameter is provided. The maximum tank diameter for this scale size (Force Flow WR400) is 19 inches.											

SUPPLY or BULK/MINI-BULK TANKS														
NO.	TANK PROVIDED BY	CHEMICAL SYSTEM OR TANK CONTENTS	STORAGE	BULK TANK MINIMUM NOMINAL CAPACITY AND SIZE	BULK TANK MAXIMUM USABLE VOLUME ^{1,2}	NUMBER OF TANKS	BULK TANK LEVEL MEASUREMENT TYPE	BULK TANK MATERIAL OF CONSTRUCTION	I & C METERING PROVIDED BY	BULK TANK FILL LINE SIZE & MATERIAL OF CONSTRUCTION	BULK TANK FILL CONNECTION SIZE & MATERIAL OF CONSTRUCTION	MINIMUM PIPE SIZE & MATERIAL BULK TANK TO TRANSFER PUMP	MINIMUM PIPE SIZE & MATERIAL TRANSFER PUMP TO DAY TANK	CHEMICAL SYSTEM OR TANK CONTENTS
1	Contractor	12.5% Sodium Hypochlorite	Mini-Bulk	110 gallons (32" dia x 41"H)	100	1	36" x 36" Scale	HDPE	Contractor	2" CPVC	2" - Male Camlock by Female Thread - Glass Filled Polypropylene	3/4" PVC	3/4" PVC	12.5% Sodium Hypochlorite
¹ The usable tank volume should be between 80 and 100 gallons. ² The minimum usable volume is the volume in the straight side area of the tank minus volume lost to pump suction and overflow nozzle placement.														


*CHEMICAL CHARACTERISTICS					
CHEMICAL*	NOMINAL SOLUTION STRENGTH PERCENT	SPECIFIC GRAVITY	VISCOSITY in CENTIPOISE @ 68 DEGREES FAHRENHEIT	pH	FREEZING POINT - DEGREES FAHRENHEIT
Coagulant - DelPac	100	1.23	*	2 - 3.5	-26.0
Coagulant - 1750 ION	100	1.3 - 1.35	*	3.0 - 4.0	22
Coagulant - Aluminum Sulfate (Alum)	49	1.335	23.00	2.4	2
Sodium Hydroxide	25	1.26	7.50	14.0	4.0
¹ Sodium Hypochlorite - 12.5%	12.5	1.27	*	13.0	-11.0
Carbon Slurry	17	1	*	6.75-7.25	32.0
Sodium Permanganate	20 - 40	1.16	*	5 - 8	24.8
Potassium Permanganate	3	1.05	1.00		
Hydrofluosilicic Acid	22 - 25	1.23	*	1.2	-4.0
Citric Acid	50	1.24	*	2.0	23.0
² Phosphoric Acid	75	1.69	2.4 - 9.4	1.08	0.50
Sodium Bisulfite	20 - 41	1.2 - 1.4	*	4.0 - 5.5	39.00
³ Hydrogen Peroxide - 7.5%	35	1.13	*	2.0 - 3.7	6 @ 20% to -27 @ 35%
PolyPhosphate		1.25		5.5 - 7 @ 1%	
* Data provided where available. Not all chemicals listed may be used in the project. ¹ Sodium Hypochlorite will be purchased as a nominal 12.5% solution and be diluted to roughly 6.25% solution on site. Data is for 12.5% unless noted otherwise. ² The pH of phosphoric acid is based on a 1 molar solution. ³ Hydrogen Peroxide will be purchased in 20% or 30% solution and diluted down to <8% on site. Data is for 35% unless otherwise noted.					

DESIGNER	DEG	DATE	BY	REVISION
DRAWN	LGL			
CHECKED	DEG			
APPROVED	DEG			

GRAPHIC SCALE	
SCALE: AS NOTED	

ALL RIGHTS RESERVED
THIS DOCUMENT IS THE PROPERTY OF BELL ENGINEERING AND SHALL NOT BE REPRODUCED IN WHOLE OR IN PART OR USED FOR CONSTRUCTION OF OTHER THAN THIS SPECIFIC PROJECT WITHOUT THE WRITTEN PERMISSION OF BELL ENGINEERING. FACSIMILES OF LICENSED PROFESSIONAL ENGINEER AND/OR LAND SURVEYOR SEALS, IF AFFIXED TO THIS DOCUMENT, SHALL BE CONSIDERED LEGITIMATE ONLY IF SIGNED AND DATED BY THE REGISTRANT.

Lexington, KY (859) 278-5412
Hopkinsville, KY (270) 886-5466
Somerset, KY (606) 485-4011

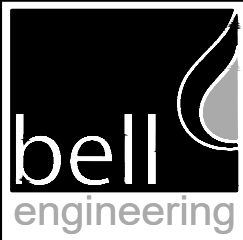


WATER SYSTEM IMPROVEMENTS
SHOPES CREEK ROAD AREA
CANNONSBURG WATER DISTRICT
CANNONSBURG, KENTUCKY


CHEMICAL FEED SCHEMATICS AND
CHEMICAL EQUIPMENT SCHEDULES

DIVISION	-
CONTRACT NO.	691-21-01
DATE	SEPTEMBER 2021
SHEET NO.	10 OF 17




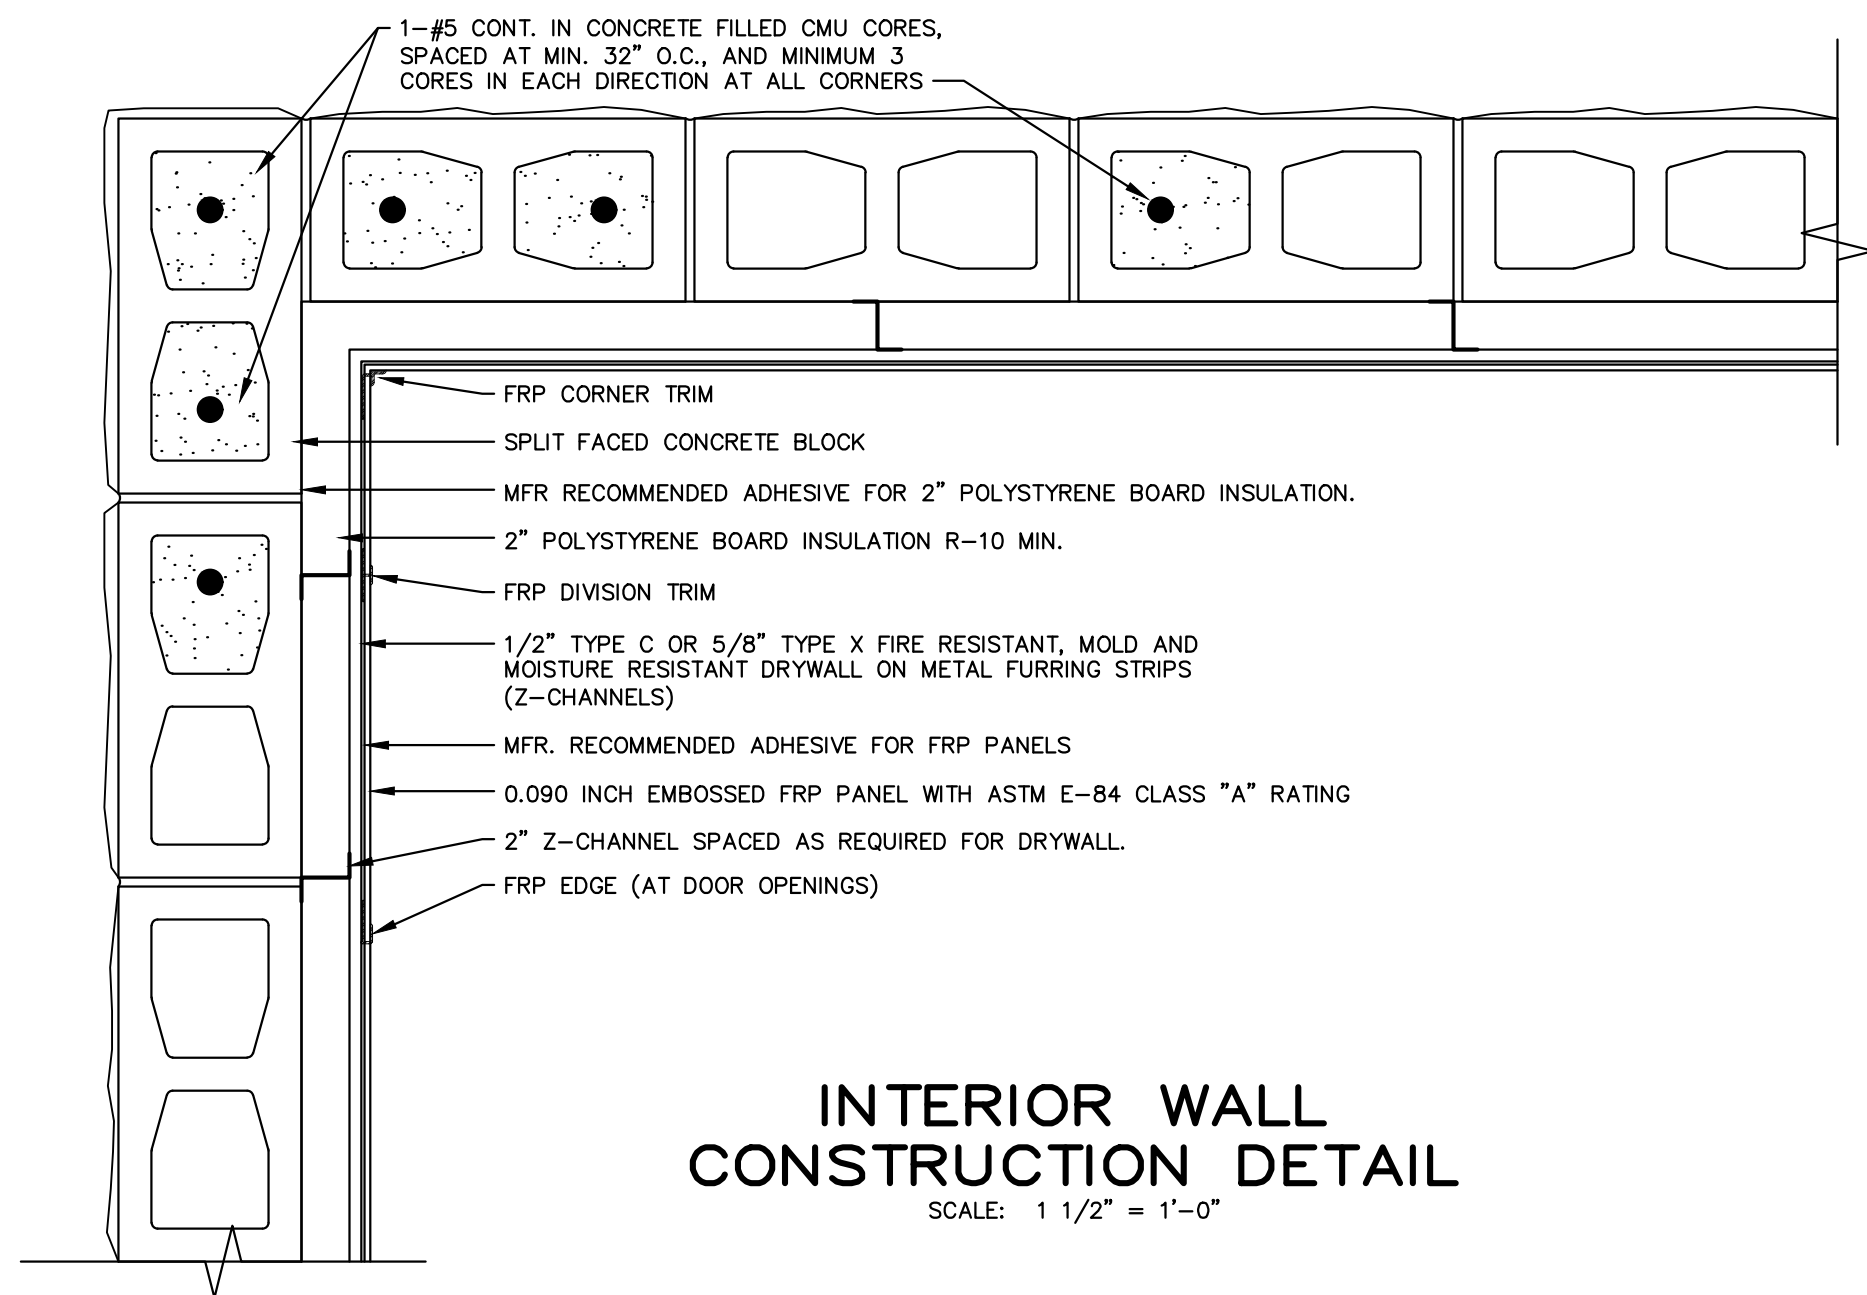

INTERIOR WALL
CONSTRUCTION DETAIL
SCALE: 1 1/2" = 1'-0"

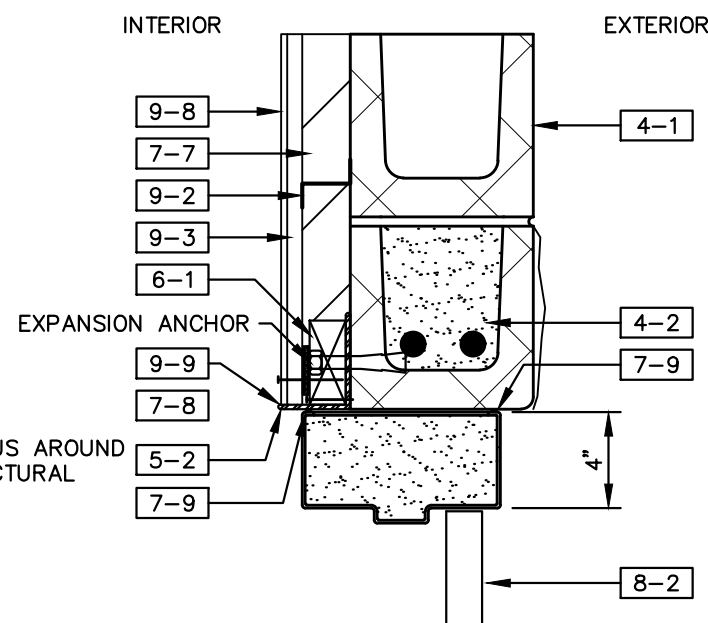

DOOR HEAD — EXTERIOR
SCALE: 1 1/2" = 1'-0"

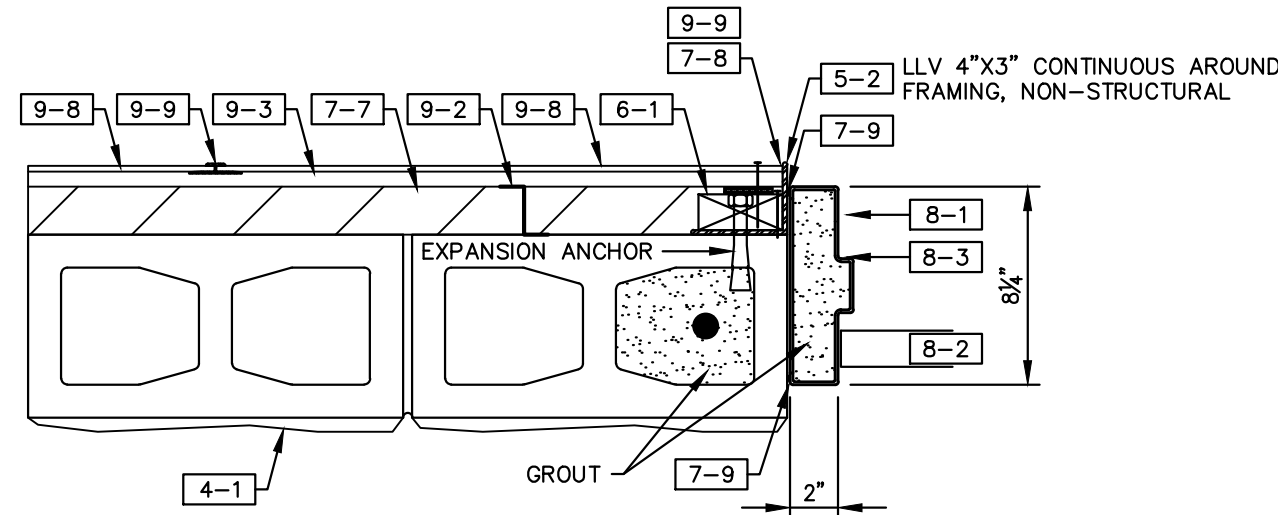

DOOR JAMB — EXTERIOR
SCALE: 1 1/2" = 1'-0"

KEYNOTE MATERIAL LEGEND

MASONRY 04000

- 4-1 CMU — 04200
4-2 BOND BEAM — SEE DETAIL, SHT. 12 — 04200

METALS 05000

- 5-2 STEEL ANGLE — SEE STRUCTURAL DWGS — 05120

WOOD AND PLASTICS 06000

- 6-1 PRESSURE TREATED WOOD BLOCKING — 06105

THERMAL AND MOISTURE PROTECTION 07000

- 7-7 EXTRUDED POLYSTYRENE — 07210
7-8 JOINT SEALANT — 07920
7-9 JOINT SEALANT W/ BACKER ROD — 07920


DOORS AND WINDOWS 08000

- 8-1 HOLLOW METAL FRAME — 08111
8-2 HOLLOW METAL DOOR — 08111
8-3 JAMB ANCHORS (3 PER JAMB) — 08111

FINISHES 09000

- 9-2 NON-STRUCTURAL 16GA METAL Z FURRING — 09221
9-3 GYPSUM BOARD — 09290
9-8 FRP WALL PANELS — 09770
9-9 FRP PANEL MOLDING AND TRIM — 09770



ACCEPTABLE MFR. PRODUCTS DESIGNATING THE QUALITY, TYPE, FUNCTION AND ETC..	
SIZE	3'-0" x 7'-2"
SINGLE DOOR AND FRAME	SEE SPECIFICATION SECTION 08220 FOR THE FRP DOOR AND FRAME REQUIREMENTS.
ENTRANCE LOCKSET	YALE — MORTISE — MONROE MOSL — (F04) — SL8807FL — US 32D W/ 4 KEYS & ARE KEYED PER OWNERS REQUEST
HINGE BUTTS	HAGER — MORTISE — BB1199 — 4 1/2"x 4 1/2" — US32D
THRESHOLD	NAT. GUARD PROD.—8424 — ALUMINUM
CRASH STOP	IVES — 115 — 25 1/2" LGTH. THRU BOLT FASTENING
FLUSH BOLT (TOP AND BOTTOM)	IVES — 458 — US26D
RAIN DRIP	NAT. GUARD PROD.—101AV — ANO. ALUM.
WEATHER—STRIPPING	NAT. GUARD PROD.—110NA — ANO. ALUM. (HEAD & JAMB)
SWEEP	NAT. GUARD PROD.—600 ANO. ALUM. & NYLON
MORTISE LOCK EXIT DEVICE	DETEX SERIES 30 — CYLINDER DOGGING

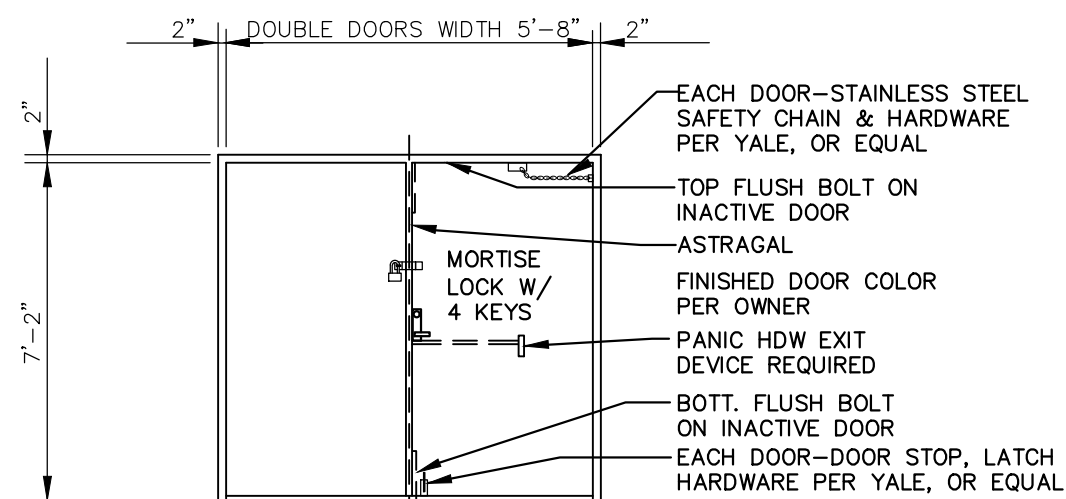


TYPE FF
DOUBLE DOORS (PR. DR.) W/FRAME
ELEVATION

DOOR FRAME AND HARDWARE SPECIFICATIONS:
DOOR SHALL BE HOLLOW METAL RESISTANCE TO HIGH IMPACT, HIGH FREQUENCY USE, CORROSION AND HEAT TRANSMISSION ARE THE GOVERNING FACTORS REQUIRING THE DOOR TO MEET DURABILITY STANDARDS OF THE STEEL DOOR INSTITUTE (SDI) STANDARD DATA SERIES ANSI/SDI A250.8 CLASSIFICATION TYPE III, MAXIMUM DUTY OR NAAMM STANDARD CHEM-1-74. DOOR SHALL HAVE PASSED AND SHALL MEET THE REQUIREMENTS OF ANSI STANDARD A250.4, TWIST TEST AND 1 MILLION CYCLE SWING TEST.


ACCEPTABLE MFR. PRODUCTS DESIGNATING THE QUALITY, TYPE, FUNCTION AND ETC..	
SIZE	5'-8" x 7'-2" RHR AND LHR ACTIVE
DOUBLE DOOR AND FRAME	CECO 1 3/4" IMPERIAL MAXIM (IU), 14 GAUGE HOT DIP GALV. STL. ASTM A924 AND A653, DOOR WITH MERCURY OR WEATHER KERF FRAME DOOR AND FRAME TO BE U FACTOR 0.091 R FACTOR: U FACTOR DOOR 0.38, R FACTOR DOOR 2.63 PER NFRC 102-2014 AND DEFINED BY NFRC 102-2014, ASTM C1199 AND ASTM C1363
ENTRANCE LOCKSET	YALE — MORTISE — MONROE MOSL — (F04) — SL8807FL — US 32D W/ 4 KEYS & ARE KEYED PER OWNERS REQUEST
HINGE BUTTS	HAGER — MORTISE — BB1199 — 4 1/2"x 4 1/2" — US32D
THRESHOLD	NAT. GUARD PROD.—8424 — ALUMINUM
CRASH STOP	IVES — 115 — 25 1/2" LGTH. THRU BOLT FASTENING
FLUSH BOLT (TOP AND BOTTOM)	IVES — 458 — US26D
STEEL ASTRAGAL	FURNISHED BY DOOR MANUFACTURER
RAIN DRIP	NAT. GUARD PROD.—101AV — ANO. ALUM.
WEATHER—STRIPPING	NAT. GUARD PROD.—110NA — ANO. ALUM. (HEAD & JAMB)
SWEEP	NAT. GUARD PROD.—600 ANO. ALUM. & NYLON
MORTISE LOCK EXIT DEVICE	DETEX SERIES 30 — CYLINDER DOGGING

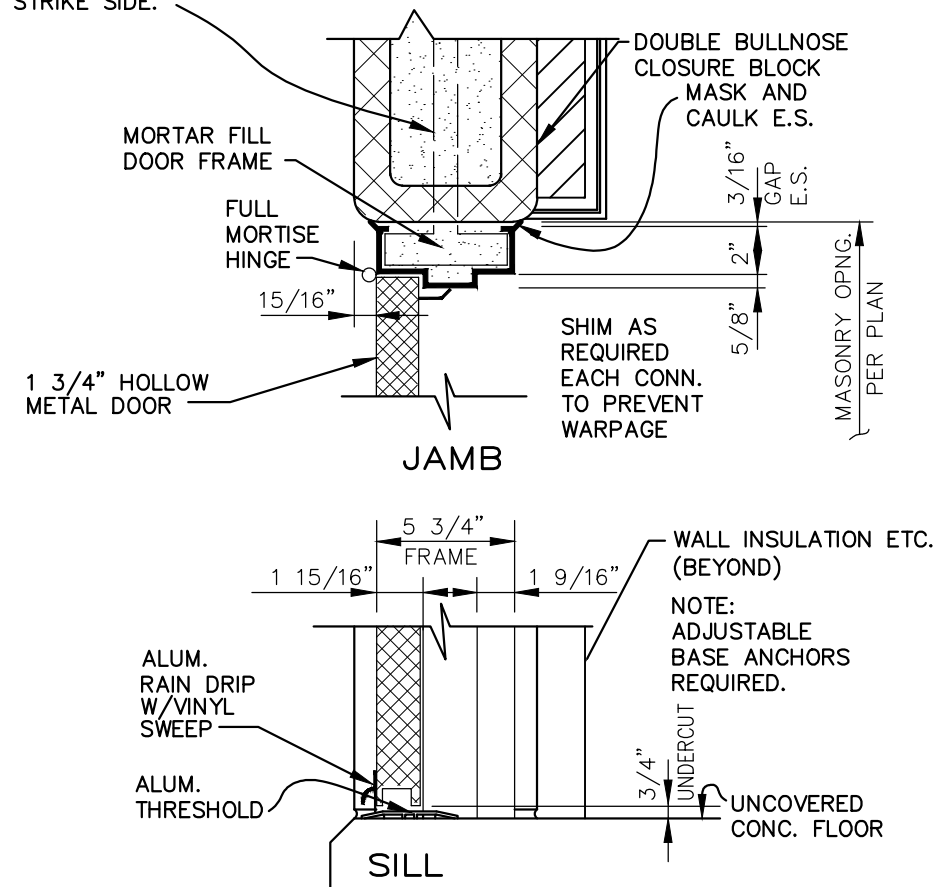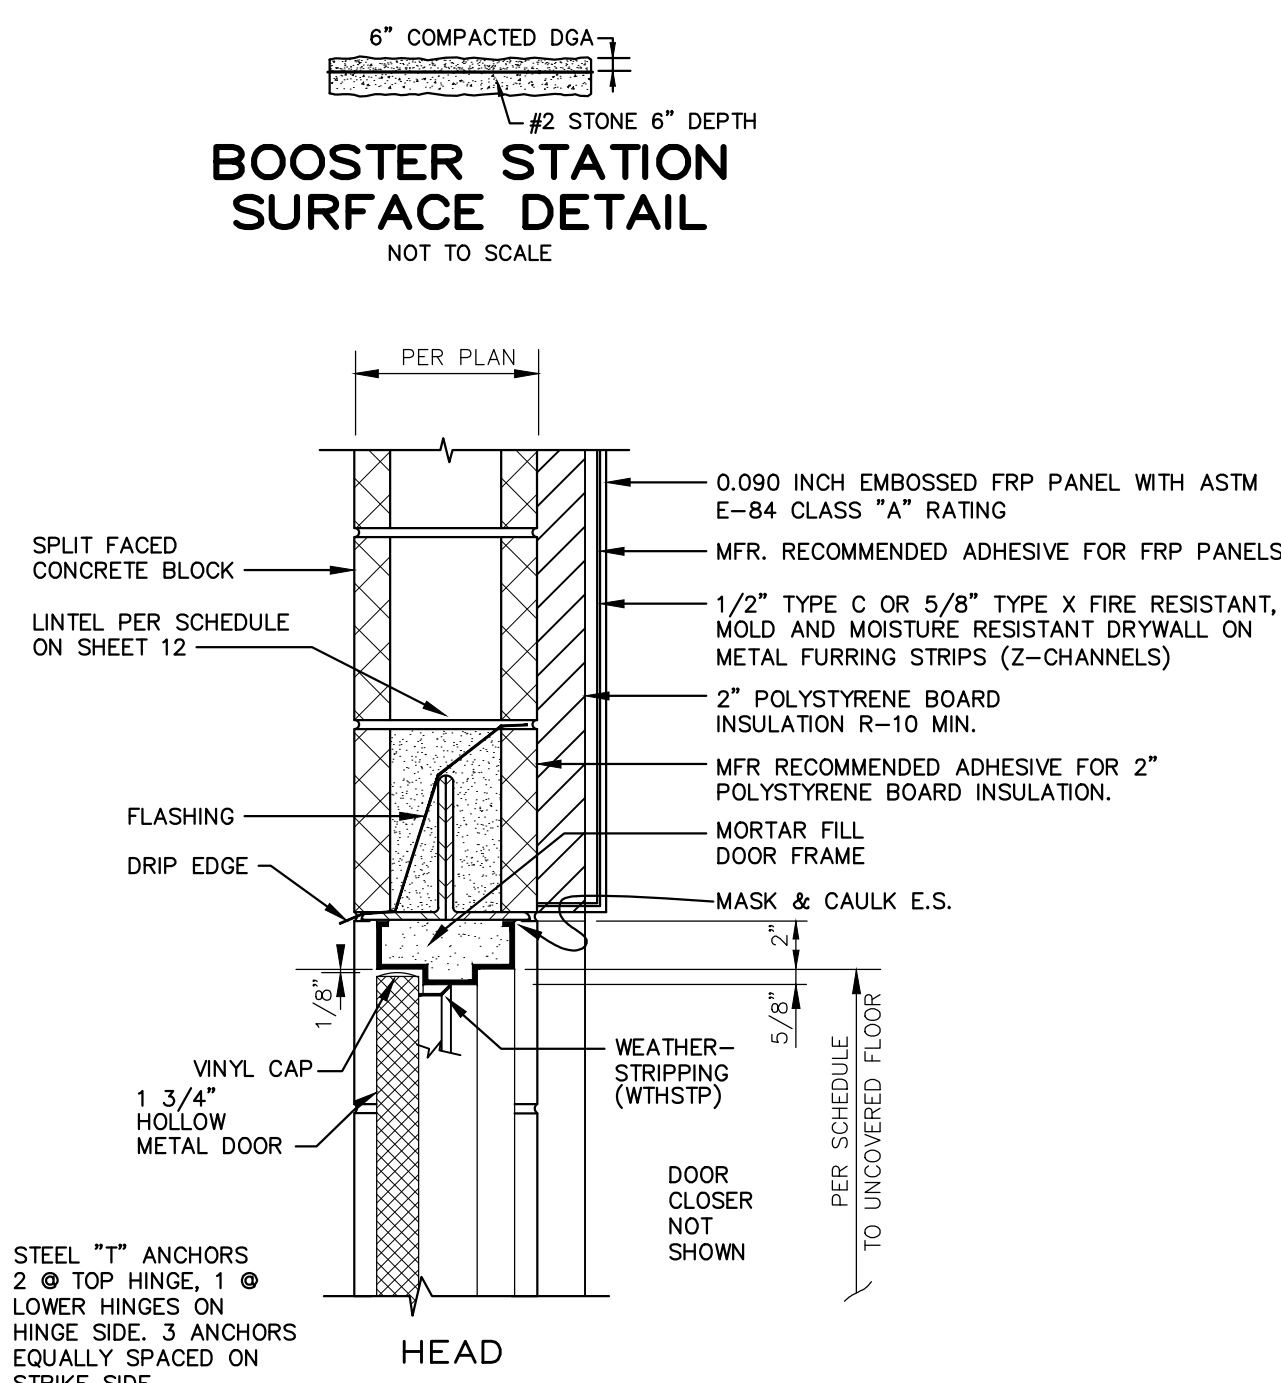


HOLLOW METAL DOOR
EXTERIOR DOOR SETTING
IN 8" CMU WALLS
SCALE: 1 1/2"=1'-0"

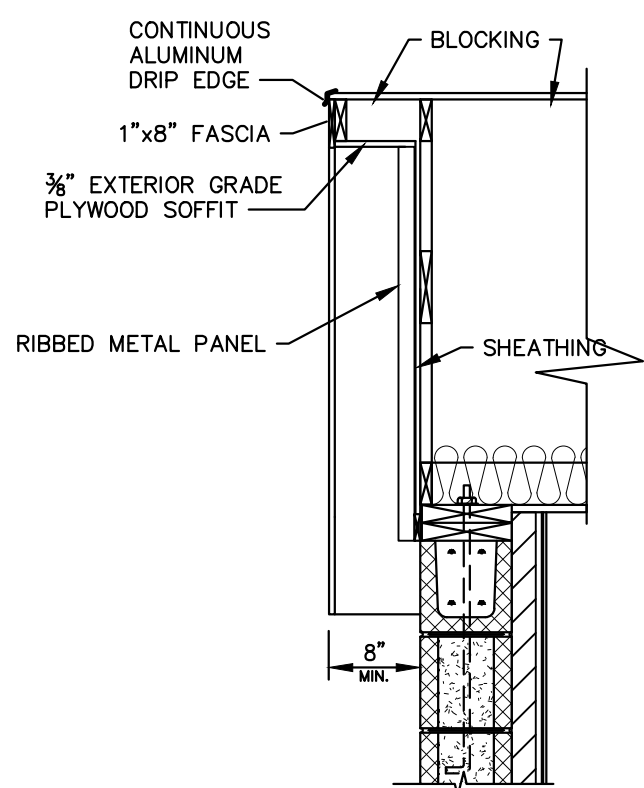


GABLE EDGE DETAIL
SCALE: 3/4" = 1'-0"

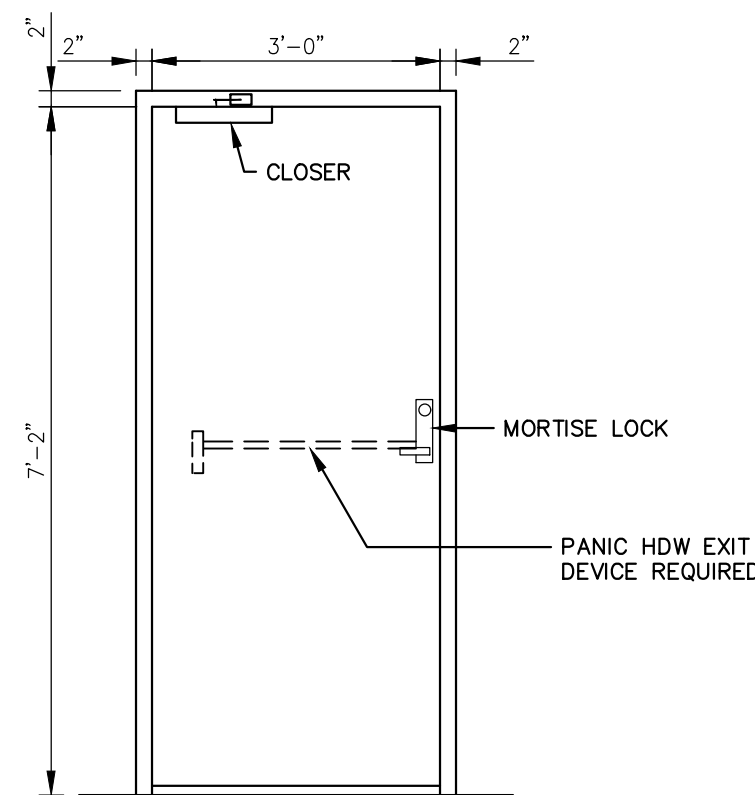


TYPE F
SINGLE DOOR WITH FRAME
NOT TO SCALE

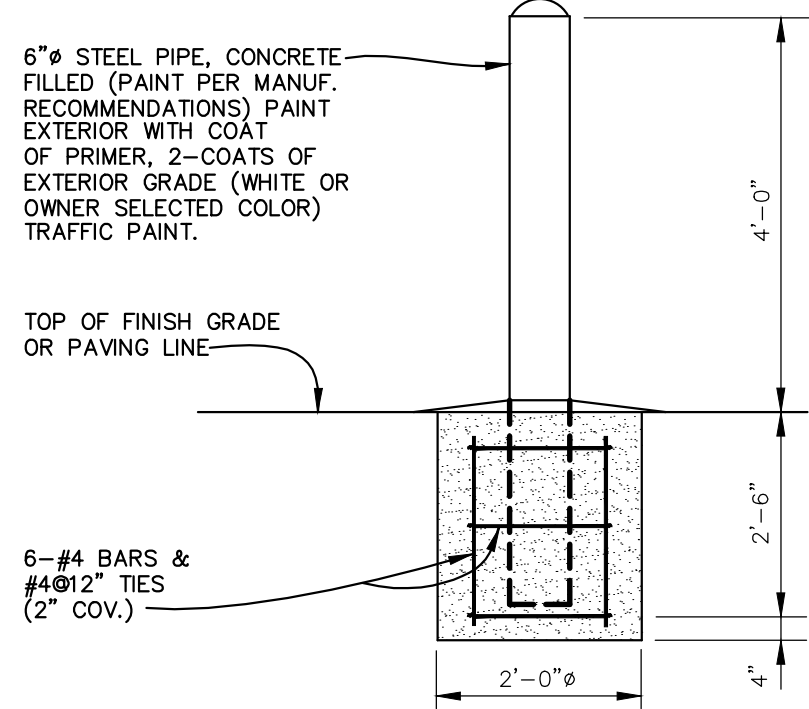


GUARD POST DETAIL
SCALE: 3/4"=1'-0"
(SEE PLAN VIEW)

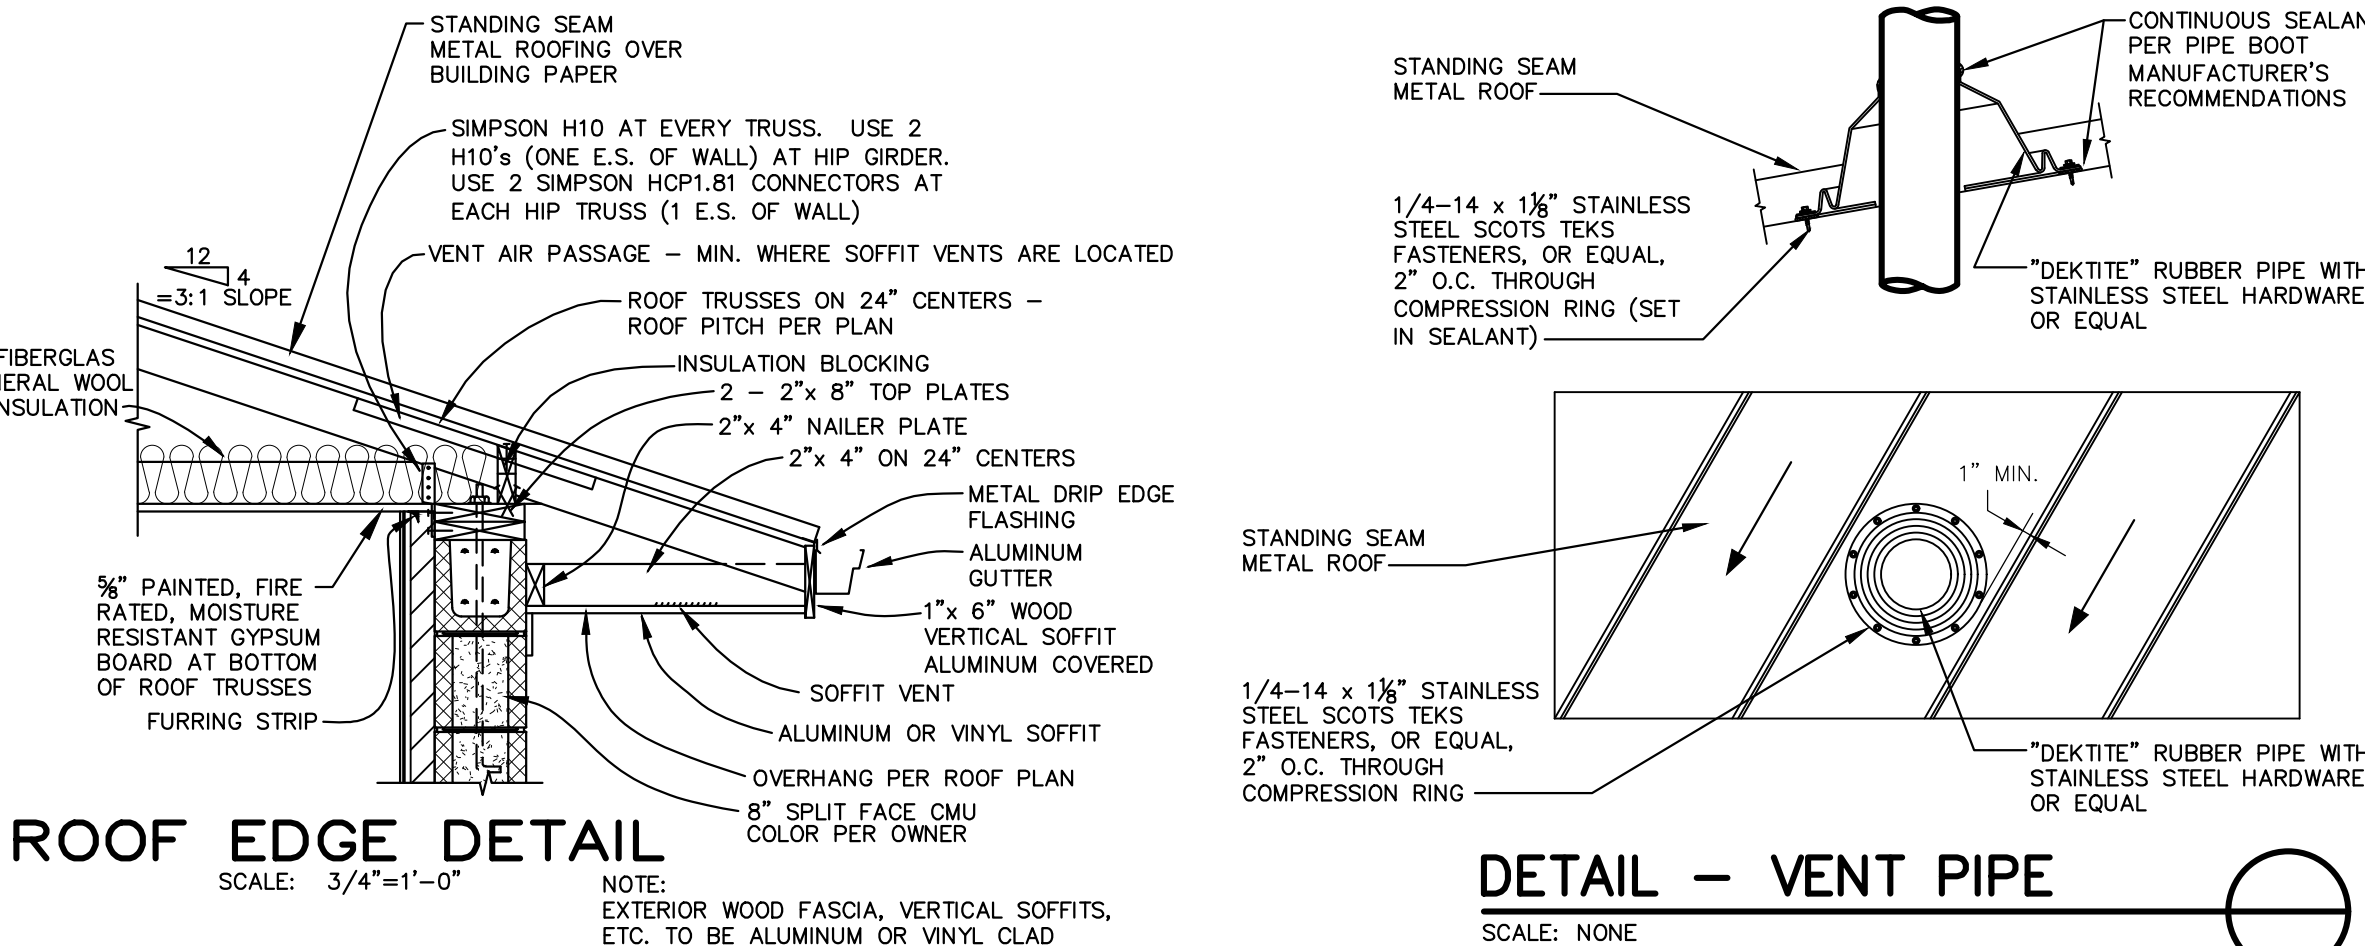

ROOF EDGE DETAIL
SCALE: 3/4"=1'-0"

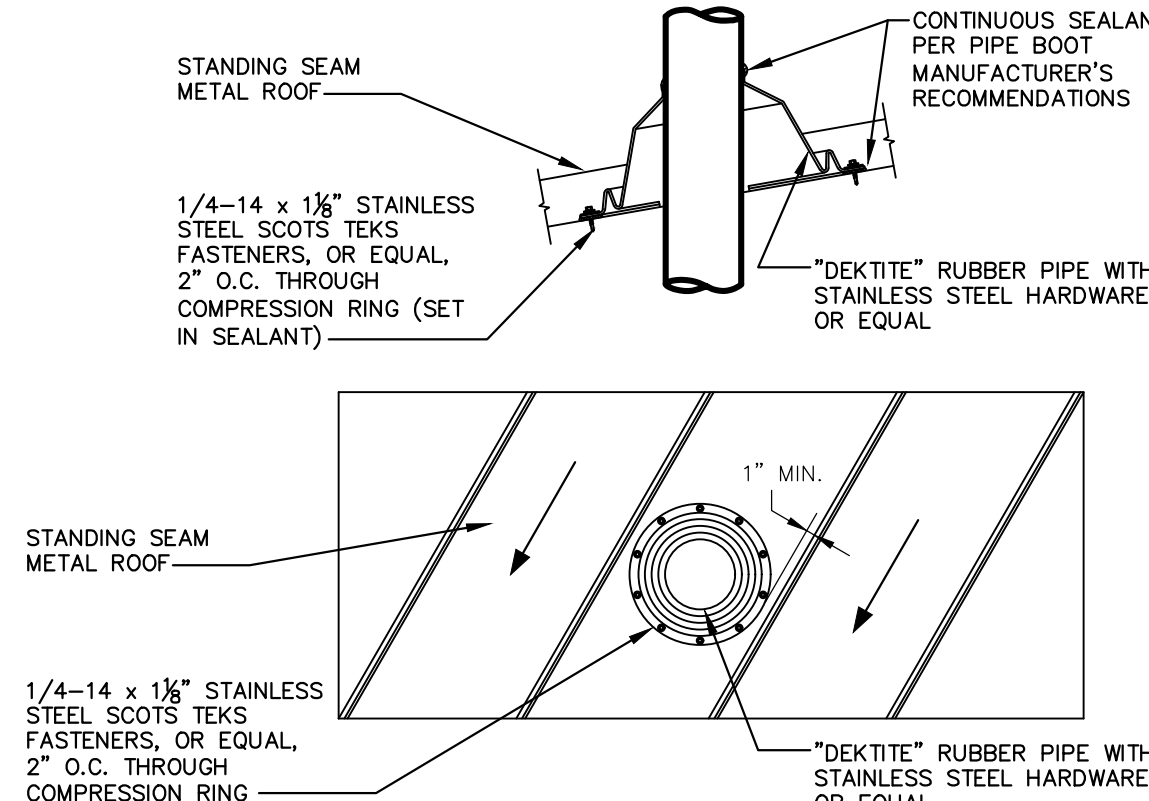

DETAIL — VENT PIPE
SCALE: NONE

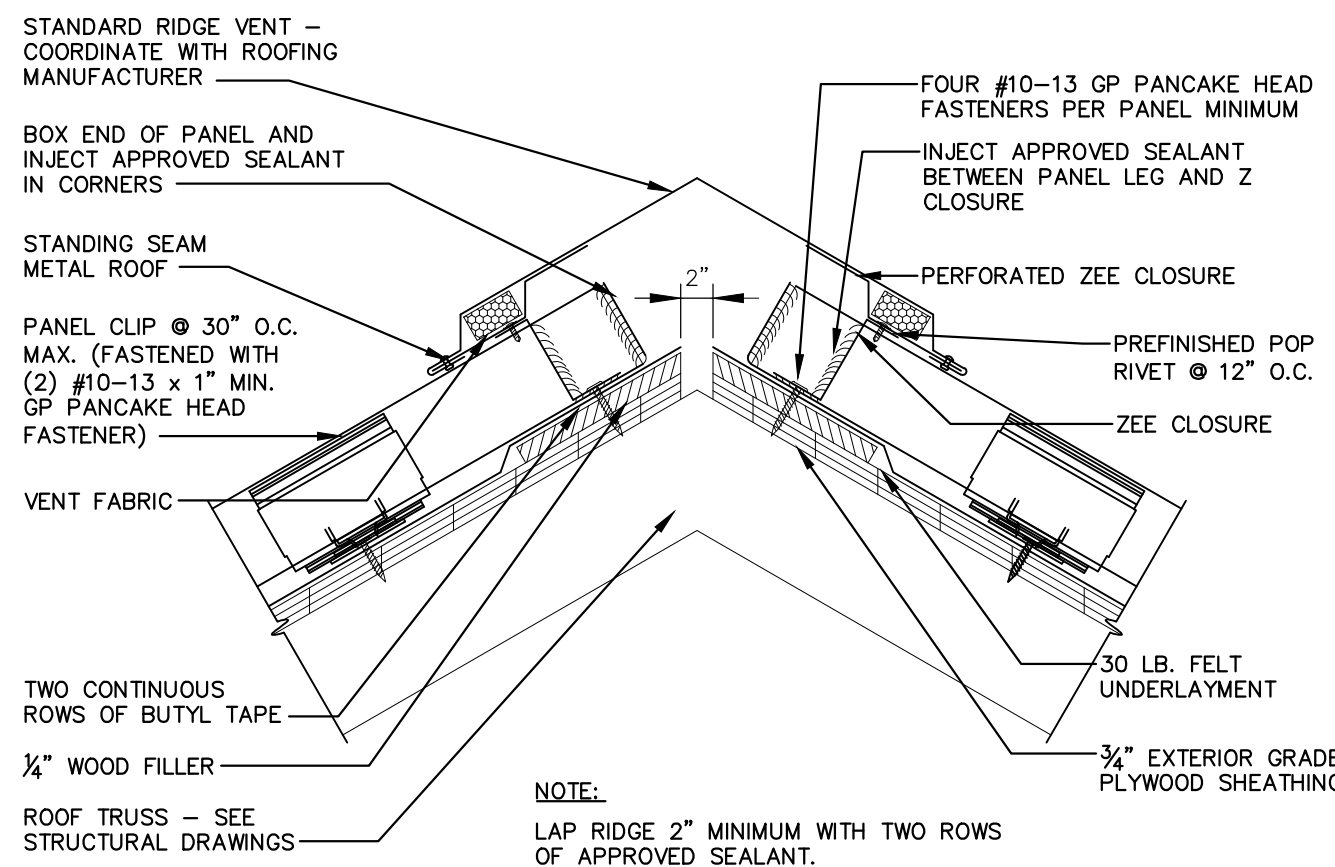

DETAIL — RIDGE VENT
SCALE: NONE

DESIGNER	DEG	DATE	BY	REVISION
DRAWN	LGL			
CHECKED	DEG			
APPROVED	DEG			

GRAPHIC SCALE	
SCALE:	AS NOTED


ALL RIGHTS RESERVED
THIS DOCUMENT IS THE PROPERTY OF BELL ENGINEERING AND SHALL NOT BE REPRODUCED IN WHOLE OR IN PART OR USED FOR CONSTRUCTION OF OTHER THAN THIS SPECIFIC PROJECT WITHOUT THE WRITTEN PERMISSION OF BELL ENGINEERING. FACSIMILES OF LICENSED PROFESSIONAL ENGINEER AND/OR LAND SURVEYOR SEALS, IF AFFIXED TO THIS DOCUMENT, SHALL BE CONSIDERED LEGITIMATE ONLY IF SIGNED AND DATED BY THE REGISTRANT.

Lexington, KY (659) 278-5412
Hopkinsville, KY (270) 886-5466
Somerset, KY (606) 485-4011

WATER SYSTEM IMPROVEMENTS
SHOPE'S CREEK ROAD AREA
CANNONBURG WATER DISTRICT
CANNONBURG, KENTUCKY


BOOSTER PUMP STATION
MISCELLANEOUS DETAILS

DIVISION	—
CONTRACT NO.	691-21-01
DATE	SEPTEMBER 2021
SHEET NO.	11 OF 17

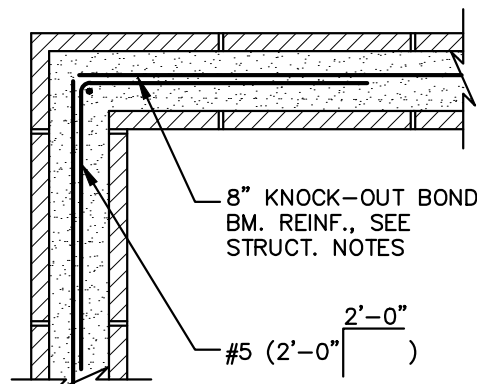


TYPICAL DETAIL @ BOND BEAM CORNERS

NOT TO SCALE

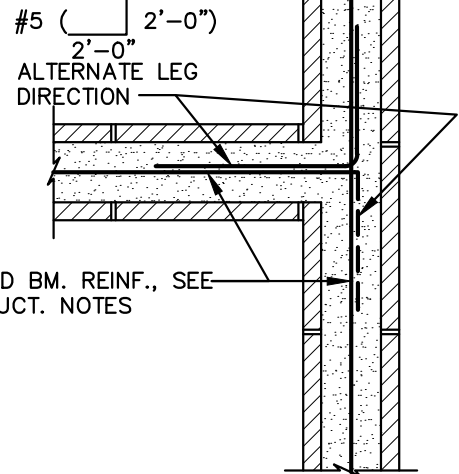


TYPICAL DETAIL @ BOND BEAM INTERSECTION, U.N.O.

NOT TO SCALE

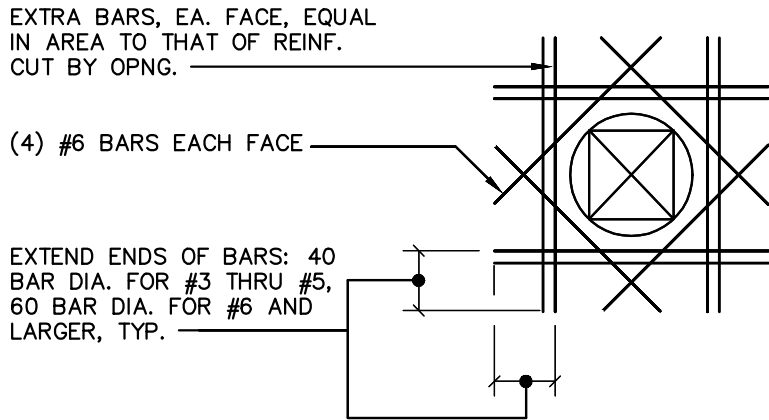


ADDITIONAL REINFORCING FOR SLAB/WALL OPENINGS

NOT TO SCALE

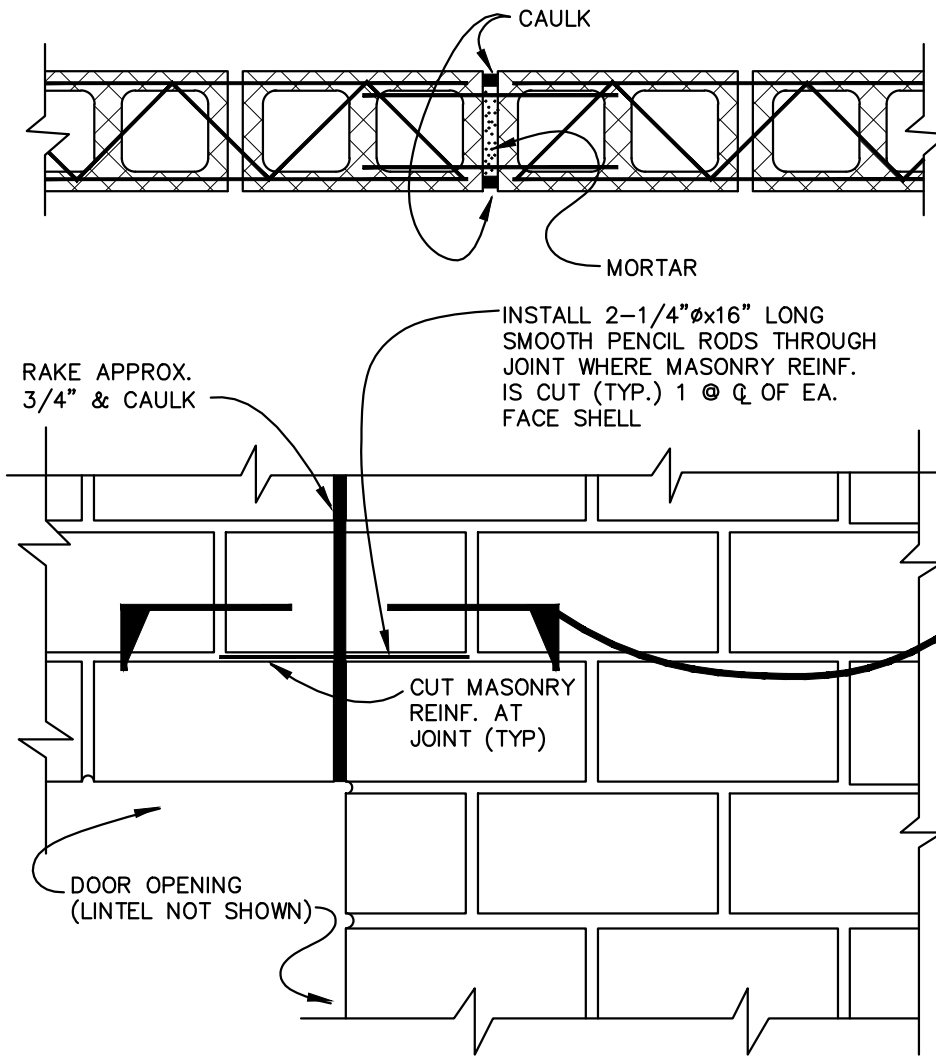


CONTROL JOINT AT DOORS

NOT TO SCALE

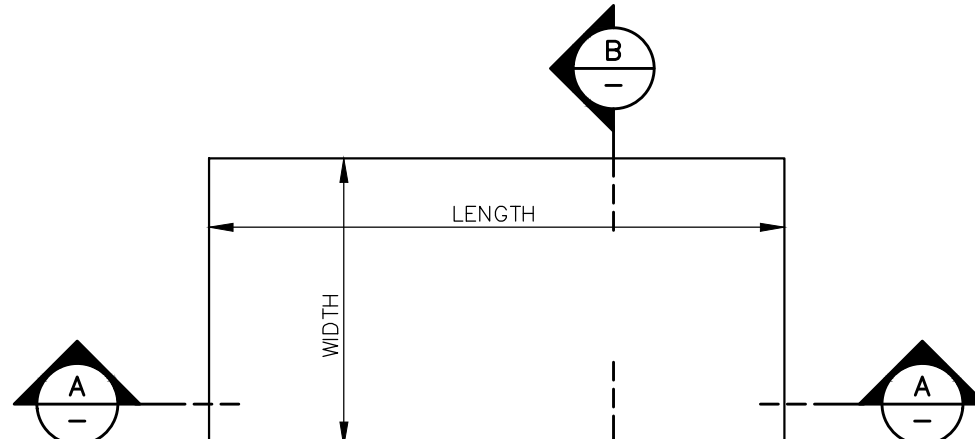

EQUIPMENT BASE PLAN

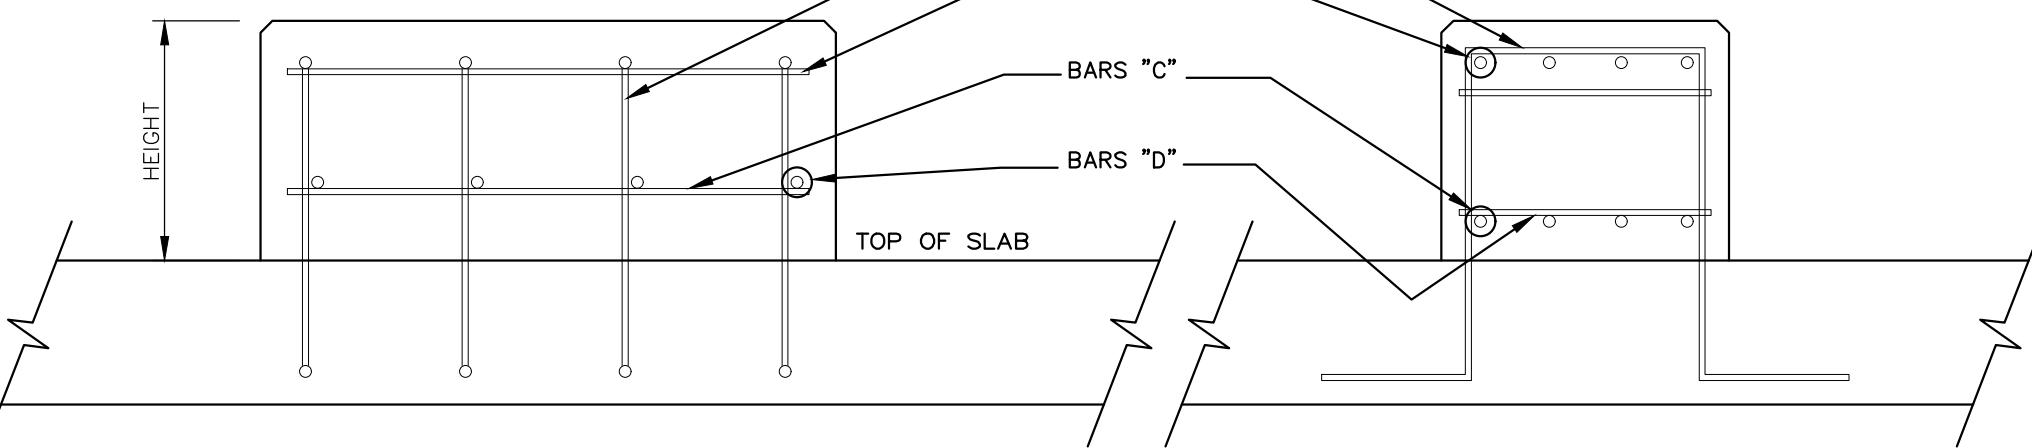

SECTION A

SECTION B

TYPICAL EQUIPMENT BASE REINFORCING

GENERAL STRUCTURAL NOTES


- CONTRACTOR NOTES
 - THE CONTRACT DRAWINGS REPRESENT THE DESIRED RESULT OF CONSTRUCTION. THE METHODS OF CONSTRUCTION AND THE RISKS INVOLVED DURING CONSTRUCTION SHALL BE THE RESPONSIBILITY OF THE CONTRACTOR. THE CONTRACTOR SHALL MAINTAIN THE STRUCTURAL INTEGRITY OF ALL STRUCTURES AT ALL STAGES OF CONSTRUCTION.
 - THE CONTRACTOR SHALL VERIFY ALL DIMENSIONS AND ELEVATIONS PRIOR TO CONSTRUCTION AND SHALL REPORT ANY DISCREPANCIES TO THE ENGINEER PRIOR TO COMMENCING ANY PERTINENT WORK.
 - ANY SUBSTITUTIONS PROPOSED BY THE CONTRACTOR SHALL BE APPROVED BY THE ENGINEER PRIOR TO COMMENCING ANY PERTINENT WORK.
 - LOAD-CARRYING STRUCTURAL COMPONENTS SHALL BE FABRICATED, CONSTRUCTED, AND INSTALLED IN ACCORDANCE WITH THE STRUCTURAL PLANS. IF THERE IS A DISCREPANCY OF DEPICTION OF A STRUCTURAL COMPONENT IN ANOTHER PLAN SECTION, THE STRUCTURAL PLANS SHALL CONTROL, UNLESS PRIOR WRITTEN AUTHORIZATION FROM THE ENGINEER IS PROVIDED.
 - ALL DEMOLITION DEBRIS SHALL BE REMOVED FROM SITE & DISPOSED OF AT NO ADDITIONAL COST TO THE OWNER UNLESS NOTED OTHERWISE.
 - ALL NECESSARY SHORING IS THE RESPONSIBILITY OF THE CONTRACTOR.
- MASONRY
 - ALL CONCRETE MASONRY UNITS (CMUS) SHALL BE OF LOAD-BEARING TYPE WITH A MINIMUM COMPRESSIVE STRENGTH OF $F'_m = 1,500$ PSI AT 28 DAYS. UNITS SHALL MEET THE CURRENT SPECIFICATION OF ASTM C90.
 - ALL WALLS WHICH ARE NOT EXPOSED TO EARTH OR WEATHER SHALL BE 2-CELL BLOCK, MADE OF LIGHTWEIGHT AGGREGATE. ALL WALLS WHICH ARE EXPOSED TO EARTH OR WEATHER SHALL BE 2-CELL BLOCK, MADE OF NORMAL-WEIGHT AGGREGATE.
 - ALL MORTAR FOR UNIT MASONRY SHALL COMPLY WITH THE REQUIREMENTS OF ASTM C270, TYPE S.
 - HORIZONTAL WIRE REINFORCING SHALL BE 9 GAUGE CONTINUOUS LADDER-TYPE UNITS, WHICH COMPLY WITH ASTM A82, AND SHALL BE SPACED AT 16" O.C.
 - PROVIDE A BOND BEAM AT THE TOP AND BOTTOM OF ALL LOAD-BEARING AND NON-LOAD BEARING CMU WALLS. IN EXTERIOR AND LOAD-BEARING WALLS, PROVIDE ADDITIONAL BOND BEAMS AT 4'-0" O.C. VERTICALLY. BOND BEAMS SHALL BE REINFORCED WITH 1-#4 CONTINUOUS BAR, UNLESS NOTED OTHERWISE.
 - VERTICAL REINFORCING SHALL BE OF SIZE AND SPACING PER PLAN, PLUS ONE ADDITIONAL BAR AT EACH DOOR/WINDOW JAMB (AND ABOVE AND BELOW DOOR/WINDOW OPENINGS), AND AT EACH BUILDING CORNER AND WHERE ADDITIONAL REINFORCING IS INDICATED.
 - SPLICES IN CONTINUOUS VERTICAL OR HORIZONTAL REINFORCING BARS SHALL BE PER ACI-308 OR 48 BAR DIAMETERS, WHICHEVER IS GREATER, UNLESS NOTED OTHERWISE. SPLICES SHALL BE CONTINUOUS OR SPLICED WITH DOWELS AT CORNERS.
 - FILL CELLS OF BLOCK AT VERTICAL REINFORCING AND WHERE INDICATED WITH CONCRETE, HAVING A MAXIMUM 3/8" LARGE AGGREGATE ("GROUT"), A MINIMUM COMPRESSIVE STRENGTH OF 2,500 PSI AT 28 DAYS, AND COMPLYING WITH ASTM C476.
 - ALL LOAD-BEARING CMU WALLS SHALL BE CONSTRUCTED SUCH THAT BLOCK IS INTERLOCKING AT ALL WALL CORNERS AND INTERSECTIONS. A VERTICAL COLD JOINT SHALL NOT BE PERMITTED AT THE JUNCTURE OF TWO LOAD-BEARING CMU WALLS. ALL NON-LOAD BEARING CMU WALLS SHALL BE CONSTRUCTED SUCH THAT THE BLOCK IS INTERLOCKING AT THE CORNER/ INTERSECTION OF AT LEAST ONE END OF THE WALL.
 - ALL WALL REINFORCEMENT THAT IS INTERRUPTED SHALL BE OFFSET AND CONTINUED IMMEDIATELY ADJACENT.

INFORMATION REQUIRED BY 2015 IBC / 2018 KBC SECTION 1603

1603.1.1	FLOOR LIVE LOAD	100 PSF UNIF / 2,000 LB CONC
2	WALKWAYS & STAIRS:	100 PSF UNIF / 300 LB CONC
1603.1.2	ROOF LIVE LOAD	
1	ALL ROOFED STRUCTURES:	20 PSF UNIF / 300 LB CONC
1603.1.3	ROOF SNOW LOAD DATA	
1	GROUND SNOW LOAD (P_g)	20 PSF
2	FLAT-ROOF SNOW LOAD (P_f)	15.1 PSF
3	SNOW EXPOSURE FACTOR (C_e)	0.9
4	SNOW LOAD IMPORTANCE FACTOR (I_s)	1.2
5	THERMAL FACTOR (C_t)	1.0
1603.1.4	WIND DESIGN DATA	
1	ULTIMATE DESIGN WIND SPEED (V_{ult})	120 MPH
2	RISK CATEGORY	IV
3	WIND EXPOSURE	C
4	INTERNAL PRESSURE COEFFICIENT (GC_{pi})	N/A (ENCLOSED SIMPLE DIAPHRAGM, LOW RISE)
5	DESIGN WIND PRESSURES	15.1 PSF (LATERAL) -19.1 PSF (VERTICAL)
1603.1.5	EARTHQUAKE DESIGN DATA	
1	RISK CATEGORY	IV
2	SEISMIC IMPORTANCE FACTOR (I_e)	1.50
3	MAPPED SPECTRAL RESPONSE ACCELERATION PARAMETERS:	
A.	S_s	0.162G
B.	S_1	0.076G
D.		
4	SITE CLASS	D
5	DESIGN SPECTRAL RESPONSE ACCELERATION PARAMETERS:	
A.	S_{ds}	0.173G
B.	S_{d1}	0.122G
C.		
6	SEISMIC DESIGN CATEGORY	C
7	BASIC SEISMIC FORCE-RESISTING SYSTEM:	
A.	BUILDING FRAME SYSTEM ORDINARY REINFORCED MASONRY SHEAR WALLS	
8	DESIGN BASE SHEAR (V_u)	0.130W
9	SEISMIC RESPONSE COEFFICIENT (C_s)	0.130
10	RESPONSE MODIFICATION COEFFICIENT (R)	2.0
11	ANALYSIS PROCEDURE USED:	EQUIVALENT LATERAL FORCE PROCEDURE (ELFP)
1603.1.6	GEOTECHNICAL INFORMATION	
1	ALLOWABLE BEARING CAPACITY	1,500 PSF
1603.1.7	FLOOD DESIGN DATA	NOT APPLICABLE
1603.1.8	SPECIAL LOADS	NOT APPLICABLE

SPECIAL INSPECTIONS

- THE SPECIAL INSPECTION AGENCY WILL BE LE GREGG ASSOCIATES | 2456 FORTUNE DRIVE, SUITE 155 | LEXINGTON, KENTUCKY | 40509 | (859) 252-7558 PHONE.
- THE FOLLOWING IS A PARTIAL LISTING OF OPERATIONS WHICH ARE SUBJECT TO SPECIAL INSPECTIONS, IN ACCORDANCE WITH 2015 IBC / 2018 KBC. THIS IS NOT INTENDED TO BE A COMPLETE LISTING, AS A THOROUGH OUTLINE IS PROVIDED IN THE IBC / KBC, AND IS HEREBY INCLUDED BY REFERENCE. ADDITIONAL INFORMATION IS ALSO INCLUDED IN SPECIFICATION SECTION 01420. SPECIAL INSPECTIONS SHALL BE REQUIRED FOR THE FOLLOWING TYPES OF WORK:
 - CONCRETE CONSTRUCTION: INCLUDING REINFORCEMENT, FORMWORK, DELIVERY, AND PLACEMENT.
 - MASONRY CONSTRUCTION: INCLUDING CMU WALLS AND ALL ASSOCIATED APPURTENANCES.
 - WOOD CONSTRUCTION: INCLUDING MEMBER SIZE AND PLACEMENT, VERIFICATION OF FABRICATOR APPROVAL, OBSERVATION OF ERECTION FOR PROPER TECHNIQUES.
 - SOILS: VERIFICATION AND INSPECTION OF SOILS, DENSITIES, LIFT THICKNESSES, AND DESIGN BEARING CAPACITIES.

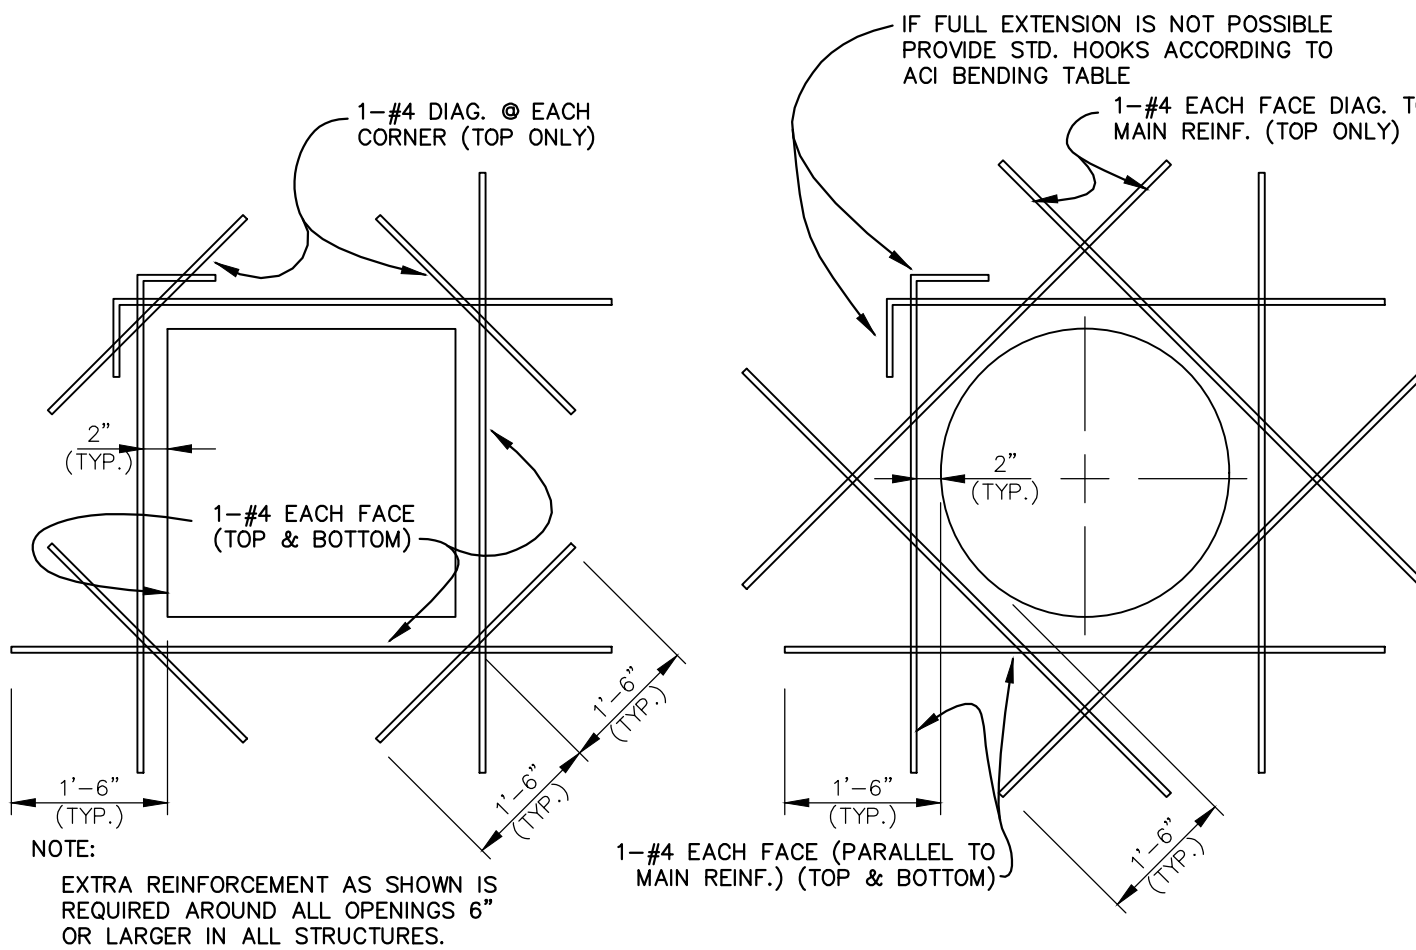

TYPICAL REINFORCEMENT AROUND OPENINGS IN WALLS & FLOORS

NOT TO SCALE

GENERAL NOTES FOR ROOF CONSTRUCTION:

- THE ROOF SHALL BE THE GABLE ROOF TYPE. TRUSSES SHALL BE PITCHED TYPE WITH 4:12 SLOPE (3" IN 12"). RAFTERS SHALL BE NOTCHED AT THE NAILER PLATE AND TOENAILED WITH TWO 10d NAILS EACH SIDE.
- PLYWOOD SHEATHING FOR ROOF SHALL BE EXTERIOR GRADE - APA RATED FOUR BY EIGHT FOOT SHEETS, 5/8 INCH THICK. PLY CLIPS SHALL BE PROVIDED BETWEEN EACH RAFTER. PROVIDE PREFORMED ALUMINUM BLOCKING FOR ALL EXPOSED ENDS OR EDGES. NAIL WITH 6d COMMON NAILS SPACED 6 INCHES APART ON THE EDGES AND 12 INCHES APART FOR INTERMEDIATE NAILING.
- PROVIDE PARTIAL HEIGHT BLOCKING AT NAILER PLATE BETWEEN CEILING JOISTS TO RETAIN INSULATION. INSULATION SHALL BE R-38.
- CONTINUOUS 0.025 INCH GAUGE WHITE ALUMINUM 4 INCH GUTTERING SHALL BE PROVIDED ON THE BUILDING WITH THE NUMBER OF DOWNSPOUTS AS SHOWN. GUTTERS SHALL BE HUNG USING BRACKET TYPE HANGERS. DOWNSPOUTS SHALL BE CORRUGATED RECTANGULAR TYPE MOUNTED WITH BRACKETS. GUTTER HANGERS SHALL BE 3 FT. O.C.
- SNOW GUARDS SHALL BE PROVIDED BETWEEN EACH METAL RIDGE.

TRUSS NOTES:

- PREFABRICATED ROOF TRUSSES SHALL BE DESIGNED IN ACCORDANCE WITH THE NATIONAL DESIGN SPECIFICATIONS FOR STRESS-GRADE LUMBER AND ITS FASTENINGS AS RECOMMENDED BY THE NATIONAL FOREST PRODUCTS ASSOCIATION.
- DESIGN TRUSS LOADINGS:
ROOF TRUSSES: TOP CHORD DEAD LOAD: 10 PSF
TOP CHORD LIVE LOAD: 20 PSF (SNOW)
BOTTOM CHORD DEAD LOAD: 10 PSF
WIND LOAD: 70 MPH
- TRUSS MANUFACTURER SHALL SUBMIT ERECTION PLAN AND SHOP DRAWINGS BEARING THE SEAL OF AN ENGINEER REGISTERED IN THE STATE OF KENTUCKY CONFORMING TO THE DESIGN CRITERIA SPECIFIED HEREIN FOR APPROVAL AND PRIOR TO FABRICATION. SUBMITTED DATA TO CONTAIN:
 - DESIGN LOADINGS AND ALLOWABLE STRESS INCREASES EMPLOYED
 - CALCULATED TRUSS MEMBER STRESSES
 - RATED LOAD CAPACITY OF THE TRUSS MEMBER CONNECTORS
 - SIZE, SPECIES AND STRESS-GRADE OF LUMBER EMPLOYED
 - FABRICATION DETAILS INDICATING LOCATIONS OF CONNECTORS
 - PERMANENT BRIDGING AND/OR BRACING LOCATIONS
 - HANDLING AND ERECTION INSTRUCTIONS
 - TRUSS TO TRUSS CONNECTION
- FAILURE TO FURNISH ANY OF THE ABOVE REQUIRED DATA WILL BE REGARDED AS AMPLE REASON FOR THE REJECTION OF THE SHOP DRAWINGS. THE CONTRACTOR SHALL APPROVE FABRICATION AND INSTALLATION DRAWINGS SHOWING SIZE, SHAPE AND LAYOUT PRIOR TO SUBMITTAL FOR REVIEW BY THE ENGINEER.
- CONNECTOR PLATES SHALL BE A MINIMUM OF 0.036" AND SHALL BE MANUFACTURED FROM MATERIAL MEETING THE REQUIREMENTS OF ASTM A446 GRADE A STEEL. PLATES SHALL BE GALVANIZED IN ACCORDANCE WITH ASTM A5252 G60 SPECIFICATIONS.
- TRUSS MEMBERS SHALL BE ACCURATELY CUT AND FABRICATED TO INSURE AMPLE MEMBER BEARING AND TRUSS UNIFORMITY WITHIN THE TOLERANCES ESTABLISHED BY THE "TRUSS PLATE INSTITUTE QUALITY CONTROL MANUAL COM-84"
- FOR TRUSSES OVER 35' SPAN, ALL LUMBER SHALL BE NO. 1 GRADE MINIMUM, INCLUDING THE WEBS.
- FOR TRUSSES UP TO 35' SPAN, ALL LUMBER SHALL BE NO. 2 GRADE MINIMUM.

MINIMUM NAILING SCHEDULE

- ALL NAILS SHALL BE COMMON WIRE NAILS. WHERE NAILS TEND TO SPLIT THE WOOD, HOLES SHALL BE SUBDRILLED. UNLESS OTHERWISE NOTED NAILING SHALL NOT BE LESS THAN THE FOLLOWING:
- JOISTS TO BEARING - TOE NAIL EA. SIDE 2 - 16d
DOUBLE JOISTS:
NOT BLOCKED APART - STAGGERED 16d @ 16"
BLOCKED APART - EA. BLOCK, EA. SIDE 2 - 16d
BLOCKING BETWEEN JOISTS:
TO BEARING - TOE NAIL EA. SIDE 2 - 16d
TO JOIST 10" IN DEPTH AND GREATER:
THRU NAIL, ONE END 3 - 20d
TOE NAIL EA. SIDE, OPP. END 3 - 16d
TO JOIST 8" IN DEPTH AND LESS:
THRU NAIL, ONE END 2 - 16d
TOE NAIL EA. SIDE, OPP. END 2 - 16d
BRIDGING TO JOISTS - TOE NAIL EA. END 2 - 8d
STUDS TO BEARING - TOE NAIL EA. SIDE 2 - 16d
MULTIPLE STUDS 16d @ 12" O.C.
CORNER STUDS AND ANGLES 16d @ 30" O.C.
DOUBLE TOP PLATE:
LOWER PLATE TO TOP OF STUD 3 - 16d
UPPER PLATE TO LOWER PLATE - STAGGERED 16d @ 18" O.C.
UPPER PLATE TO LOWER PLATE AT INTERSECTION 3 - 16d
PLATE TO JOIST OR BEARING 16d @ 16" O.C.
- 3/8" PLYWOOD SHEATHING 8d @ 6" O.C. @ PANEL EDGES
(HORIZONTAL OR VERTICAL) 8d @ 12" O.C. @ INTER. SUPPORTS
1/2", 5/8", OR 3/4" PLYWOOD SHEATHING:
10d @ 6" O.C. @ PANEL EDGES
10d @ 12" O.C. @ INTERMEDIATE SUPPORTS
- 1/4" PLYWOOD FOR SUB-FLOOR:
4d @ 4" O.C. @ PANEL EDGES
4d @ 8" O.C. @ INTERMEDIATE SUPPORTS
- FURRED CEILING:
2 x 2 HANGERS TO ROOF OR CEILING JOINTS 2 - 12d
1 x 4 FURRING STRIPS TO UNDERSIDE OF JOIST
EA. BEARING, ON STRAIGHT & ONE SLANT 2 - 8d


LINTEL SCHEDULE				
Nominal Masonry Size	Masonry Opening (M.O.) Width			
	>8" to 2'-0"	>2'-0" to 4'-0"	>4'-0" to 6'-0"	>6'-0" to 8'-0"
8" CMU	8"x8" HIGH LINTEL	8"x16" HIGH LINTEL w/ (1) #5	8"x16" HIGH LINTEL w/ (2) #5	8"x16" HIGH LINTEL w/ (2) #7

1. ALL LINTELS SHALL HAVE MIN. 8" BEARING AT EACH END.

2. PROVIDE LINTEL BLOCKS FOR LINTELS.

3. MASONRY LINTELS SHALL BE AS SPECIFIED, FILLED MONOLITHICALLY WITH GROUT. STEEL REINFORCEMENT SHALL BE PLACED AT BOTTOM OF LINTEL BLOCK WITH 2" MIN. COVER, AS SHOWN, UNLESS NOTED OTHERWISE.

4. CONTRACTOR SHALL COORDINATE WITH ARCHITECTURAL, MECHANICAL AND ELECTRICAL DRAWINGS TO PROVIDE LINTELS FOR OPENINGS NOT SHOWN.

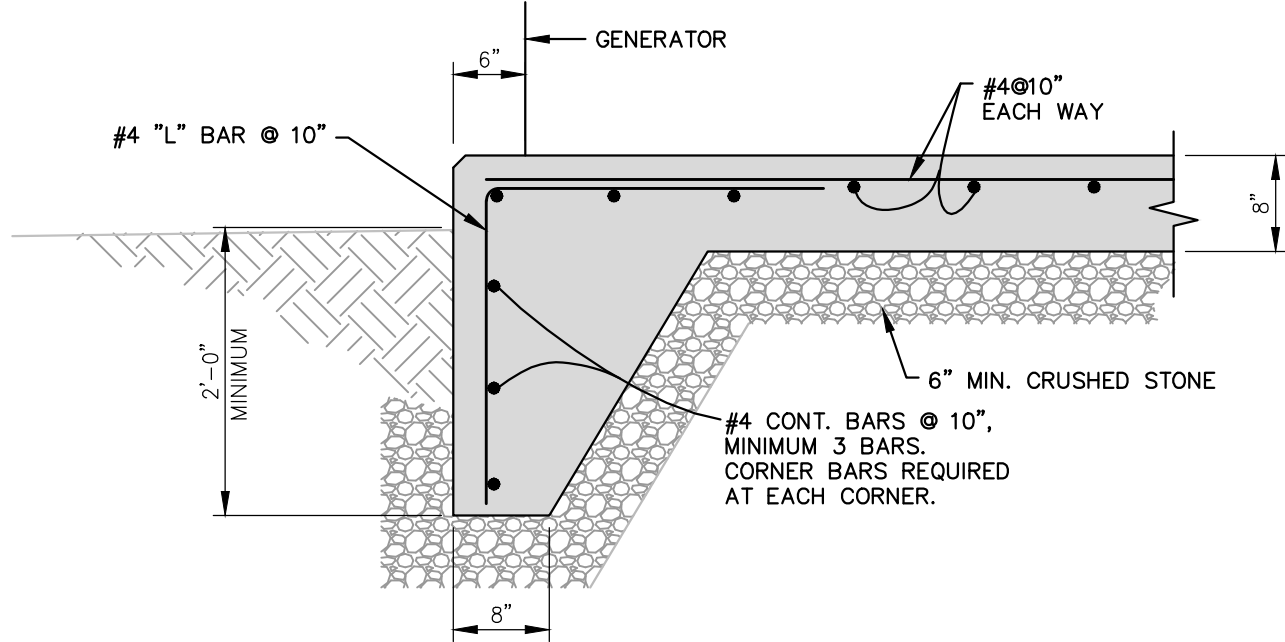

TYPICAL GENERATOR PAD DETAIL

NOT TO SCALE

DESIGNER	DMH	DATE	BY	REVISION
DRAWN	LGL			
CHECKED	DMH			
APPROVED	DMH			

GRAPHIC SCALE	
SCALE: AS NOTED	

ALL RIGHTS RESERVED

THIS DOCUMENT IS THE PROPERTY OF BELL ENGINEERING AND SHALL NOT BE REPRODUCED IN WHOLE OR IN PART OR USED FOR CONSTRUCTION OF OTHER THAN THIS SPECIFIC PROJECT WITHOUT THE WRITTEN PERMISSION OF BELL ENGINEERING.

FACSIMILES OF LICENSED PROFESSIONAL ENGINEER AND/OR LAND SURVEYOR SEALS, IF AFFIXED TO THIS DOCUMENT, SHALL BE CONSIDERED LEGITIMATE ONLY IF SIGNED AND DATED BY THE REGISTRANT.

Lexington, KY (859) 278-5412
Hopkinsville, KY (270) 886-5466
Somerset, KY (606) 485-4011

WATER SYSTEM IMPROVEMENTS
SHOPES CREEK ROAD AREA
CANNONBURG WATER DISTRICT
CANNONBURG, KENTUCKY

BOOSTER PUMP STATION
STRUCTURAL DETAILS

DIVISION	-
CONTRACT NO.	691-21-01
DATE	SEPTEMBER 2021
SHEET NO.	12 OF 17

J:\CANNONSURG\SHOPS CREEK ROAD AREA\CAD Design\09-69121\DWG\13.dwg, 13, 12/22/2024 11:00:27 AM, twebster, AutoCAD PDF (General Documentation).pc3

J:\CANNONSURG\SHOPS CREEK ROAD AREA\CAD Design\09-69121\DWG\13.dwg, 13, 12/22/2024 11:00:27 AM, twebster, AutoCAD PDF (General Documentation).pc3

PLOT SING: 000-BELL-STUDIO

GENERAL PIPING NOTES BPS

PROVIDE A LEAK FREE CONNECTION ANY PLACE WHERE PIPE TRANSITIONS FROM PVC TO COPPER OR PVC TO METAL. THE LEAK FREE CONNECTION SHALL CONSIST OF SOME FORM OF TRANSITION FITTING SUCH AS SPEARS MANUFACTURING COMPANY'S METAL-TO-PLASTIC TRANSITIONS, STRAUB PIPE JOINT OR EQUAL.

PROVIDE SCHEDULE 80 PVC PIPE FOR ALL CHEMICAL FILL, TRANSFER, AND FEED CARRIER PIPING EXCEPT FOR THE FOLLOWING: PROVIDE SCHEDULE 80 CPVC FOR THE SODIUM HYPOCHLORITE BULK TANK FILL PIPING. WHERE CHEMICAL LINES LEAVE BUILDINGS OR STRUCTURES AND TRAVEL UNDERGROUND IN COVER PIPES HDPE PIPE/TUBING MAY BE USED WHEN IT IS COMPATIBLE WITH THE CHEMICAL IT IS CARRYING. THE HDPE PIPE/TUBING SHALL BE ONE CONTINUOUS PIECE EXCEPT WHERE NOT POSSIBLE IN WHICH CASE THE NUMBER OF JOINTS SHALL BE KEPT TO A MINIMUM. THE NUMBER OF JOINTS SHALL BE KEPT TO A MINIMUM REGARDLESS OF THE TYPE OF PIPE USED WHEN PIPE IS RUN UNDERGROUND.

PROVIDE CLEAR SCHEDULE 40 PVC PIPE AND WHITE SCHEDULE 40 PVC FITTINGS FOR ALL CHEMICAL LINE COVER PIPE (SECONDARY CONTAINMENT PIPE) NOT UNDERGROUND. WHEN UNDERGROUND, COVER PIPE MAY BE SCHEDULE 80 PVC, SCHEDULE 80 CPVC, MINIMUM DR 9 HDPE, OR MINIMUM DR 9 PP. THE COVER PIPE MATERIAL USED SHALL BE COMPATIBLE WITH THE CHEMICALS IN THE CARRIER PIPES WHICH IT CONTAINS.

PROVIDE PVC, PVDF OR PTFE TUBING, AS APPROPRIATE FOR THE CHEMICAL, FOR THE LAST COUPLE FEET OF LINE JUST PRIOR TO AND AFTER METERING PUMPS AND FOR THE LAST COUPLE FEET OF CHEMICAL FEED LINE, JUST PRIOR TO CONNECTING TO THE FEED LOCATION(S).

PROVIDE A DRAIN PORT (TEE WITH THREADED PLUG) APPROXIMATELY EVERY 20 LINEAR FEET OF PIPE FOR THE SECONDARY (CONTAINMENT) PIPING OR AS RECOMMENDED BY THE DOUBLE CONTAINMENT PIPING MANUFACTURER, WHICHEVER IS SHORTER. PROVIDE A MINIMUM OF ONE DRAIN PORT, REGARDLESS OF LINE LENGTH.

PROVIDE A DOUBLE CONTAINED PIPING SYSTEM, UNLESS NOTED OTHERWISE, FOR ALL CHEMICAL LINES. TANK VENT AND OVERFLOW LINES DO NOT NEED TO BE DOUBLE CONTAINED. NON-PUMPED CHEMICAL LINES INSIDE CHEMICAL CONTAINMENT SUMPS WHERE THE CONTAINMENT WALLS ARE LESS THAN 6 FEET HIGH SHALL BE PROVIDED WITH DOUBLE CONTAINED PIPING OR OTHER ENGINEER APPROVED MEANS OF CHEMICAL SPRAY DEFLECTION TO PREVENT LEAKING CHEMICAL FROM LEAVING THE

CONTAINMENT SUMP. SPLASH CURTAINS ARE AN APPROVED MEANS OF SPRAY DEFLECTION. ALL CHEMICAL FEED LINES IN PIPE TRENCHES WITH SOLID COVERS DO NOT NEED TO BE DOUBLE CONTAINED.

PAINT/STENCIL THE COVER PIPE IN DOUBLE CONTAINED CHEMICAL LINES APPROXIMATELY EVERY 10 FEET AND AS NOTED IN SECTION 09800.

PROVIDE EXPANSION JOINTS, EXPANSION BENDS, STRAUB PIPE COUPLINGS, OR EQUAL DESIGNED FOR PIPE EXPANSION OR CONTRACTION, ETC., FOR ALL PLASTIC PIPE RUNS AS RECOMMENDED BY THE PIPE MANUFACTURER / SUPPLIER.

PROVIDE TYPE K OR TYPE L COPPER PIPE OR TUBING, AS SPECIFIED, FOR ALL POTABLE WATER, PLANT SERVICE WATER AND SAMPLE LINES 2.5 INCH AND SMALLER UNLESS SHOWN OTHERWISE ON THE DRAWINGS. PROVIDE DUCTILE IRON PIPE, AS SPECIFIED AND SHOWN ON THE DRAWINGS, FOR ALL POTABLE WATER AND PLANT SERVICE WATER LINES 3 INCHES AND LARGER. AS AN ALTERNATIVE, THREADED SCHEDULE 40 TYPE 304L/316L STAINLESS STEEL MAY BE USED FOR 2 INCH AND SMALLER WATER LINES AND SCHEDULE 10S TYPE 304L/316L STAINLESS STEEL PIPE MAY BE USED FOR 2.5 INCH AND LARGER WATER LINES.

WHERE STAINLESS STEEL PIPING IS SHOWN ON THE DRAWINGS, AS A MINIMUM, FLANGES SHALL BE PROVIDED WHERE SHOWN WHERE IT IS NOT SHOWN, FLANGES OR UNIONS, ETC., SHALL BE PROVIDED WHICH ALLOW FOR EASY REMOVAL OF VALVES, INSTRUMENTATION, ETC. FLANGES SHALL BE MADE OF 304L STAINLESS STEEL UNLESS ANOTHER MATERIAL IS NOTED OR SPECIFIED.

PROVIDE BOLTED DOWN DUCTILE IRON BASE FITTINGS WHERE BASE FITTINGS ARE CALLED FOR UNLESS NOTED OTHERWISE.

PROVIDE RED VALVE, SNYDER'S FLEXMASTER, GARLOCK OR EQUAL EXPANSION JOINTS FOR ALL PIPING CONNECTIONS TO PLASTIC OR FRP TANKS AND RED VALVE, PROCO, GARLOCK OR EQUAL EXPANSION JOINTS TO ALL PUMPS. THE EXPANSION JOINTS MATERIAL OF CONSTRUCTION SHALL BE COMPATIBLE WITH THE LIQUID FLOWING THROUGH THE LINE. THE EXPANSION JOINT SHALL AS A MINIMUM HAVE A PRESSURE RATING OF 50 PSI AND A VACUUM RATING OF 15 INCHES OF MERCURY WHEN USED ON TANKS OR PUMP SUCTION LINES AND A MINIMUM PRESSURE RATING OF 150 PSI WHEN USED ON PUMP DISCHARGE LINES UNLESS NOTED OTHERWISE. ALL EXPANSION JOINTS USED ON PUMP SUCTION AND DISCHARGE PIPING SHALL INCLUDE CONROL RODS/UNITS OR THE PIPING SHALL BE OTHERWISE RESTRAINED

AS REQUIRED BY THE EXPANSION JOINT SUPPLIER.

FOR WATER PIPES THROUGH CONCRETE WALLS, PROVIDE PIPES GROUTED IN PLACE UNLESS NOTED OR SHOWN OTHERWISE SUCH AS TO USE LINK SEALS OR EQUAL. IF THE PIPE IS TO BE FORMED IN THE WALL WHEN POURED IT SHALL HAVE A CONTINUOUSLY WELDED OR OTHERWISE ATTACHED WATER STOP AROUND THE FULL CIRCUMFERENCE OF THE PIPE IF THE PIPE IS UNDERGROUND OR IN A WATER HOLDING BASIN OR TANK WHERE WATER COULD PASS THROUGH THE WALL.

PROVIDE COVER PIPE WITH LINK SEALS OR EQUAL OR PIPING SPACERS FOR ALL CHEMICAL LINES THROUGH CONCRETE WALLS AS APPROPRIATE. PROVIDE LINK SEALS OR EQUAL UNLESS SHOWN OTHERWISE, BETWEEN THE CARRIER PIPE AND THE COVER PIPE FOR ALL CHEMICAL PIPES TRAVERSING FROM INDOORS TO OUTDOORS OR VICE VERSA.

WHERE LINK-SEALS OR EQUAL ARE SHOWN OR CALLED FOR GROUT SHALL NOT BE USED TO FILL THE ANNULAR SPACE AROUND THE PIPE UNLESS THE CAVITY LEAKS WATER AND ALL POSSIBLE ADJUSTMENTS TO THE LINK-SEALS OR EQUAL HAVE BEEN MADE. IF THE CAVITY IS FOUND TO LEAK WATER PRIOR TO OR DURING THE WARRANTY PERIOD THE CONTRACTOR SHALL ADJUST THE LINK-SEAL(S) OR EQUAL TO FIX THE PROBLEM. IF IT IS DETERMINED THAT THE LINK-SEAL OR EQUAL ALONE CANNOT ELIMINATE THE LEAK, THE CONTRACTOR SHALL PLACE NON-SHRINK GROUT IN THE CAVITY.

ALL CHEMICAL FEED LINES THAT END WITH A CONNECTION TO A PIPE SHALL HAVE AN INJECTION QUILL. PROVIDE INJECTION QUILLS WITH SAF-T SEAL ELASTOMERIC TIPS FOR SODIUM HYPOCHLORITE LINES. INJECTION QUILLS SHALL EXTEND IN MINIMUM OF ONE THIRD (1/3) OF THE WAY INTO THE PIPE BUT HALF WAY IS PREFERRED. SEE THE CHEMICAL INJECTION QUILL OR DIFFUSER PIPE DETAIL ON THE DRAWINGS FOR MORE INFORMATION. INJECTION QUILLS AND DIFFUSER PIPES SHALL BE RETRACTABLE UNITS OF PVC OR CPVC AS MANUFACTURED BY SAF-T-FLO OR EQUAL FOR PIPES 12 INCHES IN DIAMETER AND SMALLER. WHERE PIPES ARE LARGER THAN 12 INCHES IN DIAMETER, THE IN-PIPE VELOCITY IS GREATER THAN 6 FEET PER SECOND THE DIFFUSER PIPES SHALL BE METALLIC AND COMPATIBLE WITH THE CHEMICAL BEING FED.

WHERE TAPS ARE REQUIRED, THEY CAN BE MADE DIRECTLY INTO DUCTILE IRON PIPE WHEN THE TAP IS 1 INCH OR SMALLER AND WHEN THE TAP IS LARGER THAN 1 INCH OR INTO OTHER PIPE MATERIALS. TAPPING SADDLES/SERVICE CLAMPS SHALL BE USED. TAPS MADE DIRECTLY INTO DUCTILE IRON PIPE SHALL USE 2 LAYERS OF THREAD SEALANT TAPE WITH THE CORPORATION STOP, ETC., TIGHTENED TO A MINIMUM 30 FT-LBF OF TORQUE OR TO A HIGHER TORQUE VALUE IF NEEDED TO PREVENT

LEAKAGE. TAPPING SADDLES SHALL BE MANUFACTURED SPECIFICALLY FOR USE WITH THE PIPE UPON WHICH IT IS TO BE INSTALLED. SERVICE CLAMPS FOR USE ON DUCTILE IRON PIPE SHALL BE BRONZE, DOUBLE STRAP, MUELLER BR2B SERIES, FORD OR EQUAL FOR SERVICE/FEEDER LINES CARRYING WATER, AND FOR SERVICE/FEEDER LINES CARRYING CHEMICALS THE SERVICE SADDLE SHALL BE STAINLESS STEEL, MINIMUM TYPE 304/304L AS MANUFACTURED BY ROMAC INDUSTRIES SERIES 300, FORD, SMITH-BLAIR, OR EQUAL. SERVICE CLAMPS ON PVC AND POLYETHYLENE PIPE SHALL BE BRONZE WIDE STRAP, 2 PIECE FOR 2 THROUGH 8-INCH MAINS MUELLER H-01300 SERIES AND FOR 10 INCH AND LARGER, 3 PIECE MUELLER H13000 SERIES, FORD, OR EQUAL FOR SERVICE/FEEDER LINES CARRYING WATER AND FOR SERVICE/FEEDER LINES CARRYING CHEMICALS THE SERVICE SADDLE SHALL BE AS NOTED FOR DUCTILE IRON PIPE. FOR TAPS 4 INCH AND LARGER TAPPING SLEEVES OF STAINLESS STEEL WITH A PRESSURE RATING OF 150 PSI OR AS NEEDED FOR THE LINE TO BE TAPPED SHALL BE PROVIDED AS MANUFACTURED BY ROMAC INDUSTRIES, FORD, SMITH-BLAIR, OR EQUAL OR OF DUCTILE IRON RATED FOR 250 PSI THROUGH 24 INCH AS MANUFACTURED BY AMERICAN FLOW CONTROL SERIES 2800, OR EQUAL.

PIPES LEAVING STRUCTURES SHALL HAVE JOINTS LOCATED APPROXIMATELY WHERE SHOWN. THE CONTRACTOR MAY PLACE A JOINT CLOSER TO THE STRUCTURE'S WALL IF THE JOINT LOCATION IS NOT DIMENSIONED OR OTHERWISE NOTED WITH THE MINIMUM DISTANCE FROM THE WALL BEING 6 INCHES UNLESS WALL PIPE IS USED.

ALL PLANT WATER, POTABLE WATER, SAMPLE PIPING AND CHEMICAL SYSTEM PIPING AND APPURTENANCES INCLUDING TUBING SHALL BE DESIGNED TO HAVE A MAXIMUM OPERATING/WORKING PRESSURE OF AT LEAST 150 PSIG AT 73.4 DEGREES FAHRENHEIT UNLESS NOTED OTHERWISE.


WHERE A PIECE OF EQUIPMENT HAS A MAXIMUM OPERATING PRESSURE OF LESS THAN 150 PSI AND THE WATER SUPPLY LINE HAS A PRESSURE GREATER THAN THE EQUIPMENT CAN HANDLE A PRESSURE REDUCING VALVE SHALL BE PROVIDED.

A MINIMUM OF 2 WRAPS OF TEFLON TAPE OR OTHER COMPATIBLE THREAD WRAP SHALL BE PLACED AROUND THE THREADS OF CORPORATION STOPS, OR OTHER THREADED ITEMS THAT WILL BE THREADED INTO PIPES TO ENSURE WATER TIGHTNESS AND PROTECT THE THREADS FROM CHEMICALS, ETC.

CHEMICAL COVER PIPES LOCATED UNDER FLOOR SLABS SHALL BE CONCRETE ENCASED WHEN THE SLAB IS ABOVE SOIL.

DIAPHRAGM SEAL SPECS

LIQUID FILLED DIAPHRAGM SEALS SHALL BE INSTALLED ON ALL GAUGES. DIAPHRAGM SEALS SHALL BE OF THE CONTINUOUS DUTY TYPE, 3 PIECE CONSTRUCTION WITH 1/4" FLUSHING CONNECTION 316 STAINLESS STEEL LOWER HOUSING AND DIAPHRAGM MATERIALS, 1/4" GAUGE CONNECTION AND 1/2" LOWER CONNECTION. VITON DIAPHRAGMS ARE REQUIRED ON LOW RANGE PRESSURE APPLICATIONS (LESS THAN 15 PSIG). HOUSING BOLTS SHALL ALSO BE STAINLESS STEEL. ACCEPTABLE MODELS ARE MARSH 42-01, HELICORD 100-H, OR EQUAL. DIAPHRAGM SEALS SHALL BE "PERMANENTLY" ATTACHED TO GAUGES BY INSTALLATION OF A LEAD SEALED WIRE CONNECTING THE TWO. THIS IS TO PREVENT ACCIDENTAL LOSS OF FILL FLUID. FILL FLUID SHALL BE FACTORY INSTALLED SILICONE. ALL GAUGES SHALL BE PRECALIBRATED.

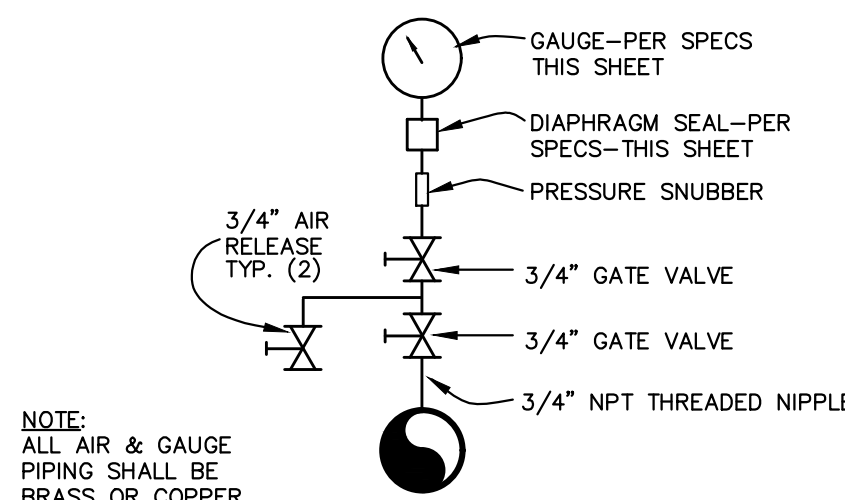

GAUGE SPECIFICATIONS


GAUGE SHALL HAVE PHOSPHOR BRONZE BOURDON TUBES, WHITE LAMINATED PHENOL DIALS. GAUGES SHALL BE 4 1/2" AND HAVE MICROMETER ADJUSTMENT OF POINTERS AND BLACK PHENOL, BLACK CAST IRON, BRASS OR ALUMINUM CASE AND RING, ROTARY GEAR DESIGN, CORROSION RESISTANT, STN. STL. MOVEMENT, BLOWOUT PROTECTION, AND BRONZE SOCKETS W/ WRENCH FLATS. ACCURACY SHALL BE WITHIN 1/2 OF 1% OF THE SCALE RANGE. THEY SHALL BE MANUFACTURED BY HELICORD GAUGE DIVISION, "410T", JAMES P. MARSH CORP. "MASTERGAUGE", ASHROFT, U.S. GAUGE, OR EQUAL. ALL GAUGES SHALL BE PRECALIBRATED.

AIR RELEASE & GAUGE ASSEMBLIES

NOT TO SCALE

PRESSURE GAUGE RANGE TABLE

	RANGE		FIGURE INTERVAL		MINOR GRADATION	
	INNER-psi	OUTER-ft H ₂ O	psi	ft H ₂ O	psi	ft H ₂ O
SUCTION	0/60	0/140	5	20	1	2
DISCHARGE	0/300	0/690	25	50	5	10

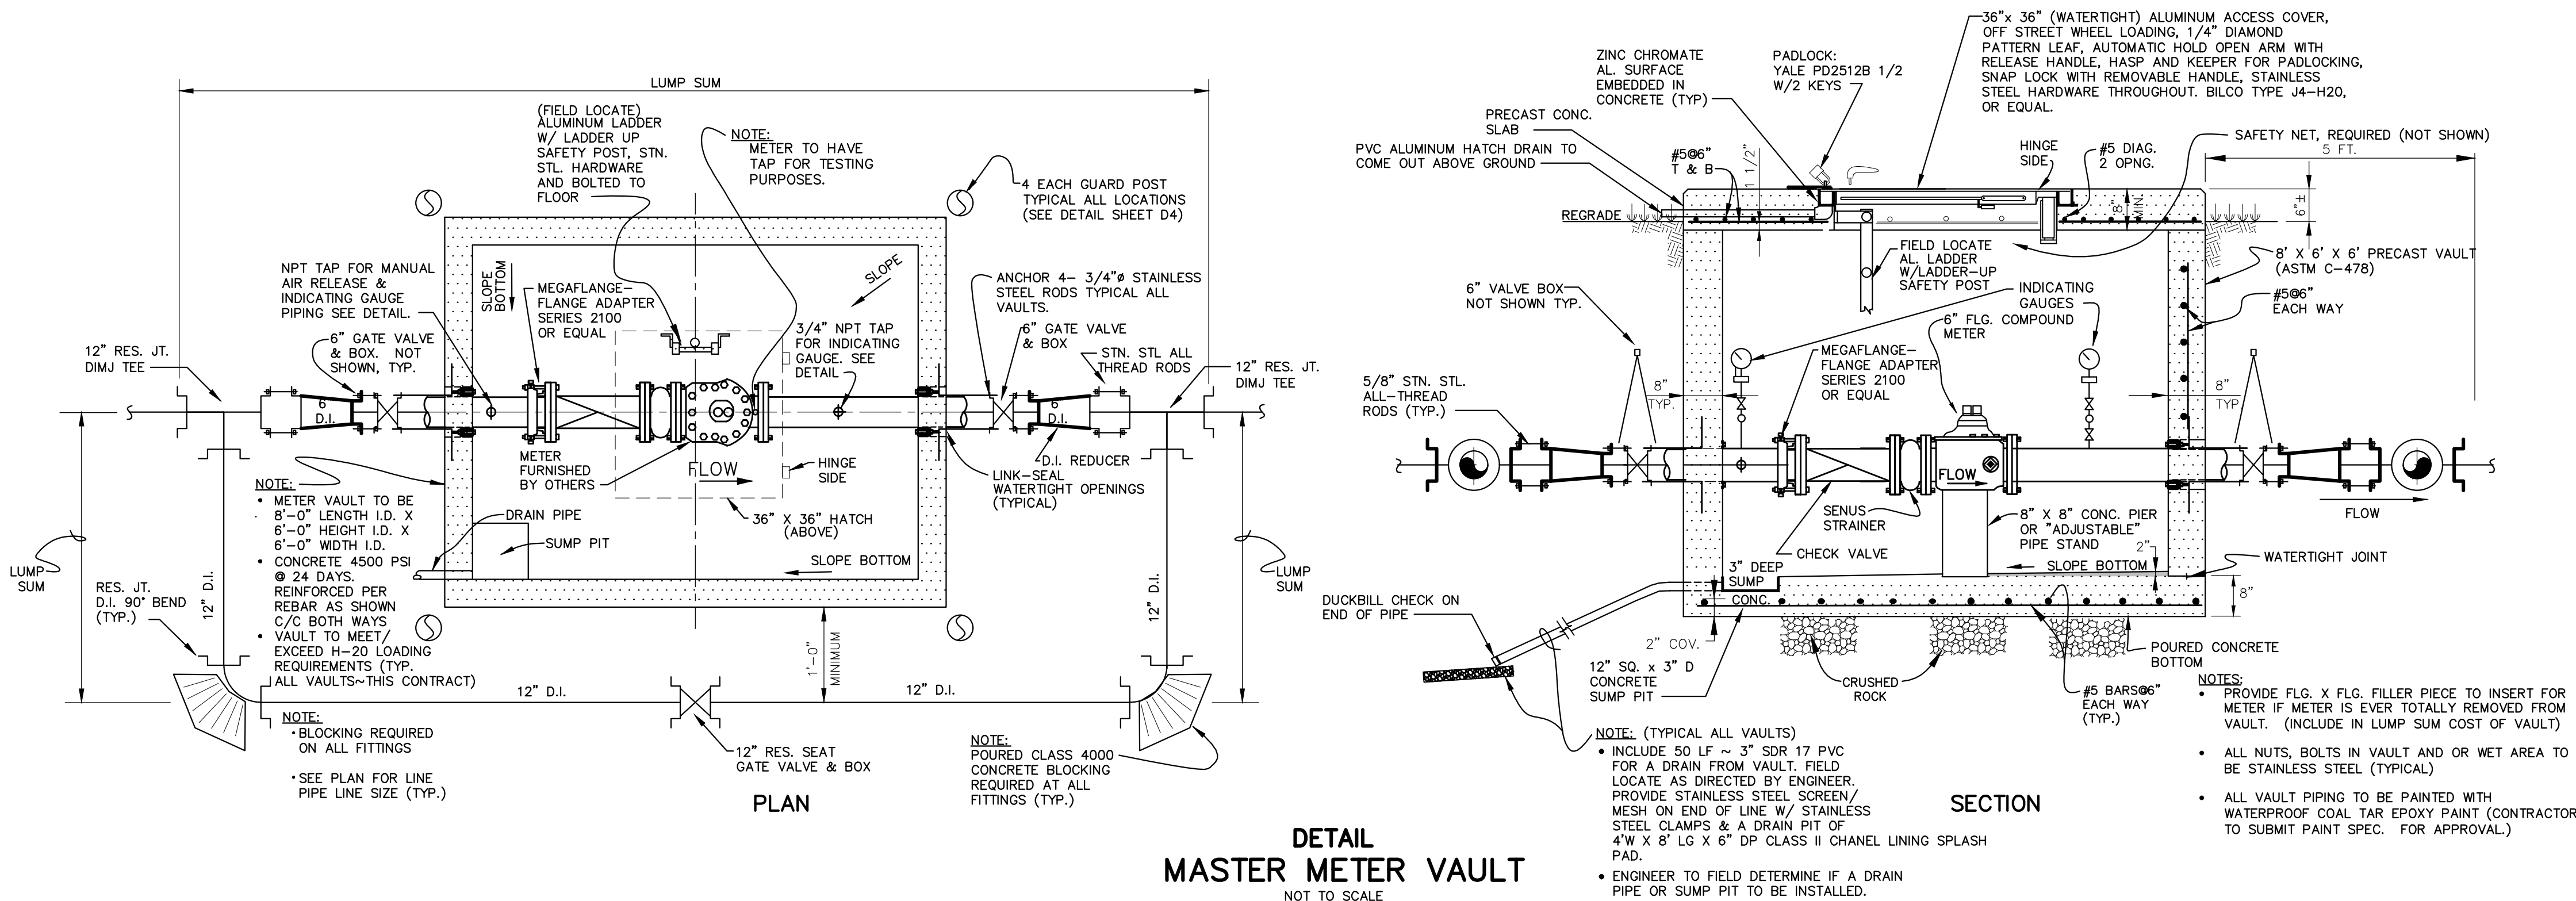

DESIGNER	DEG	DATE	BY	REVISION
DRAWN	TEW			
CHECKED	DEG			
APPROVED	DEG			

GRAPHIC SCALE	
SCALE: AS NOTED	

ALL RIGHTS RESERVED
THIS DOCUMENT IS THE PROPERTY OF BELL ENGINEERING AND SHALL NOT BE REPRODUCED IN WHOLE OR IN PART OR USED FOR CONSTRUCTION OF OTHER THAN THIS SPECIFIC PROJECT WITHOUT THE WRITTEN PERMISSION OF BELL ENGINEERING. FACSIMILES OF LICENSED PROFESSIONAL ENGINEER AND/OR LAND SURVEYOR SEALS, IF AFFIXED TO THIS DOCUMENT, SHALL BE CONSIDERED LEGITIMATE ONLY IF SIGNED AND DATED BY THE REGISTRANT.

Lexington, KY (859) 278-5412
Hopkinsville, KY (270) 886-5466
Somerset, KY (606) 485-4011

WATER SYSTEM IMPROVEMENTS
SHOPS CREEK ROAD AREA
CANNONSURG WATER DISTRICT
CANNONSURG, KENTUCKY


MASTER METER VAULT DETAILS,
GENERAL PIPING NOTES, AND PRESSURE GAUGE
DETAILS

DIVISION	-
CONTRACT NO.	691-21-01
DATE	SEPTEMBER 2021
SHEET NO.	13 OF 17




BOXLOK VALVE BOX ALIGNMENT DEVICE MODEL 2
TO BE INSTALLED IN ALL NEW VALVE BOXES
NOT TO SCALE

NOTE:
FITTINGS SHALL BE WRAPPED WITH 8 MIL. POLYETHYLENE AT ALL THRUST BLOCKS, PLACED SO FITTINGS, BOLTS AND NUTS DO NOT COME IN CONTACT WITH CONCRETE. IF MECHANICAL JOINT PLUG IS USED ON THE BRANCH, NO BLOCKING WILL BE REQUIRED ON THE PLUG. THE SIDE OF THE TEE SHALL BE BLOCKED IN ALL CASES.

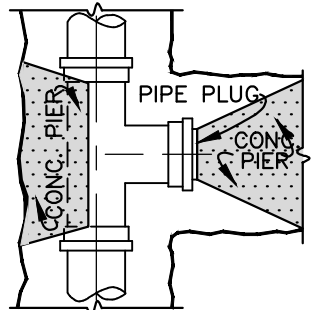


PLAN

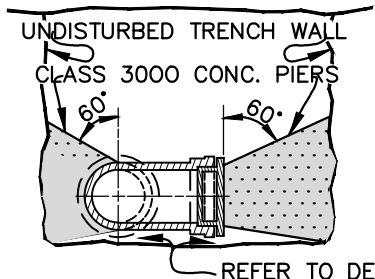


SECTION

TYPICAL DETAIL OF CONCRETE
BLOCKING AT TEES & PLUGS

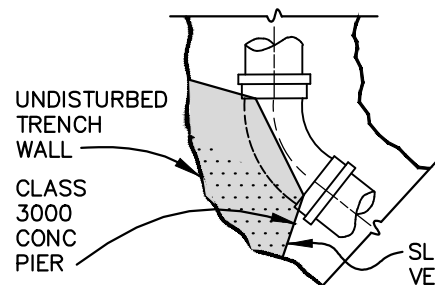


PLAN

TYPICAL DETAIL OF CONCRETE
BLOCKING AT HORIZONTAL BENDS
NOT TO SCALE

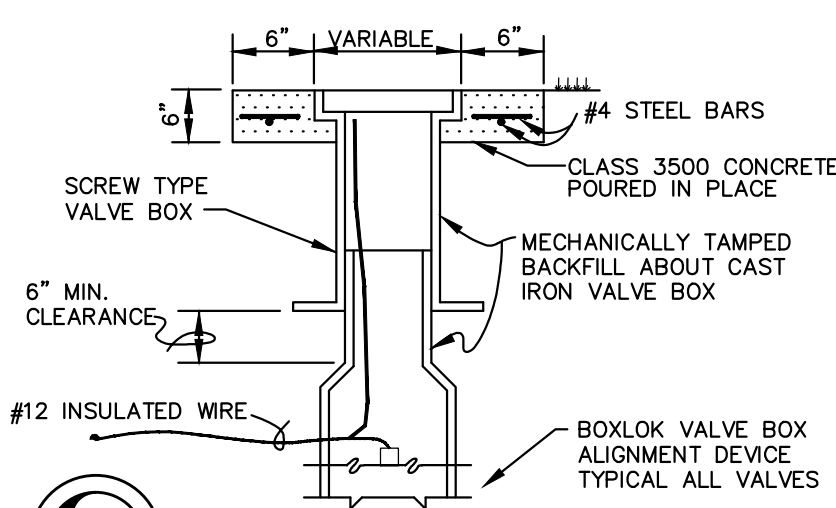


CONCRETE VALVE
BOX COLLAR
NOT TO SCALE
(REQUIRED ON ALL VALVES)

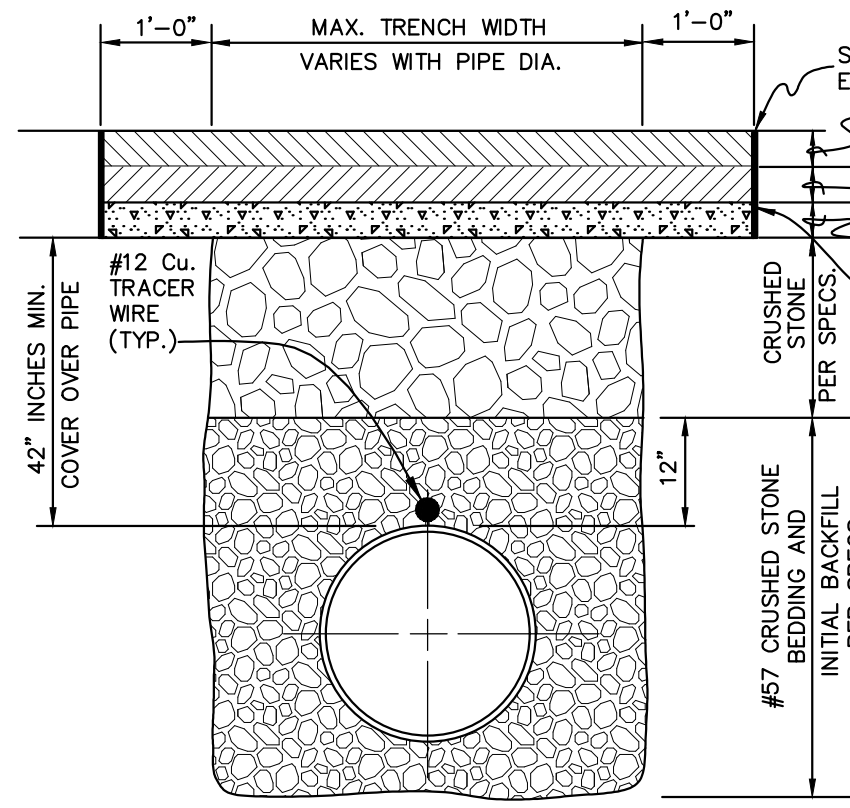


NOTE:
WHERE EXISTING ROAD/DRIVE SURFACE IS CONCRETE, SUBSTITUTE CONCRETE FOR BITUMINOUS CONCRETE, OF DEPTH EQUAL TO EXISTING CONCRETE DEPTH.

TRENCH DETAIL
TYPICAL OPEN CUT CROSSING OF
COUNTY ROADS AND DRIVEWAYS
NOT TO SCALE

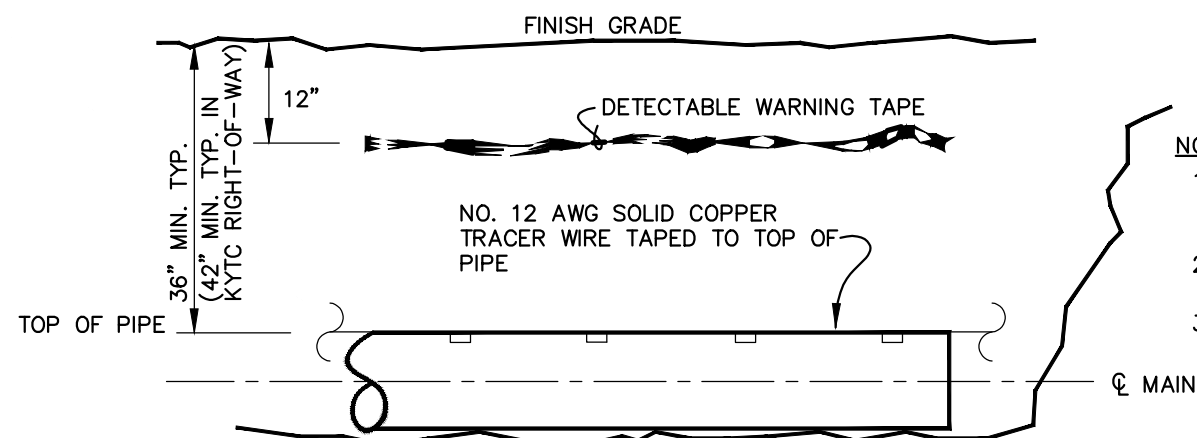


- NOTES:
1. PVC, PE OR D.I. WATERLINE TO BE BACKFILLED 2 FEET- THEN PLACE DETECTABLE TAPE DIRECTLY OVER PIPE.
 2. TAPE TO BE TIED TO ALL MAIN LINES, SERVICE LINES, VALVES, WATER METERS AND HYDRANTS.
 3. NO. 12 AWG COPPER TRACER WIRE SHALL BE PULLED INTO ALL VALVE BOXES WITH LOOP FOR TEST/LOCATOR EQUIPMENT ACCESS.

TYPICAL PVC, D.I. OR POLYETHYLENE WL WITH
NO. 12 AWG TRACER WIRE AND
DETECTABLE TAPE INSTALLATION
NOT TO SCALE

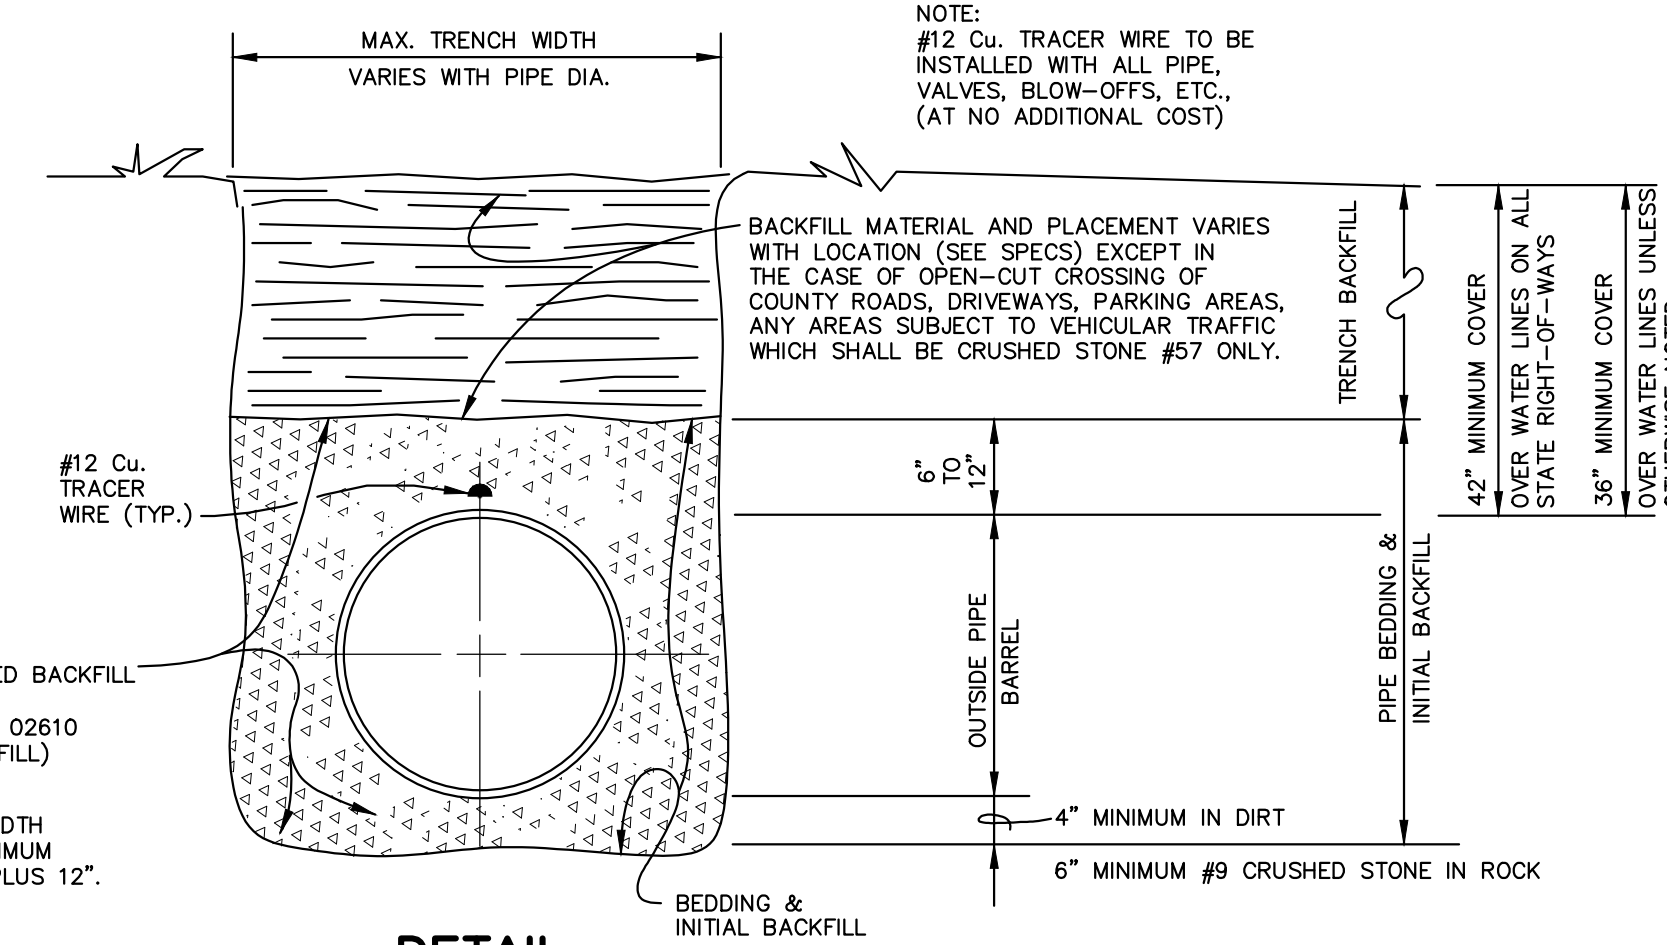


DETAIL
BEDDING & BACKFILL
WATER MAIN INSTALLATION
NOT TO SCALE

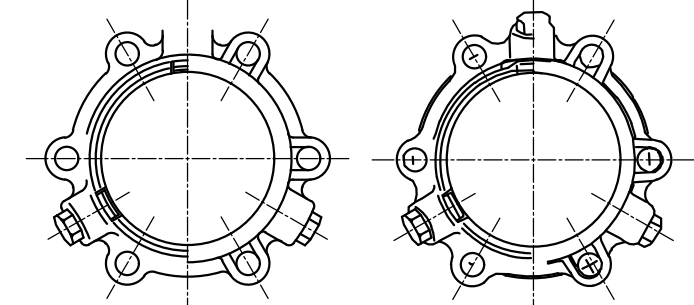


REAR VIEW
SECTION A-A
FRONT VIEW
SECTION B-B

MEGALUG
JOINT RESTRAINT
NOT TO SCALE


NOTE:
WATER WORKING
PRESSURE 250 PSI MIN.
SIZES 3"-48"
PRODUCT OF EBAA
IRON, INC. OR EQUAL

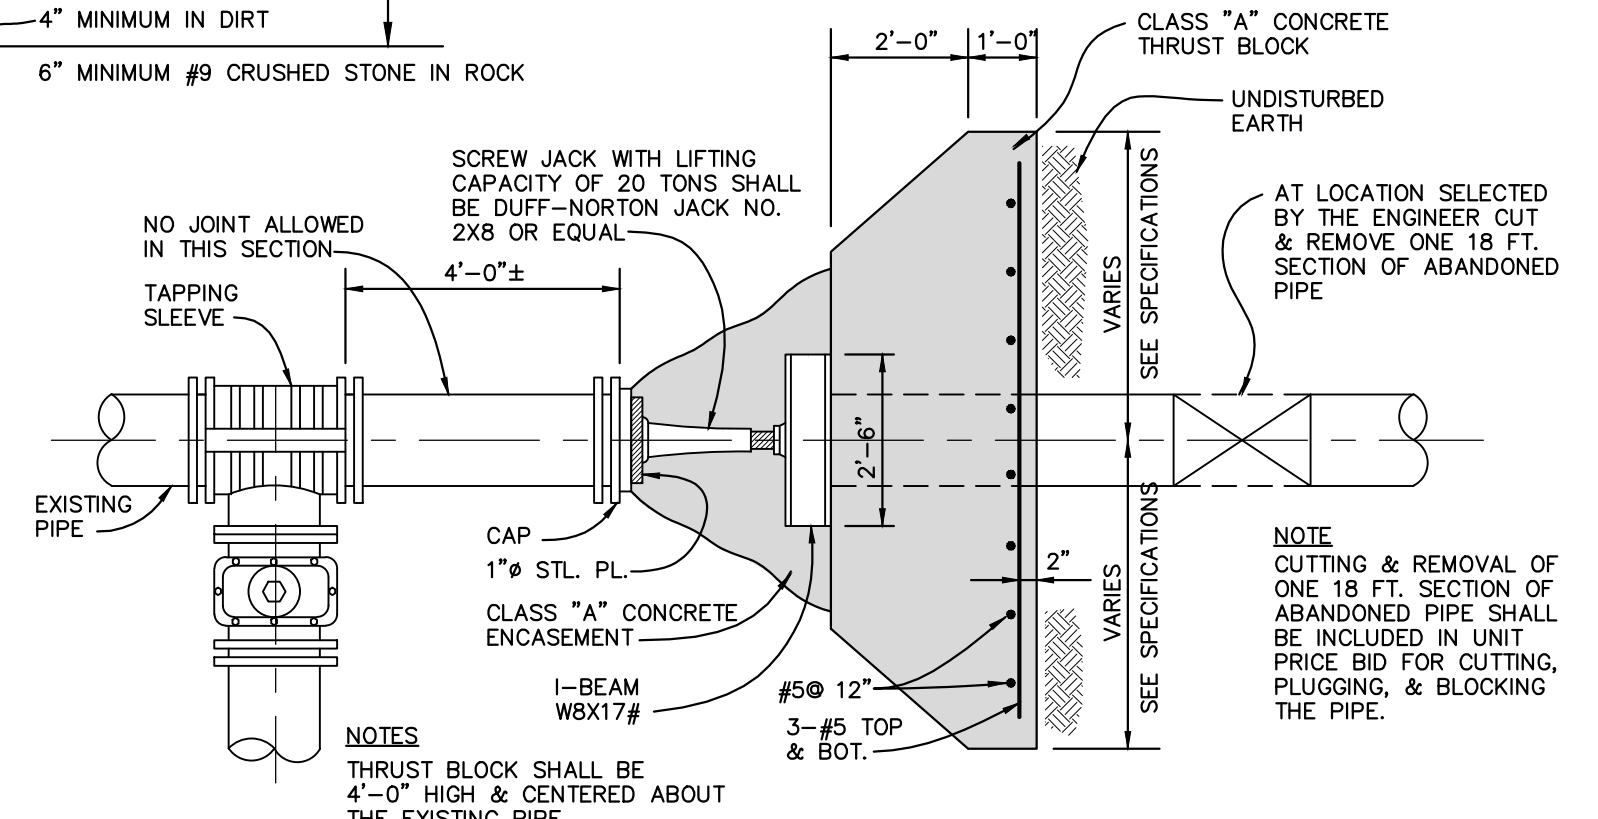


TYPICAL DETAIL CUTTING & BLOCKING
AT TAP INTO EXISTING LINE
(LUMP SUM)
NOT TO SCALE

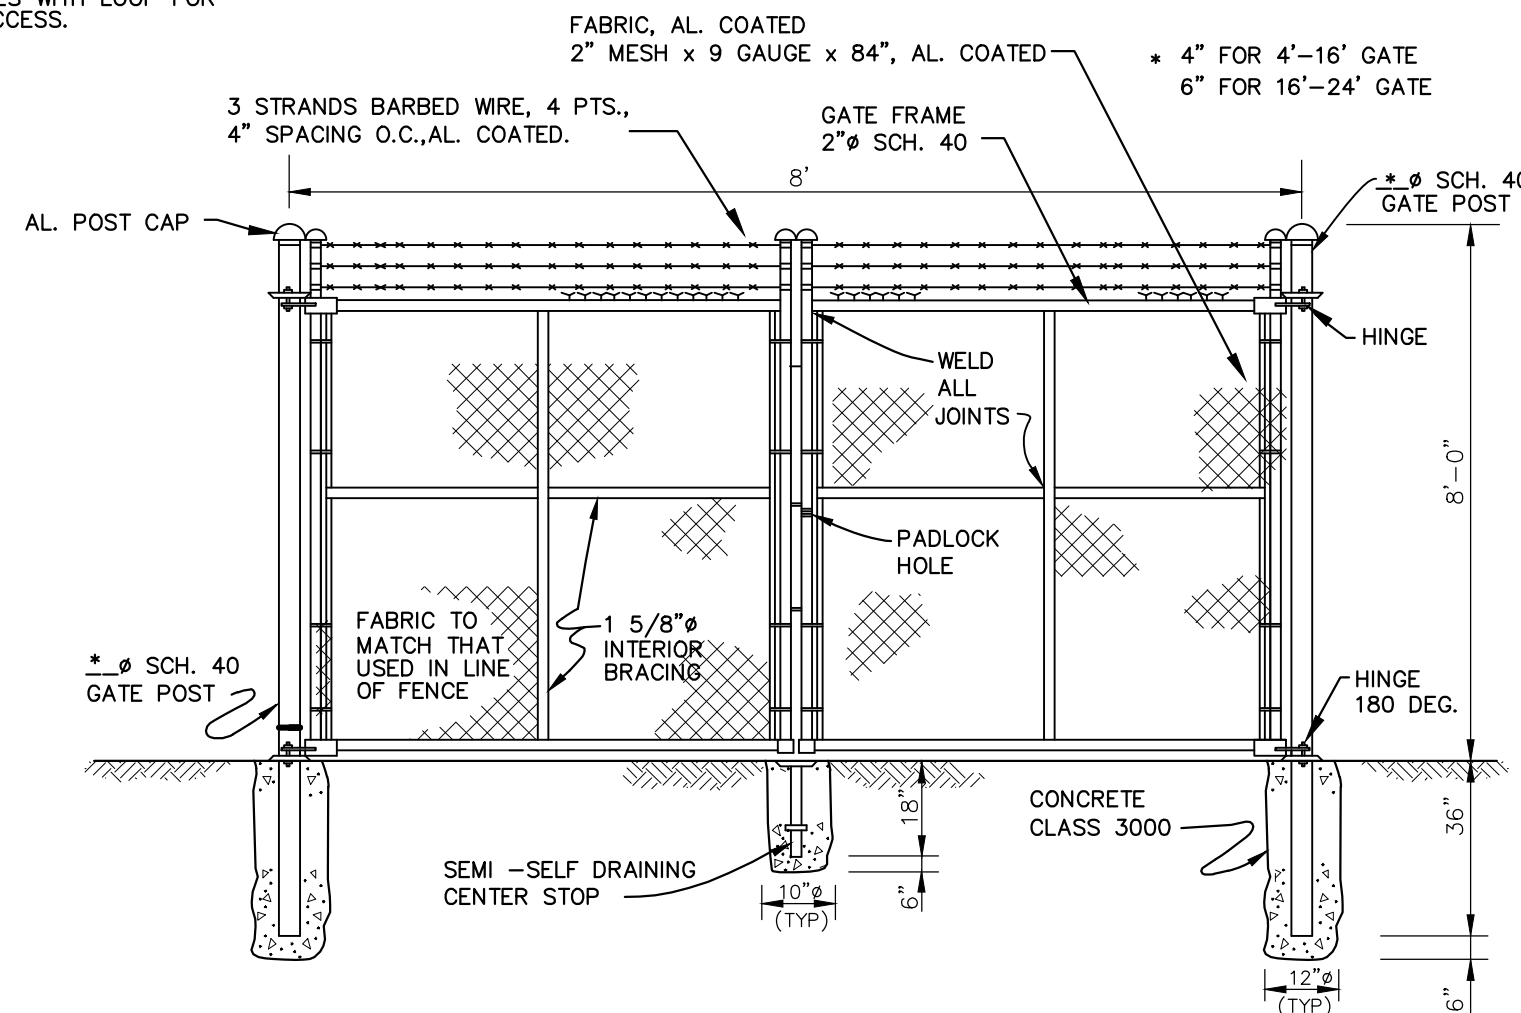

DETAIL - DOUBLE GATE
NOT TO SCALE

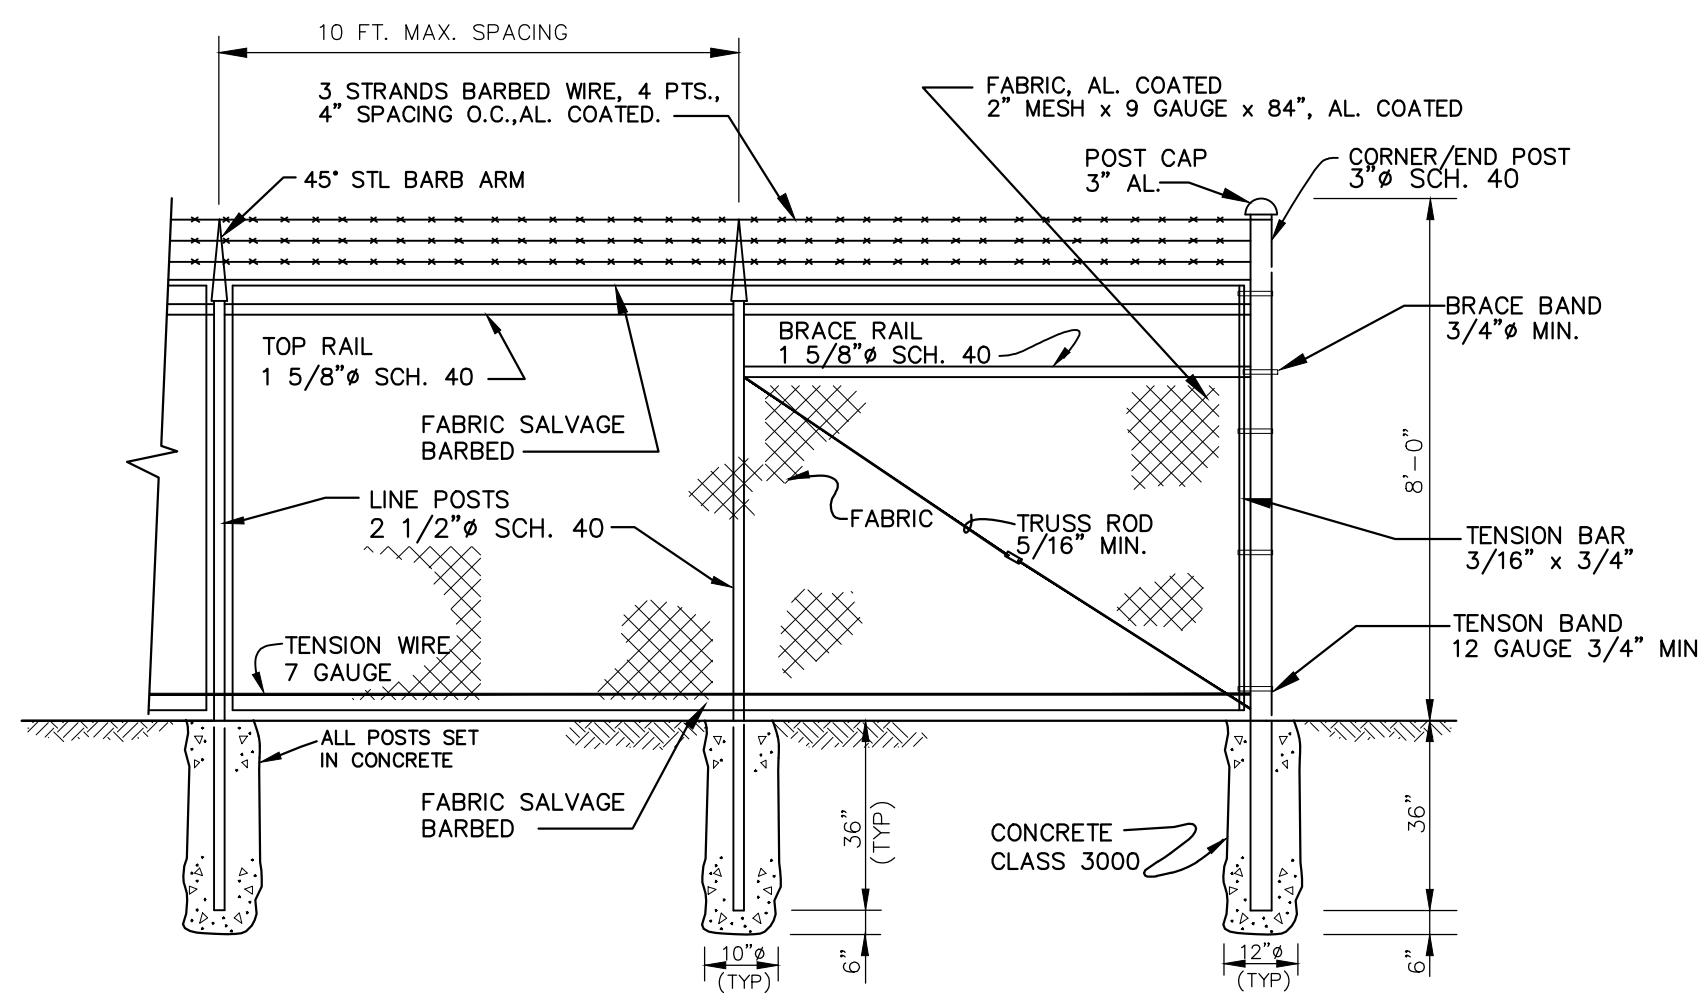

DETAIL - SECURITY FENCE
NOT TO SCALE

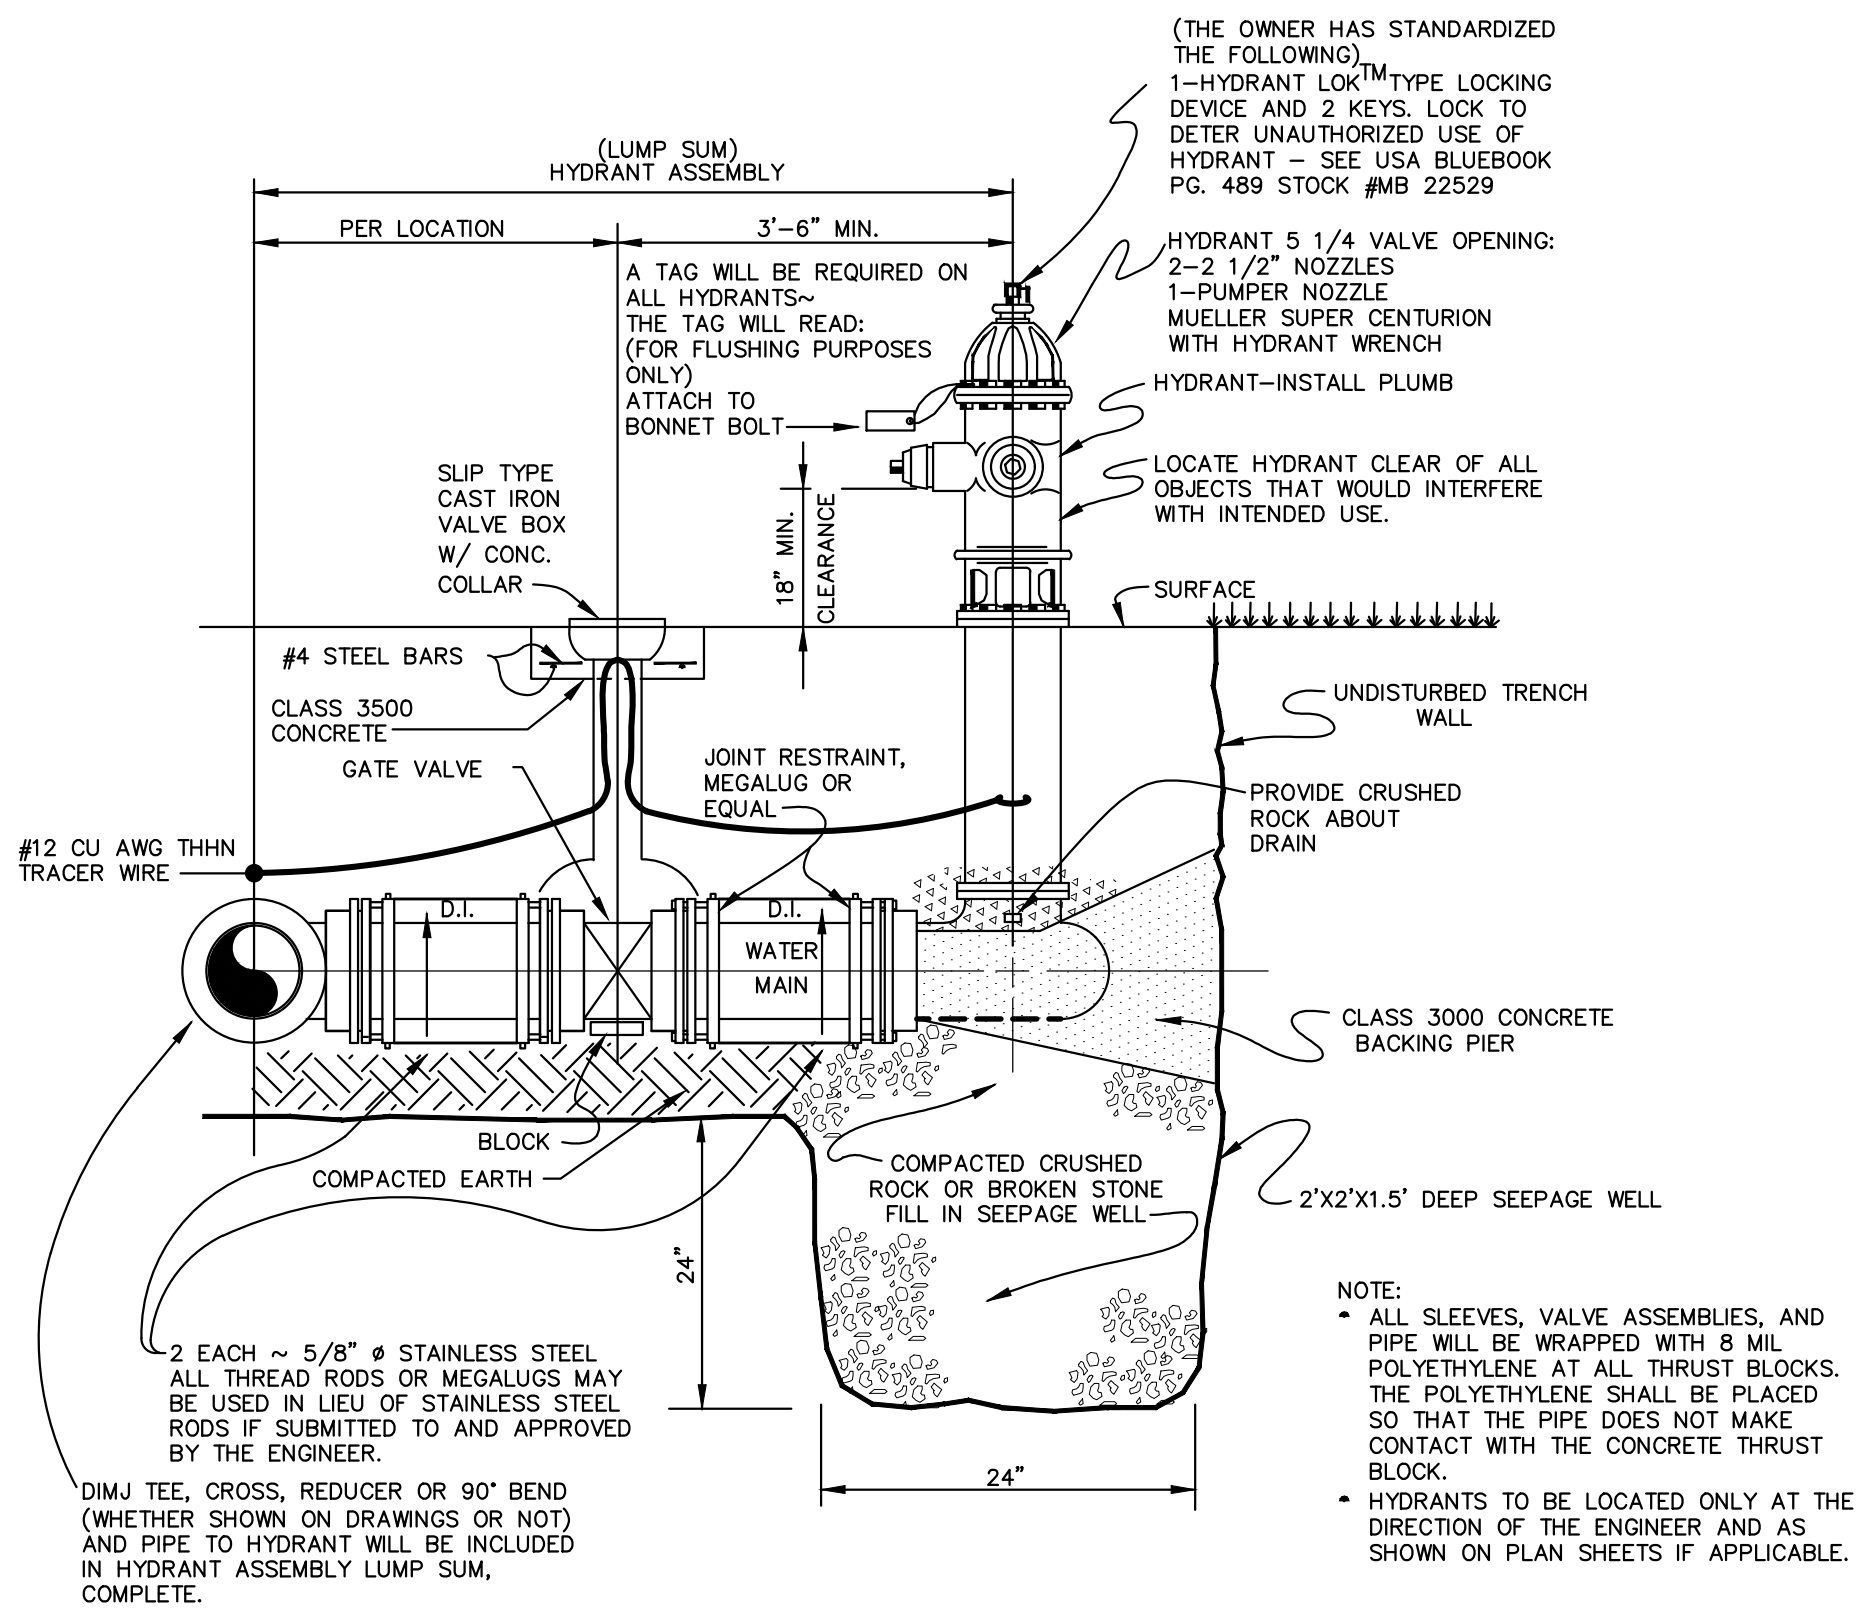


FLUSHING HYDRANT ASSEMBLY
(LUMP SUM)
NOT TO SCALE

DESIGNER	DEG	DATE	BY	REVISION
DRAWN	TEW			
CHECKED	DEG			
APPROVED	DEG			

GRAPHIC SCALE
SCALE: AS NOTED

ALL RIGHTS RESERVED
THIS DOCUMENT IS THE PROPERTY OF BELL ENGINEERING AND SHALL NOT BE REPRODUCED IN WHOLE OR IN PART OR USED FOR CONSTRUCTION OF OTHER THAN THIS SPECIFIC PROJECT WITHOUT THE WRITTEN PERMISSION OF BELL ENGINEERING. FACSIMILES OF LICENSED PROFESSIONAL ENGINEER AND/OR LAND SURVEYOR SEALS, IF AFFIXED TO THIS DOCUMENT, SHALL BE CONSIDERED LEGITIMATE ONLY IF SIGNED AND DATED BY THE REGISTRANT.

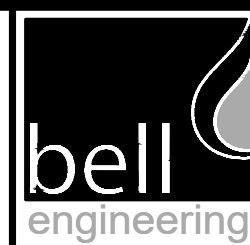


Lexington, KY (859) 278-5412
Hopkinsville, KY (270) 886-5466
Somerset, KY (606) 485-4011

WATER SYSTEM IMPROVEMENTS
SHOPE'S CREEK ROAD AREA
CANNONBURG WATER DISTRICT
CANNONBURG, KENTUCKY


MISCELLANEOUS DETAILS

DIVISION	-
CONTRACT NO.	691-21-01
DATE	SEPTEMBER 2021
SHEET NO.	14 OF 17




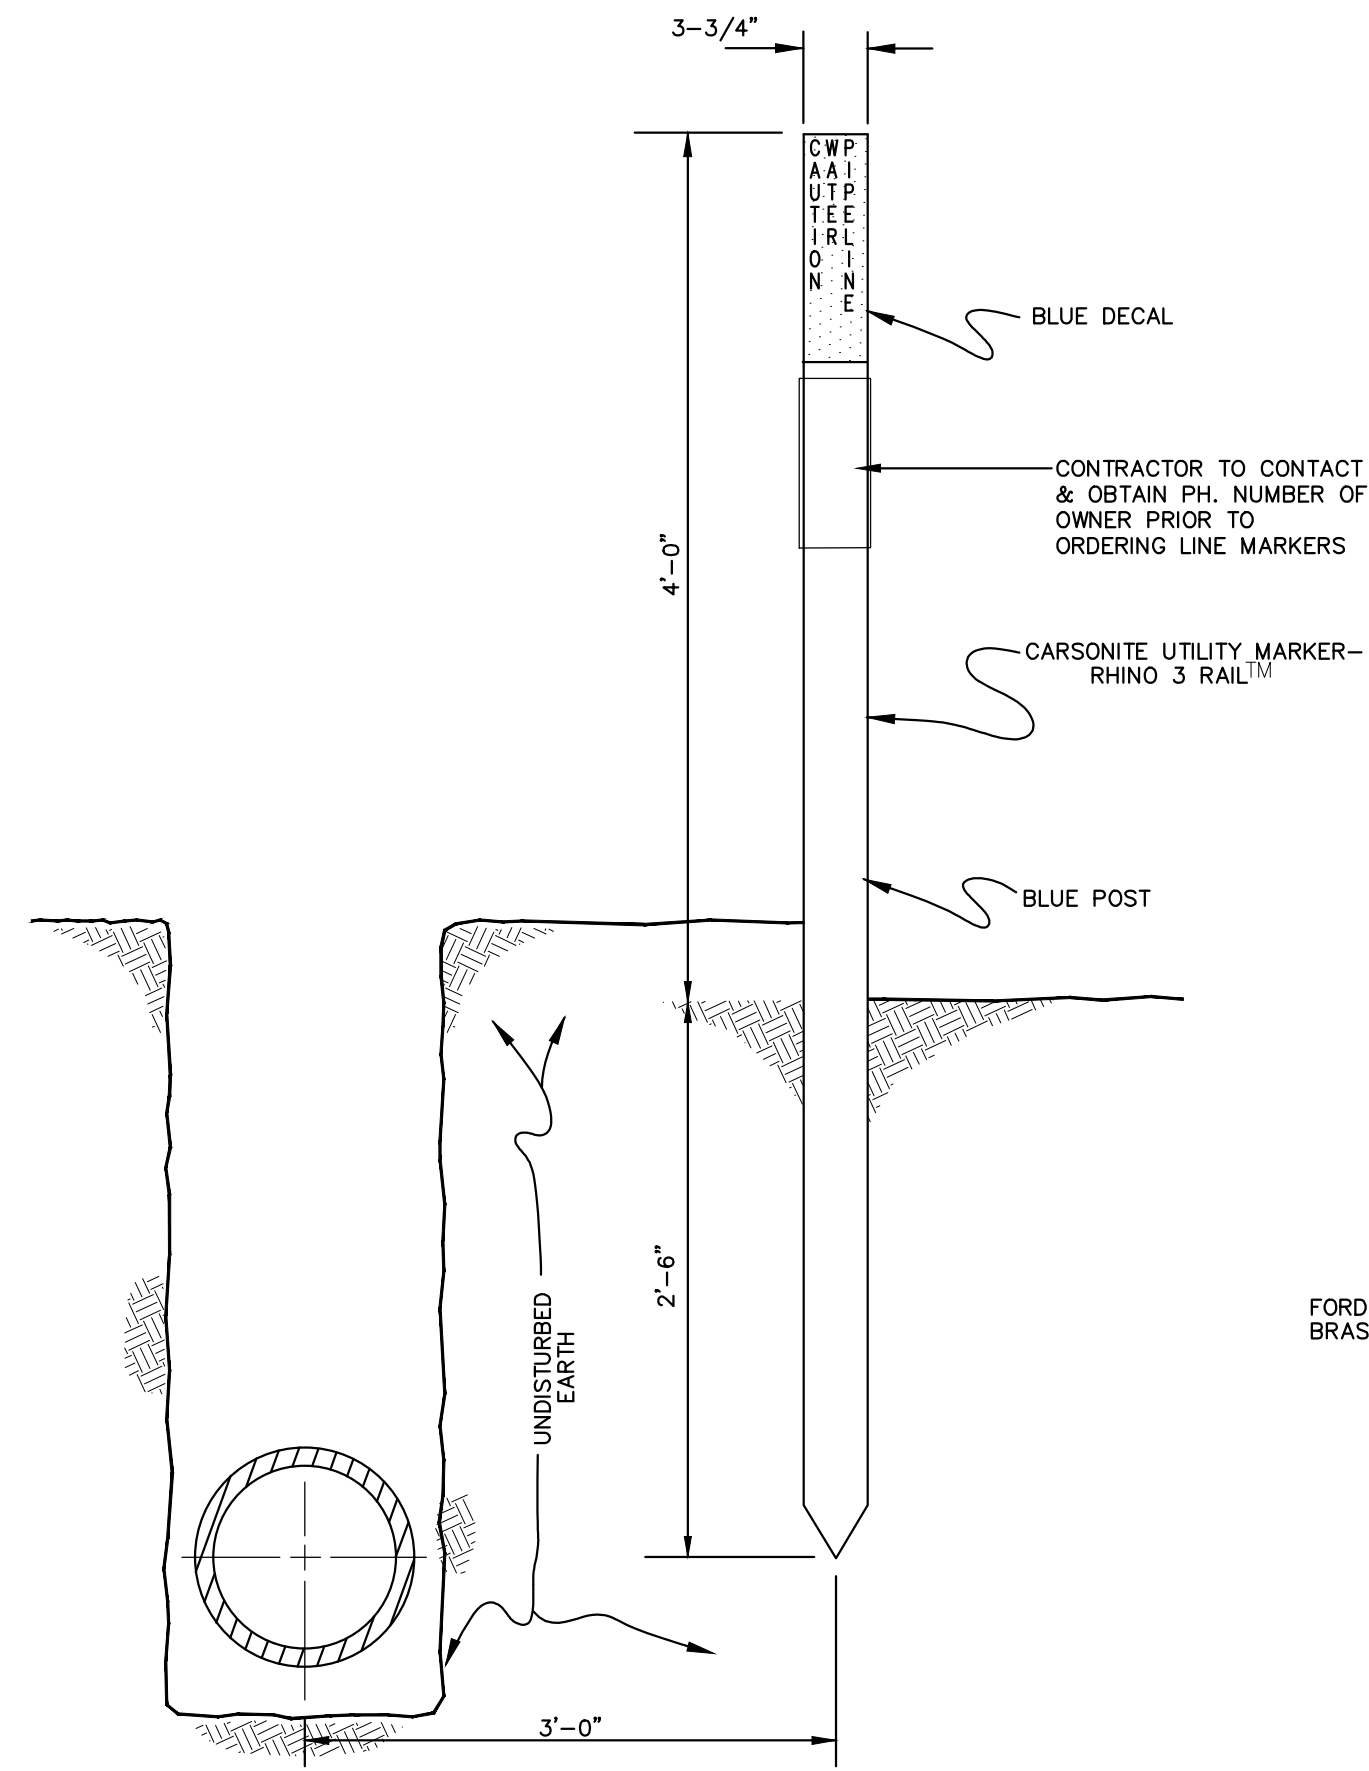


DETAIL
FLEXIBLE FIBERGLASS COMPOSITION
LINE MARKER
NOT TO SCALE

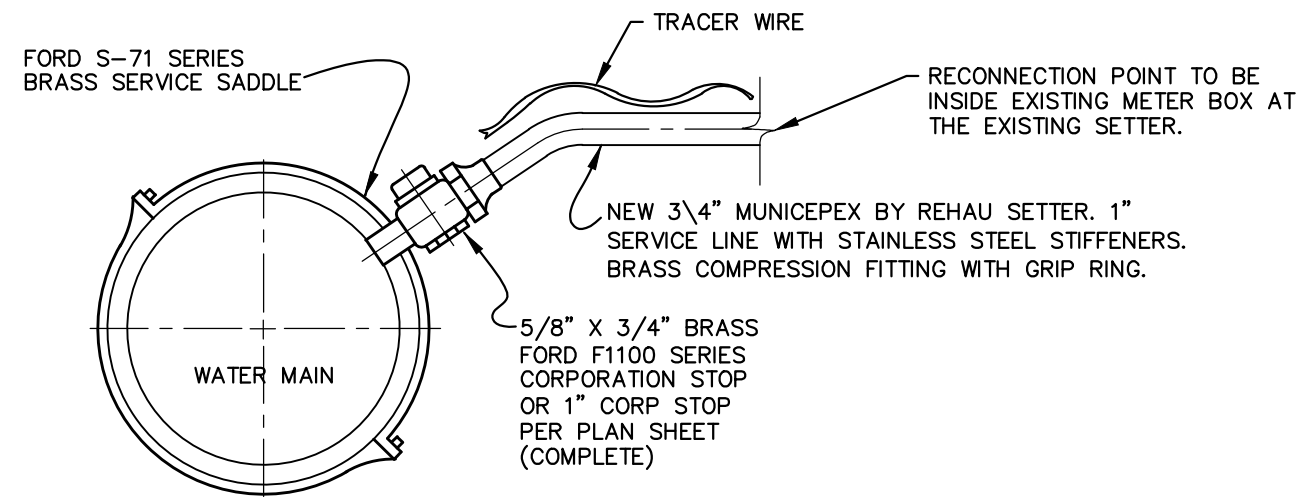

RECONNECT TO
EXISTING METER
NOT TO SCALE

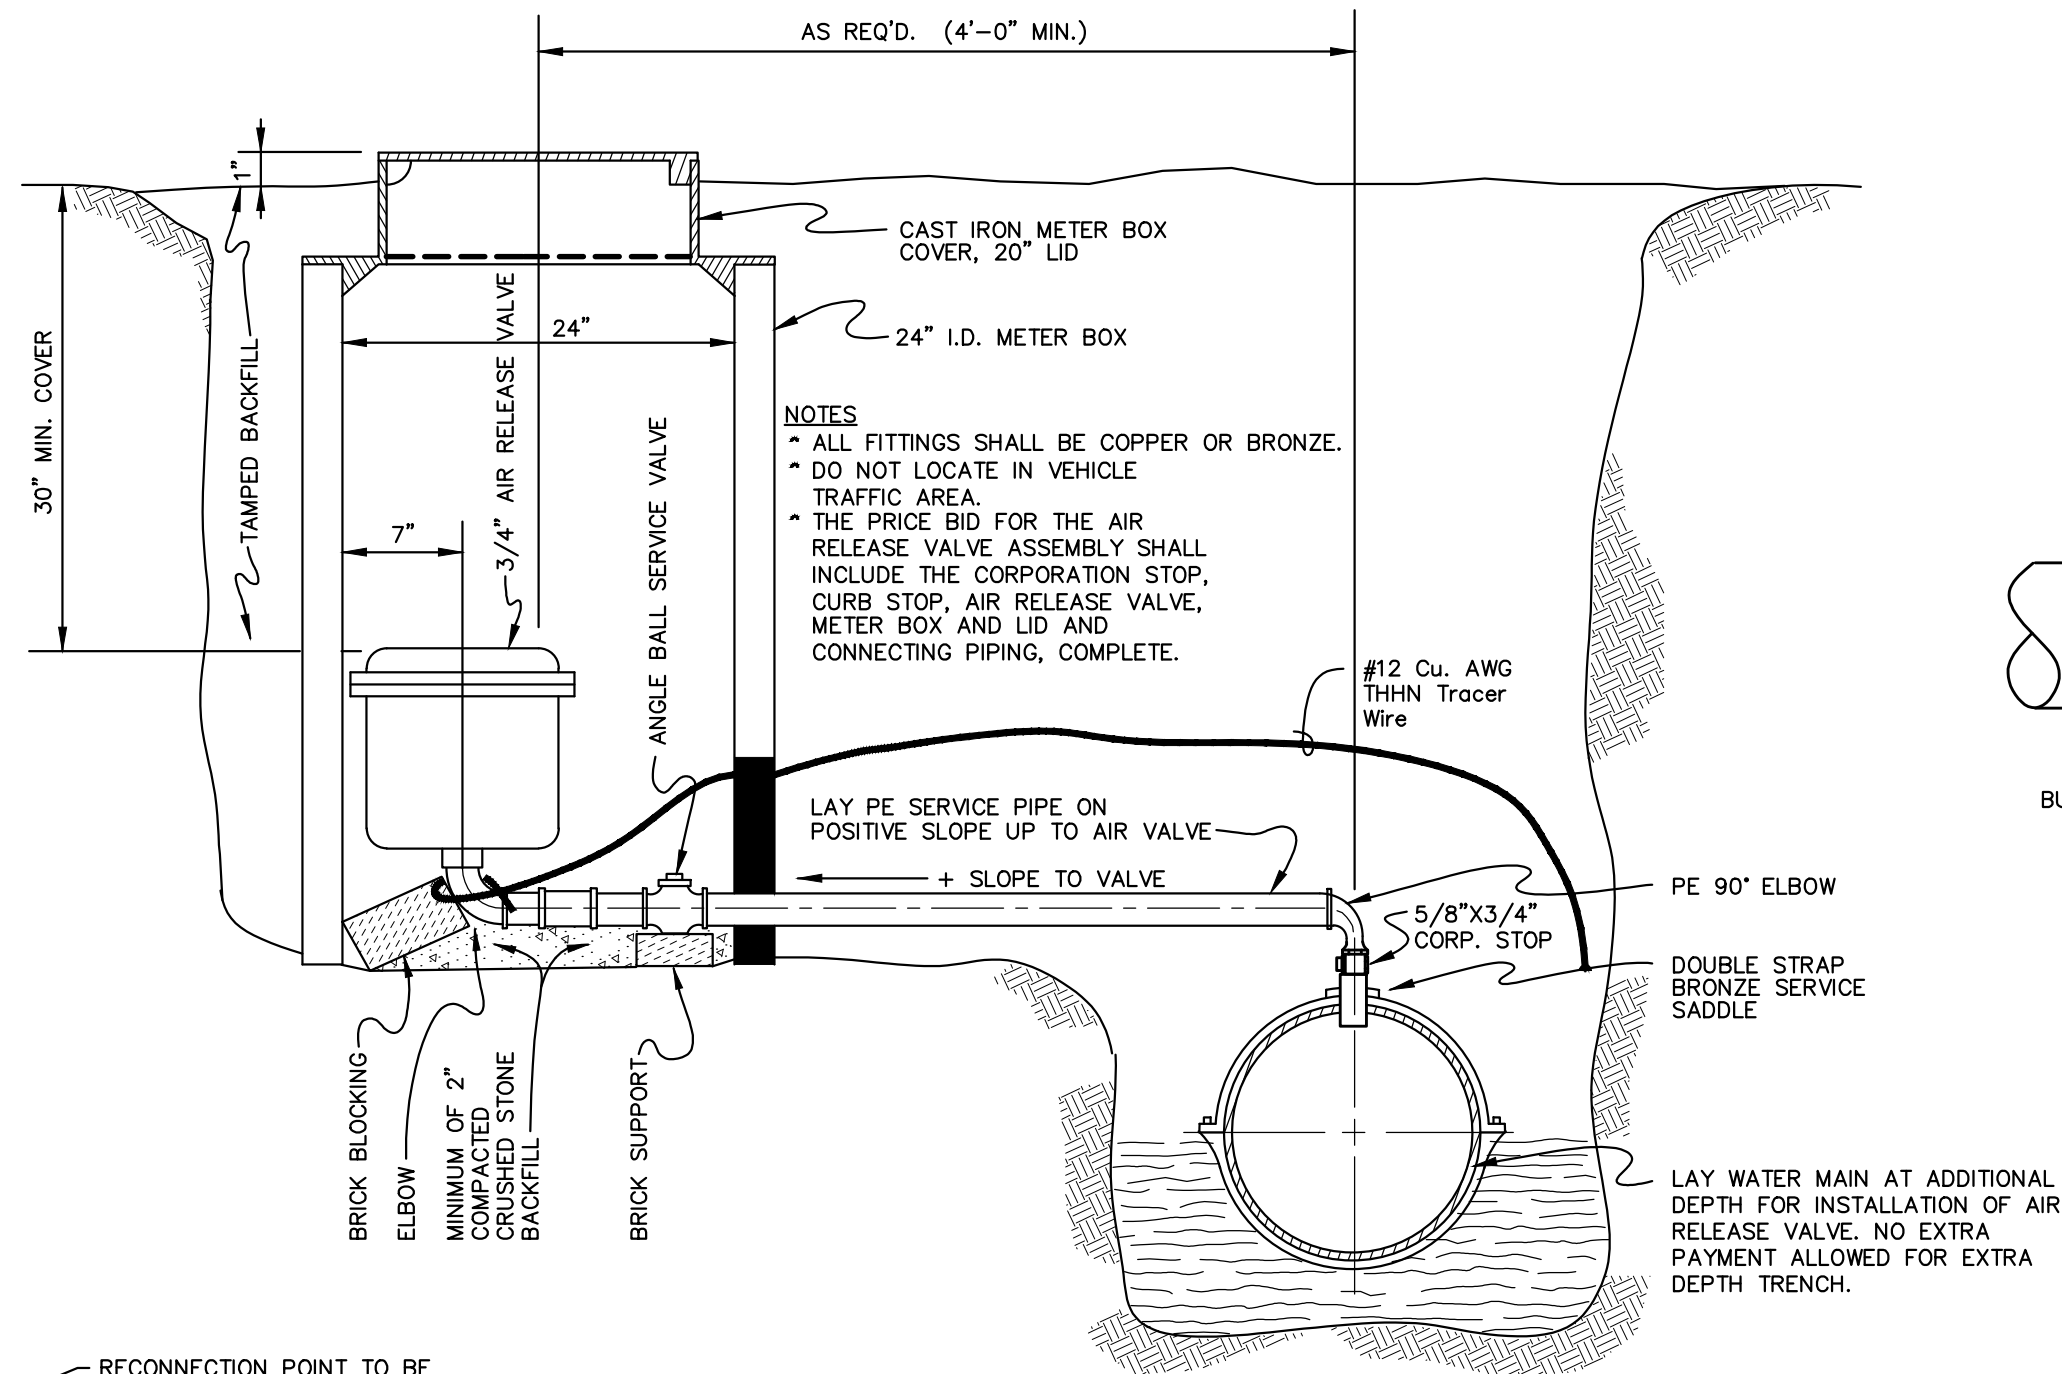


AUTOMATIC AIR RELEASE
VALVE ASSEMBLY
NOT TO SCALE

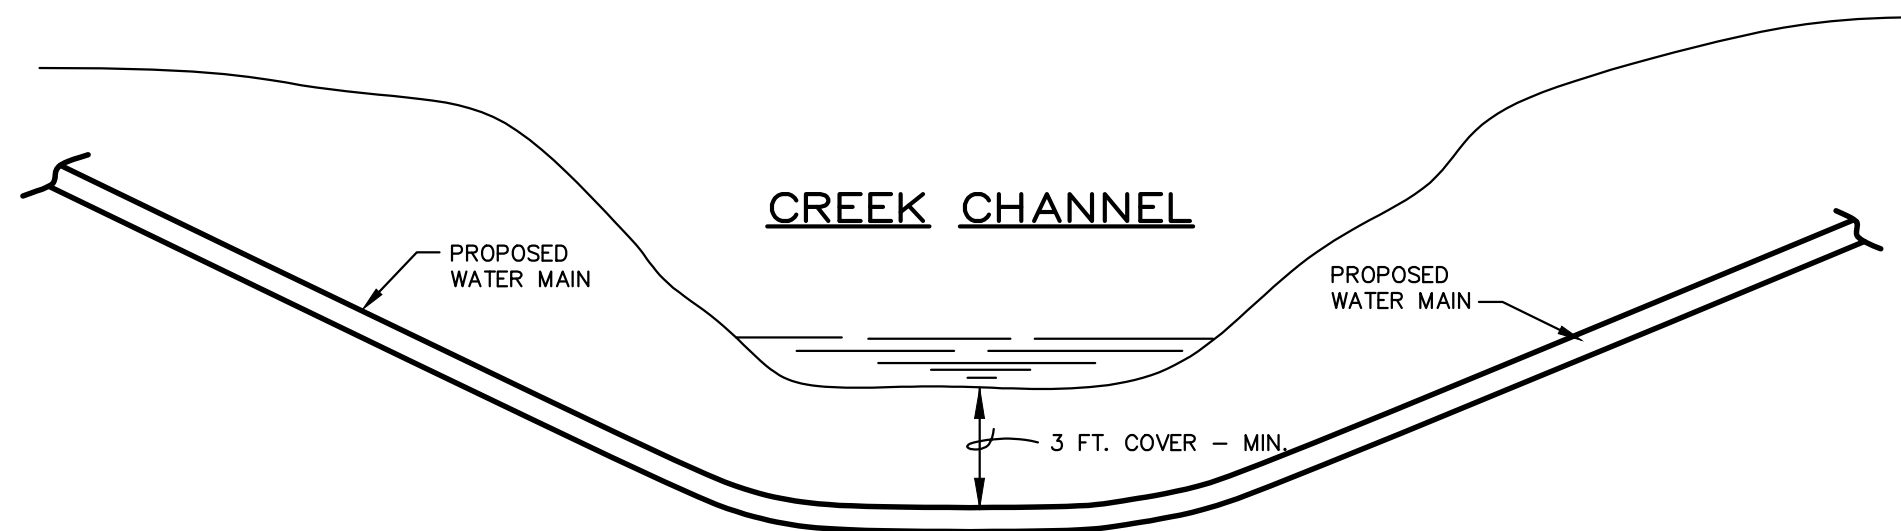


CONTRACTOR TO INSTALL WATER MAIN EXTRA DEPTH,
AS NECESSARY TO FIT CREEK CHANNEL.

TYPICAL SECTION
WATER MAIN @
CREEK CROSSING
NOT TO SCALE

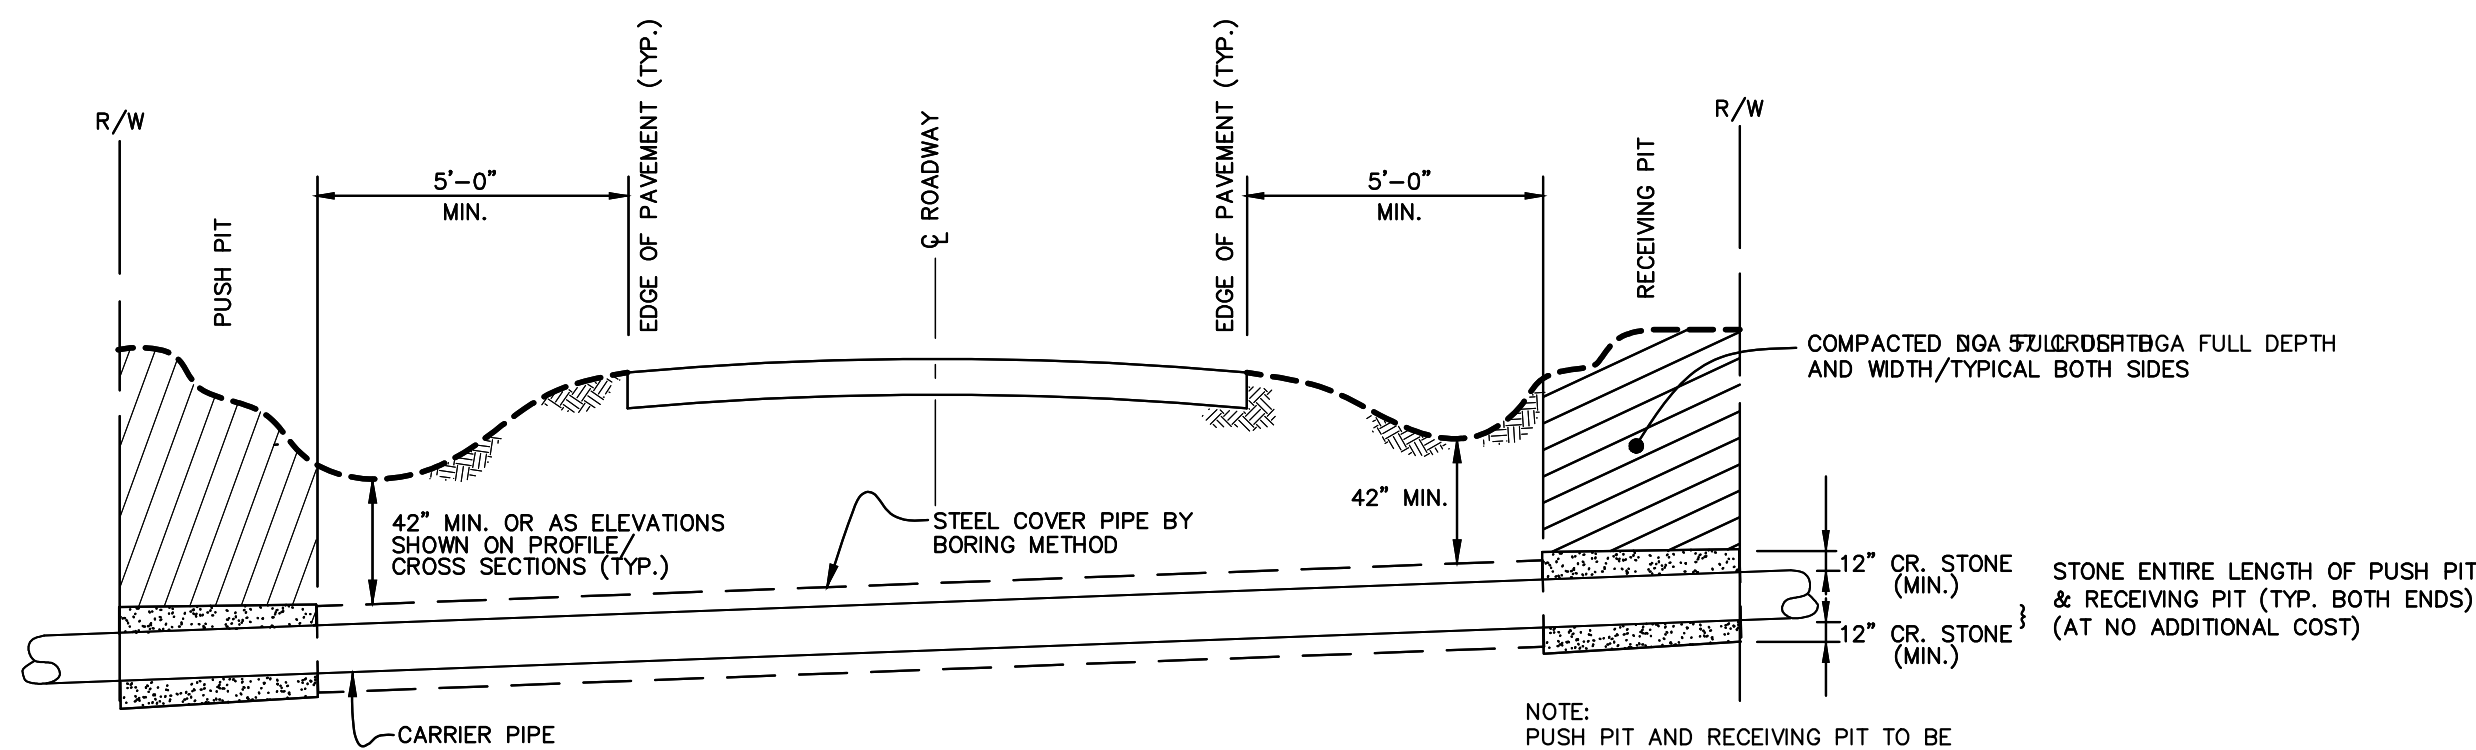


DETAIL
TYPICAL HIGHWAY BORING
NOT TO SCALE

NOTE:
PUSH PIT AND RECEIVING PIT TO BE
BACKFILLED AND THOROUGHLY
COMPACTED WITH #57 CRUSHED STONE.
ALL DITCH LINES TO BE LEFT OPEN.
SEED AND STRAW ALL AREAS DISTURBED
BY THIS WORK IMMEDIATELY AFTER
COMPLETING WORK. ALL DISTURBED
ASPHALT OR CONCRETE SURFACES TO
BE REPLACED WITH A MIN. OF 6\"/>

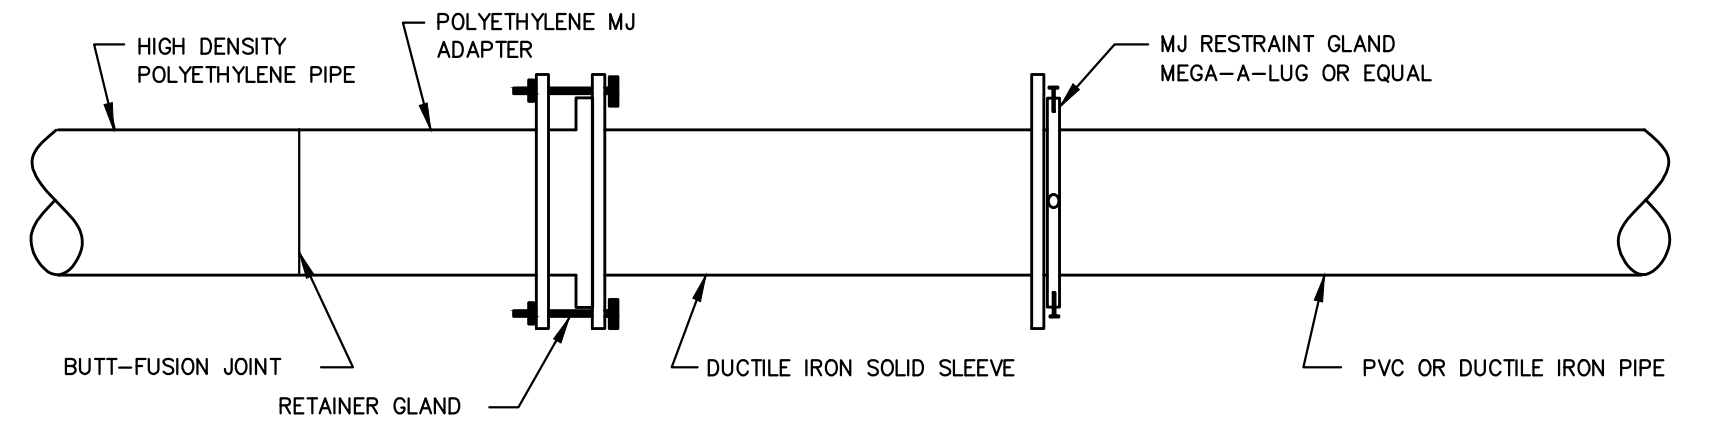

HDPE TO PVC/DUCTILE
IRON PIPE
TRANSITION DETAIL
ON DIRECTIONAL BORES
NOT TO SCALE
(TYPICAL EACH END)

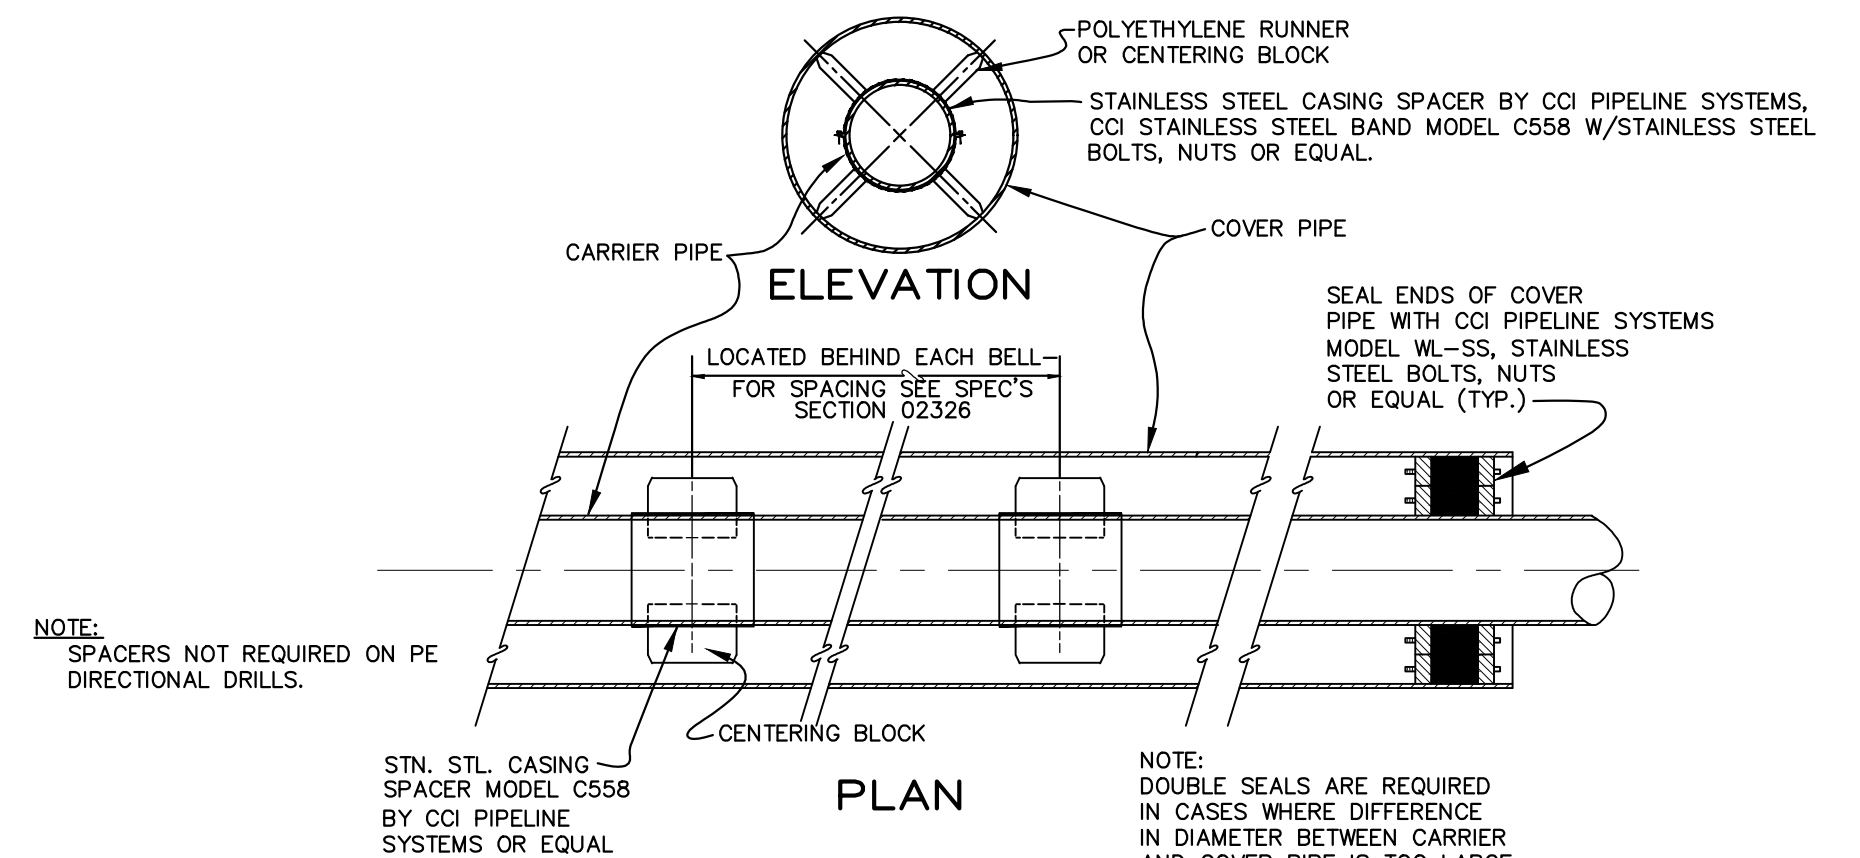


DETAIL
CARRIER PIPE POSITIONING
IN COVER PIPE
NOT TO SCALE



ORANGE POLYPROPYLENE
NOT IN SERVICE
HYDRANT BAG DETAIL
NOT TO SCALE


- NOTE:
1. ALL NEW HYDRANTS INSTALLED SHALL BE COVERED WITH "NOT IN SERVICE" BAG UNTIL THEY ARE PUT IN SERVICE.
 2. ALL EXISTING HYDRANTS SHALL BE COVERED WITH "NOT IN SERVICE BAG" ONCE THE EXISTING LINE IS TAKEN OUT OF SERVICE UNTIL THE EXISTING HYDRANTS ARE REMOVED.
 3. ALL EXISTING HYDRANTS AND HYDRANT VALVES SHALL BE REMOVED AND TURNED OVER TO THE OWNER. EXISTING WATER MAIN SHALL BE PLUG/CAPPED AND HOLE BACKFILLED TO MATCH ADJACENT SURFACE I.E. CONCRETE, ASPHALT, GRASS.

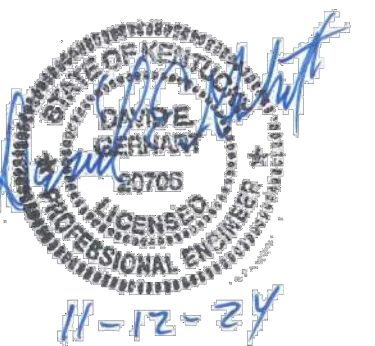

DESIGNER	DEG	DATE	BY	REVISION
DRAWN	TEW			
CHECKED	DEG			
APPROVED	DEG			

GRAPHIC SCALE
SCALE: AS NOTED

ALL RIGHTS RESERVED
THIS DOCUMENT IS THE PROPERTY OF BELL ENGINEERING AND SHALL NOT BE REPRODUCED IN WHOLE OR IN PART OR USED FOR CONSTRUCTION OF OTHER THAN THIS SPECIFIC PROJECT WITHOUT THE WRITTEN PERMISSION OF BELL ENGINEERING. FACSIMILES OF LICENSED PROFESSIONAL ENGINEER AND/OR LAND SURVEYOR SEALS, IF AFFIXED TO THIS DOCUMENT, SHALL BE CONSIDERED LEGITIMATE ONLY IF SIGNED AND DATED BY THE REGISTRANT.






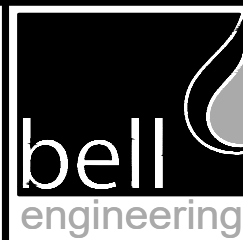


Lexington, KY (859) 278-5412
Hopkinsville, KY (270) 886-5466
Somerset, KY (606) 485-4011

WATER SYSTEM IMPROVEMENTS
SHOPES CREEK ROAD AREA
CANNONSBURG WATER DISTRICT
CANNONSBURG, KENTUCKY

MISCELLANEOUS DETAILS


DIVISION	-
CONTRACT NO.	691-21-01
DATE	SEPTEMBER 2021
SHEET NO.	15 OF 17

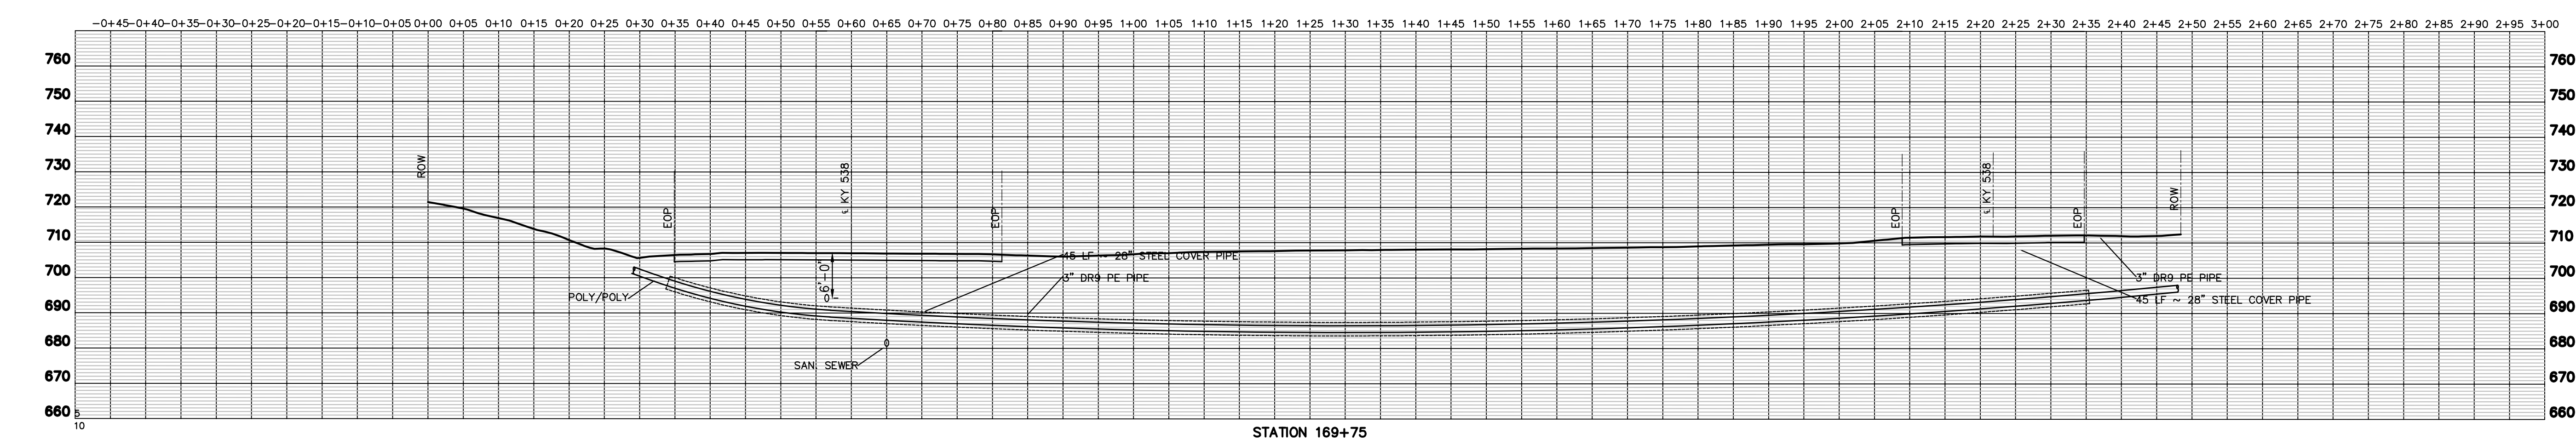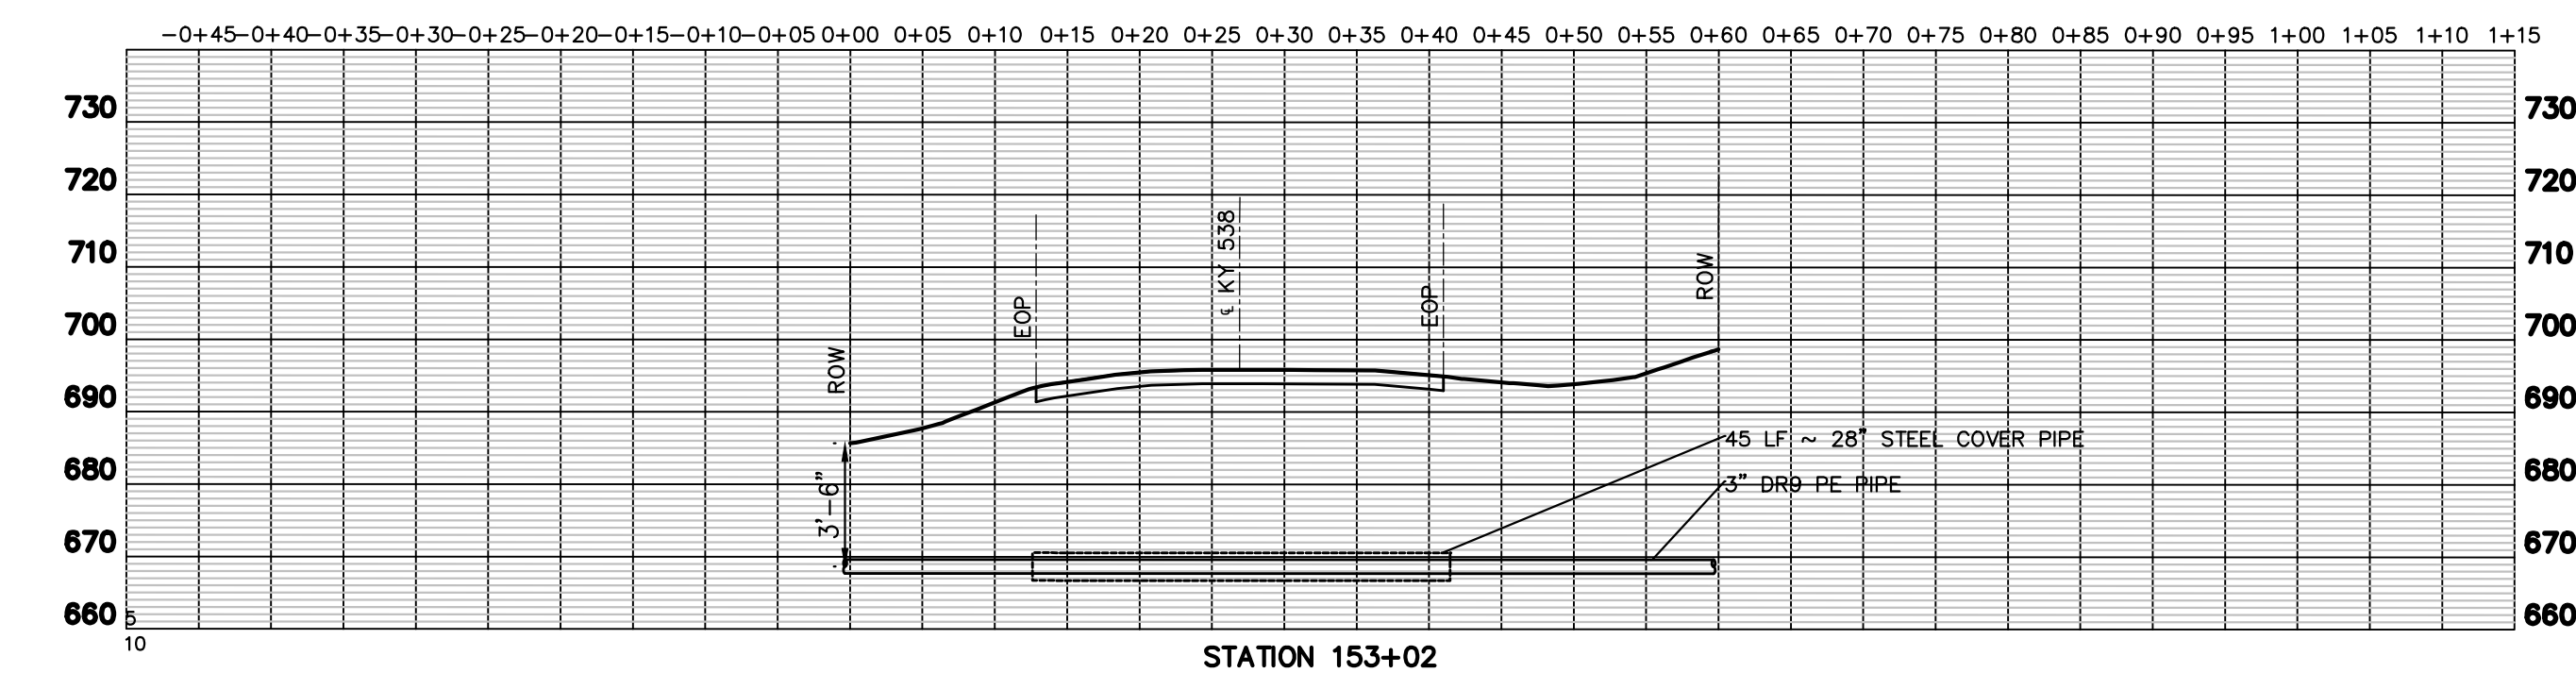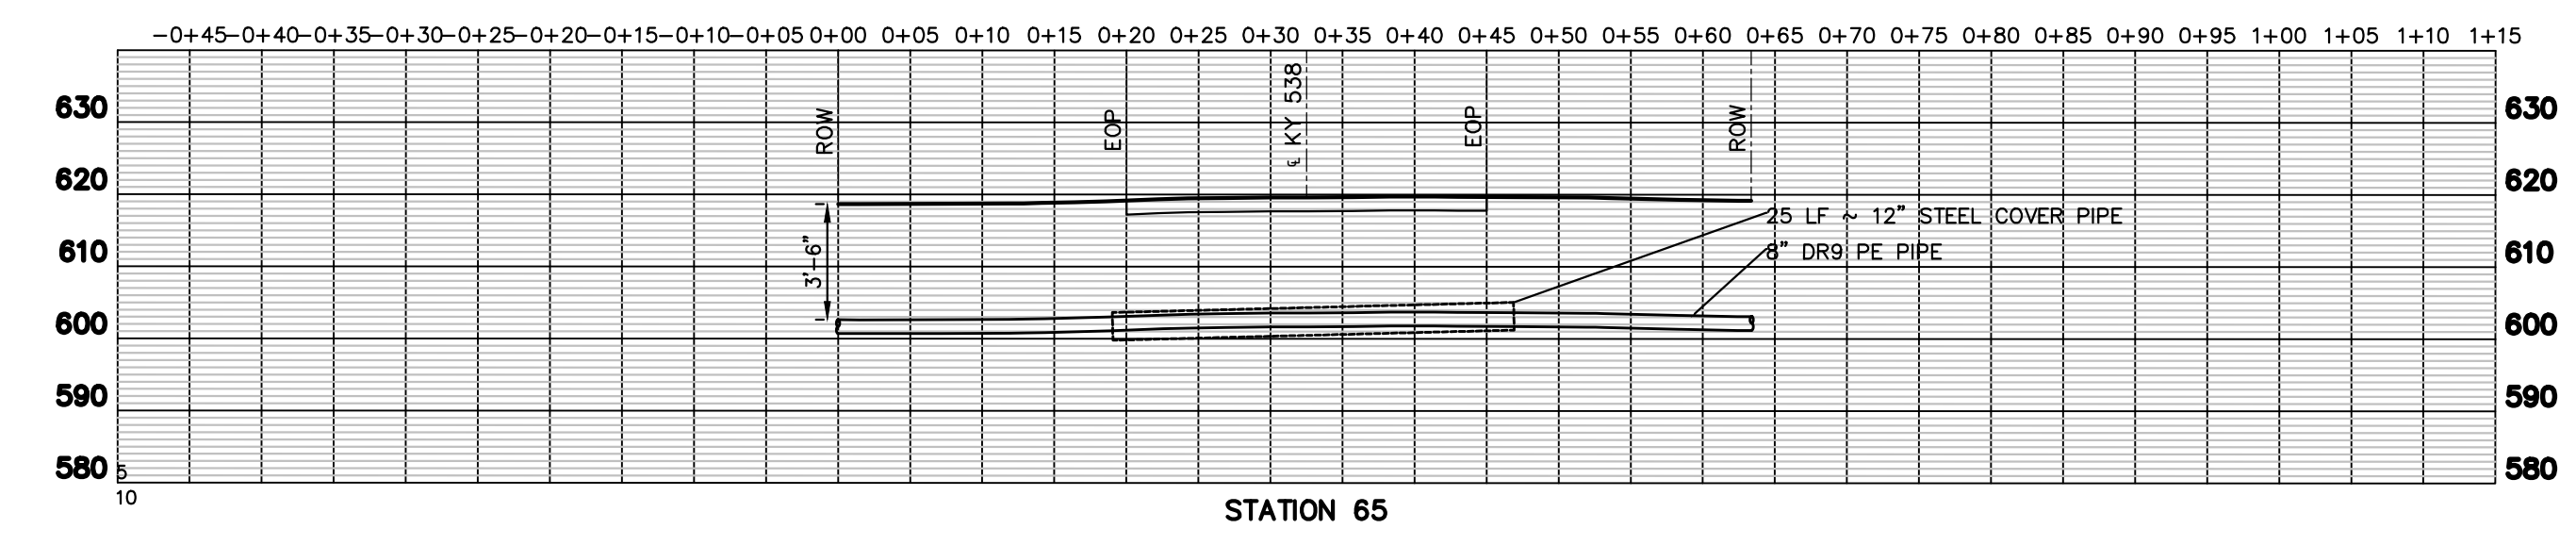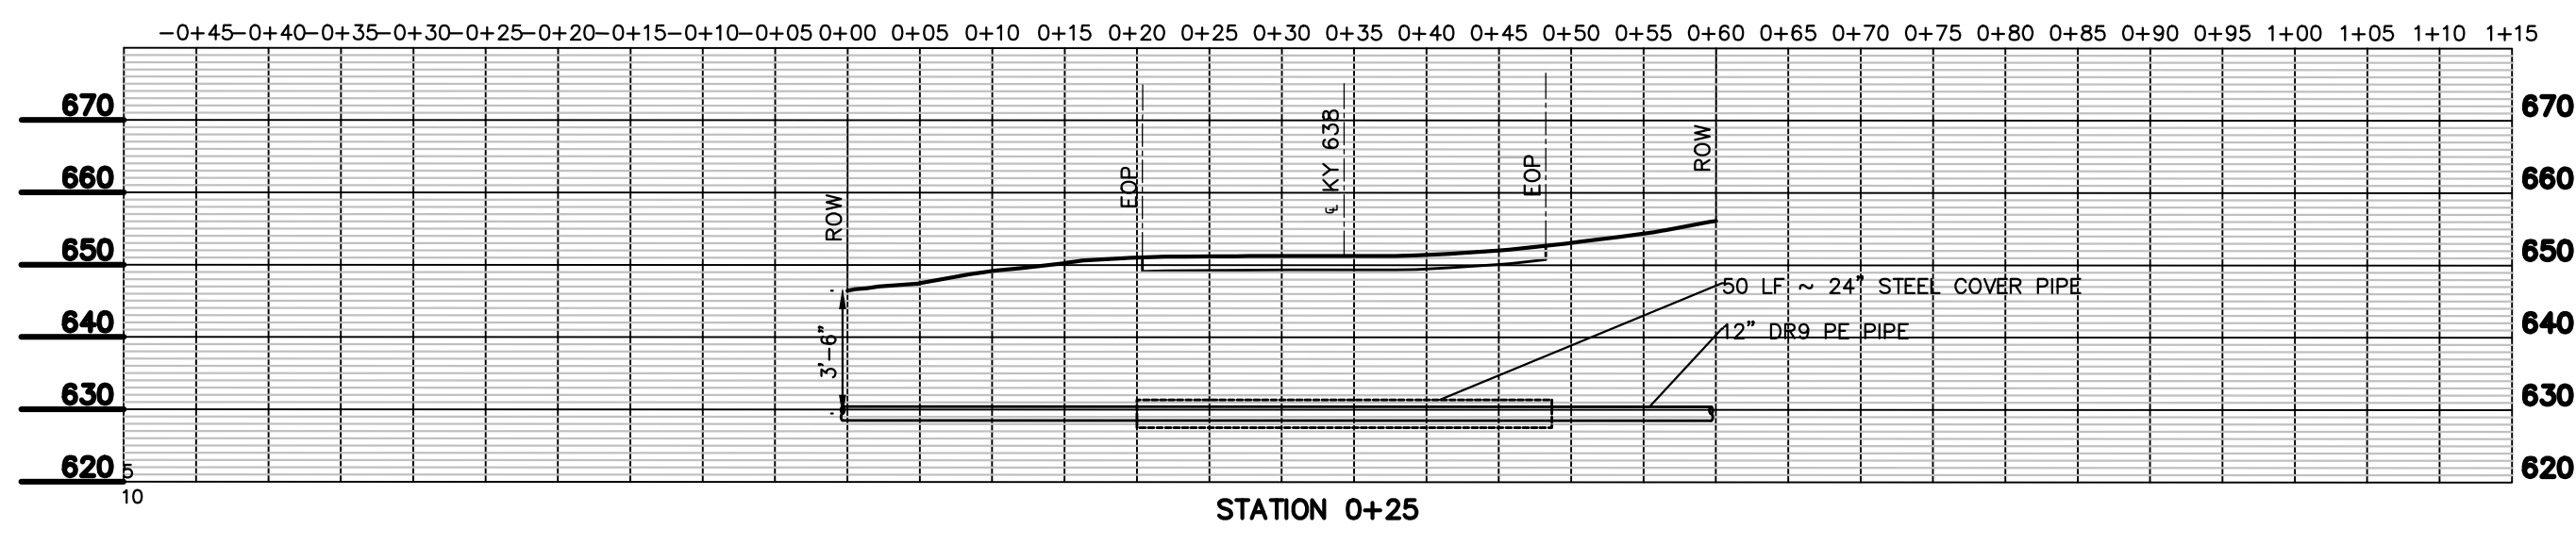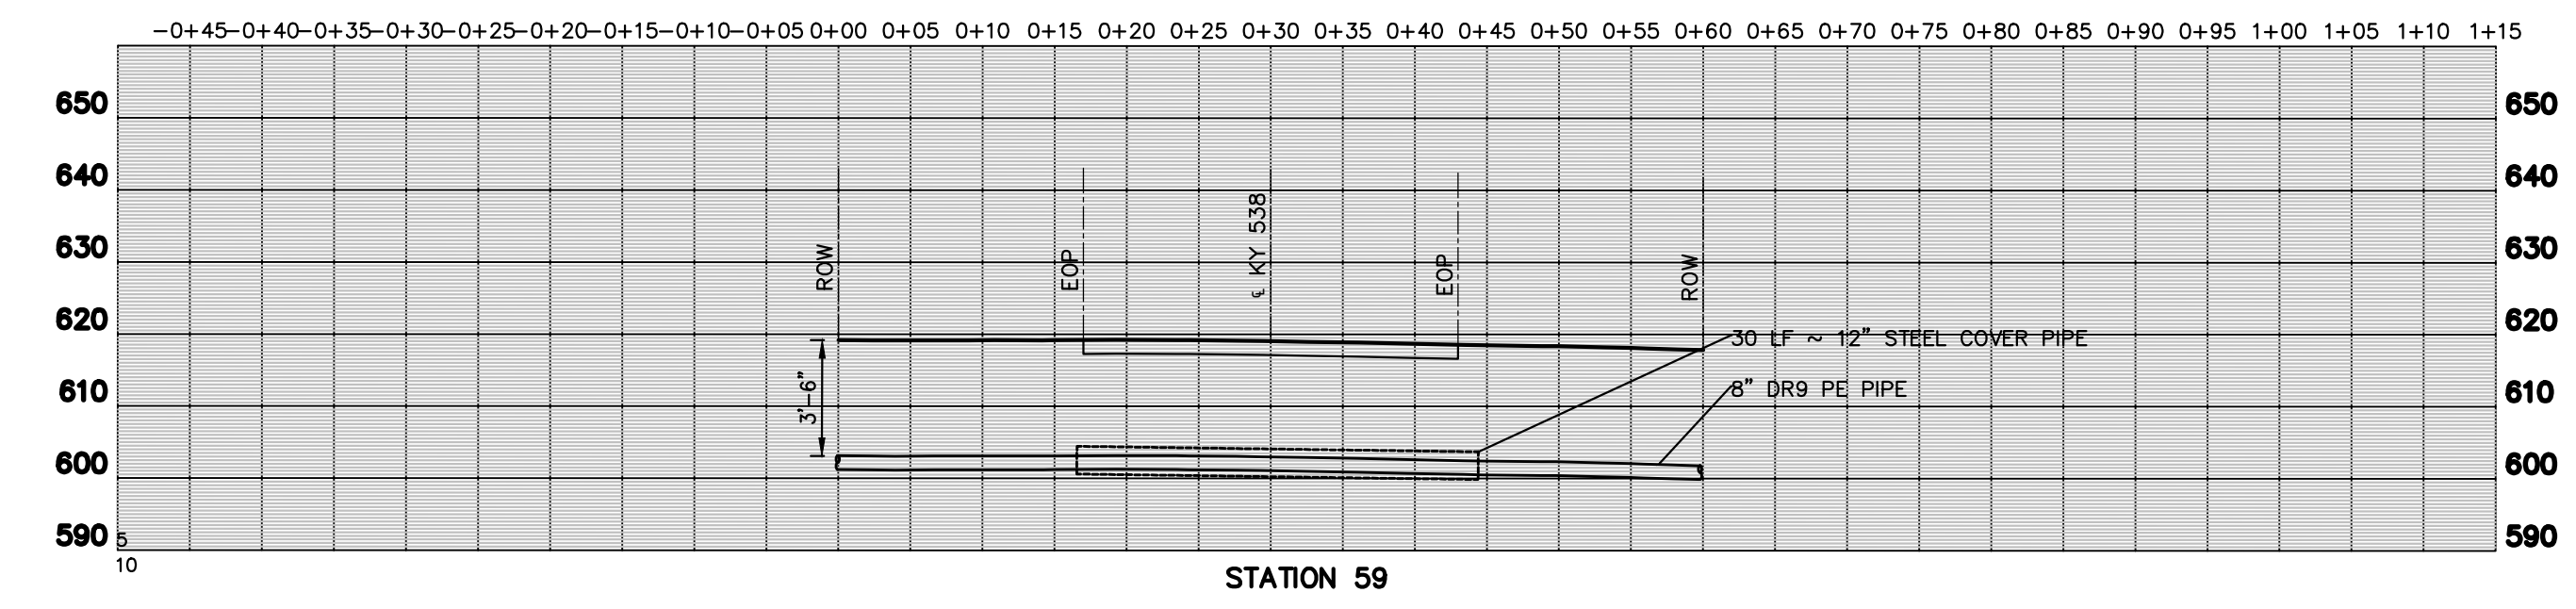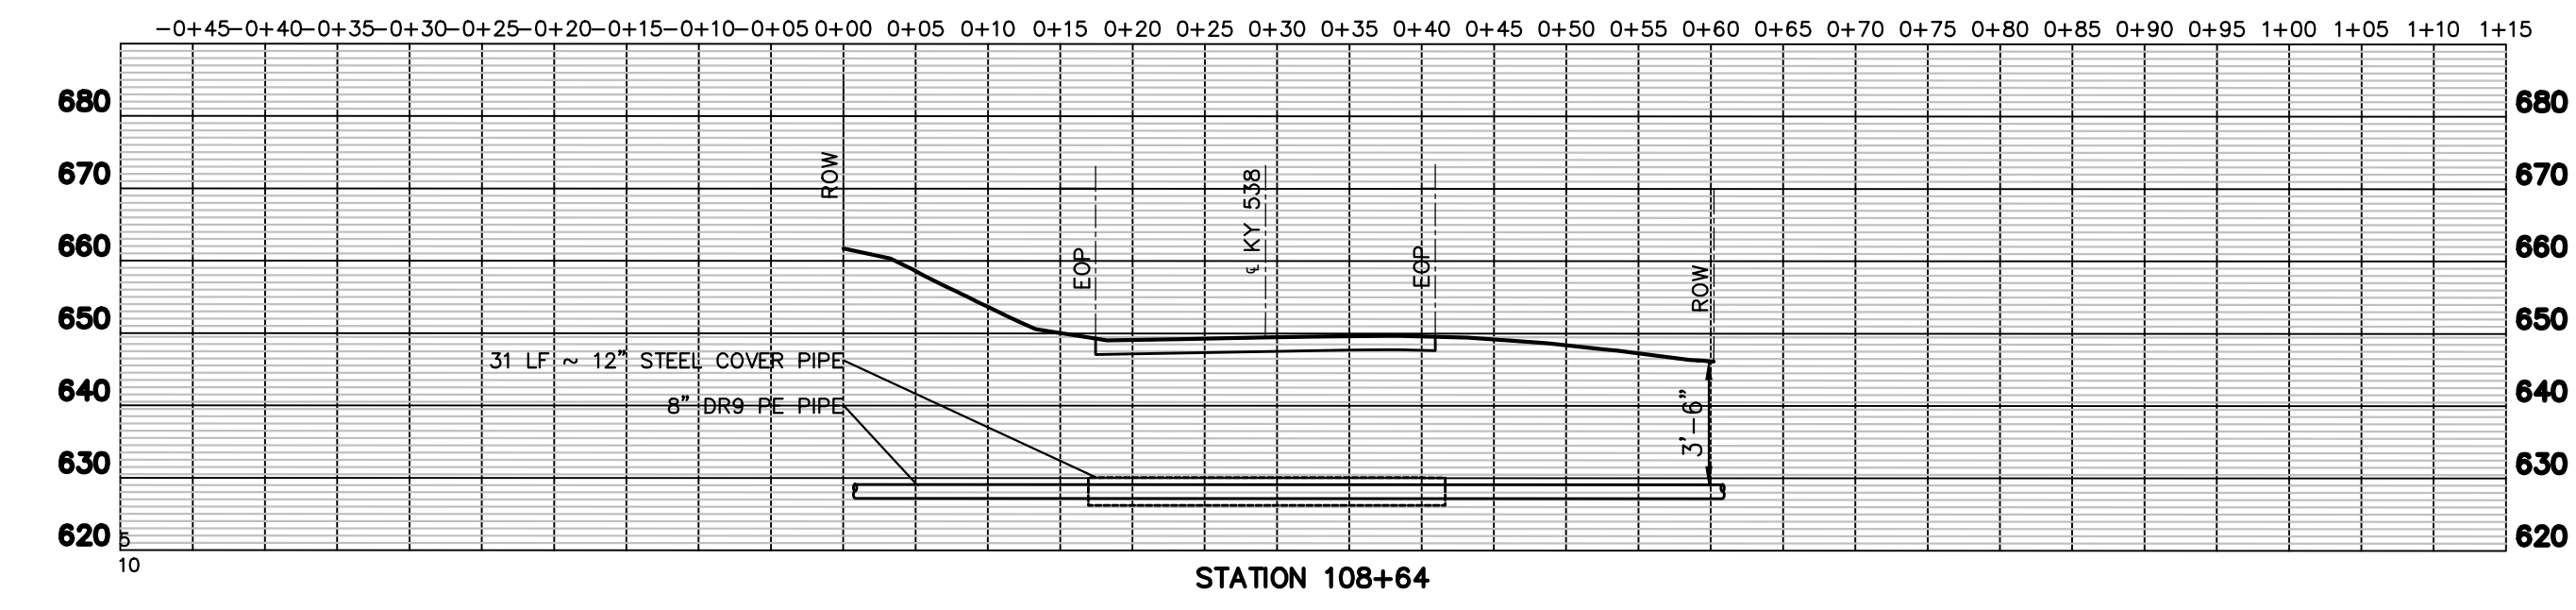


J:\CANNONBURG\SHOPS CREEK ROAD AREA\CAD Design\12-69121DW16.dwg, 16, 12/2/2024, 11:03:34 AM, lweiser, AutoCAD PDF (General Documentation).pc3

J:\CANNONBURG\SHOPS CREEK ROAD AREA\CAD Design\12-69121DW16.dwg-16, Plotted Mon, 02 Dec 2024 - 11:03am by lweiser

DESIGNER	DEG	DATE	BY	REVISION
DRAWN	TEW			
CHECKED	DEG			
APPROVED	DEG			

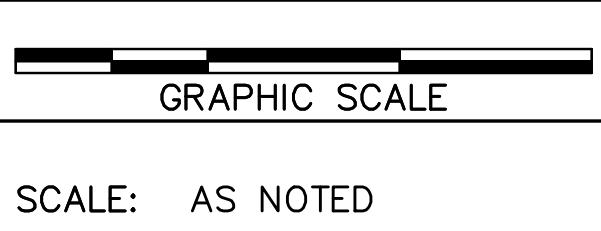

ALL RIGHTS RESERVED
THIS DOCUMENT IS THE PROPERTY OF BELL ENGINEERING AND SHALL NOT BE REPRODUCED IN WHOLE OR IN PART OR USED FOR CONSTRUCTION OF OTHER THAN THIS SPECIFIC PROJECT WITHOUT THE WRITTEN PERMISSION OF BELL ENGINEERING.
FACSIMILES OF LICENSED PROFESSIONAL ENGINEER AND/OR LAND SURVEYOR SEALS, IF AFFIXED TO THIS DOCUMENT, SHALL BE CONSIDERED LEGITIMATE ONLY IF SIGNED AND DATED BY THE REGISTRANT.

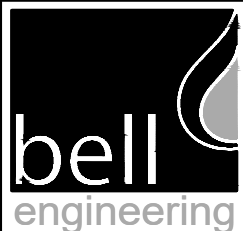


Lexington, KY (859) 278-5412
Hopkinsville, KY (270) 886-5466
Somerset, KY (606) 485-4011

WATER SYSTEM IMPROVEMENTS
SHOPS CREEK ROAD AREA
CANNONBURG WATER DISTRICT
CANNONBURG, KENTUCKY


PIPELINE ROAD CROSSING SECTIONS

DIVISION	—
CONTRACT NO.	691-21-01
DATE	SEPTEMBER 2021
SHEET NO.	16 OF 17




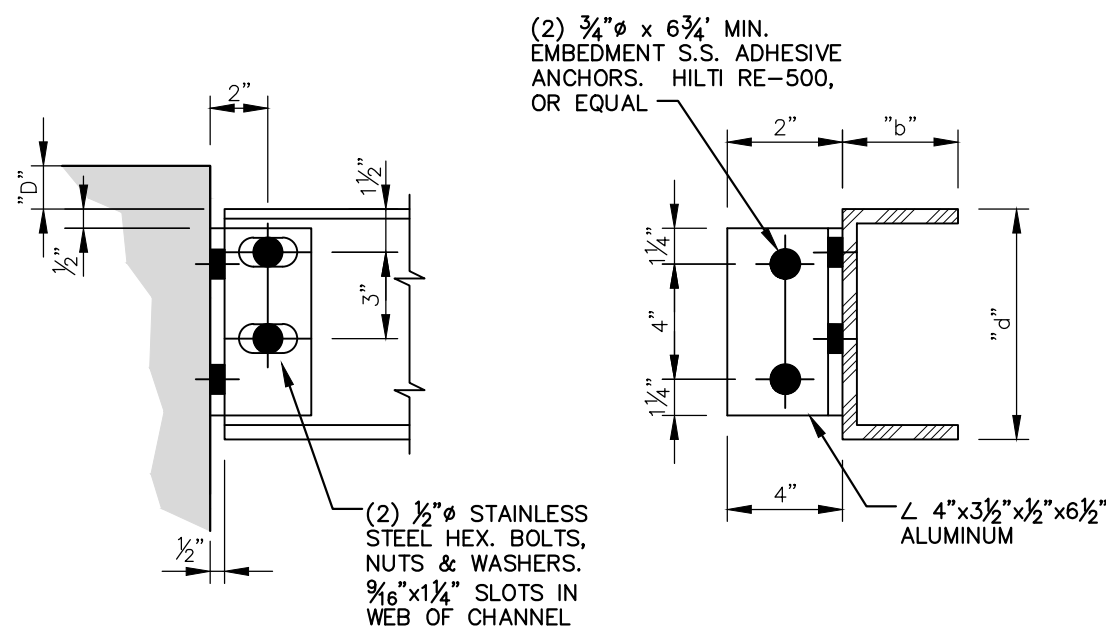

GRATING SUPPORT BEAM CONNECTION
TYPE 1

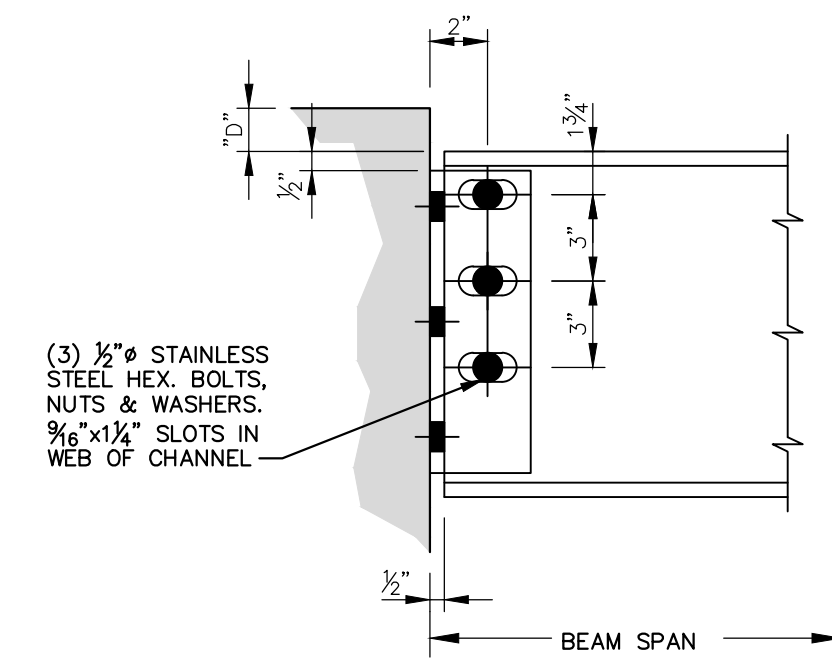


GRATING SUPPORT BEAM CONNECTION
TYPE 2

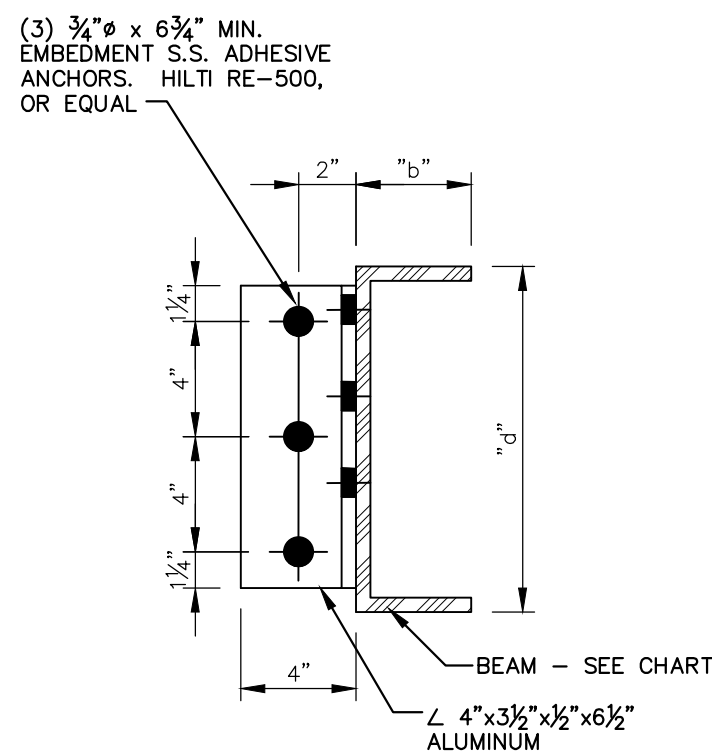


GRATING SUPPORT BEAM CHART					
BEAM SPAN (FEET)	6	8	10	12	14
BEAM SIZE *	C6 x 3.25	C8 x 3.75	C10 x 4.25	C12 x 5.0	C12 x 5.0
WEIGHT (LB./FT.)	4.030	5.789	8.360	11.822	11.822
BEAM CONNECTION TYPE	1	1	2	2	2

* BEAMS ARE ALUMINUM ASSOCIATION STANDARD CHANNELS. SIZES SHOWN ARE DEPTH d x FLANGE WIDTH b.

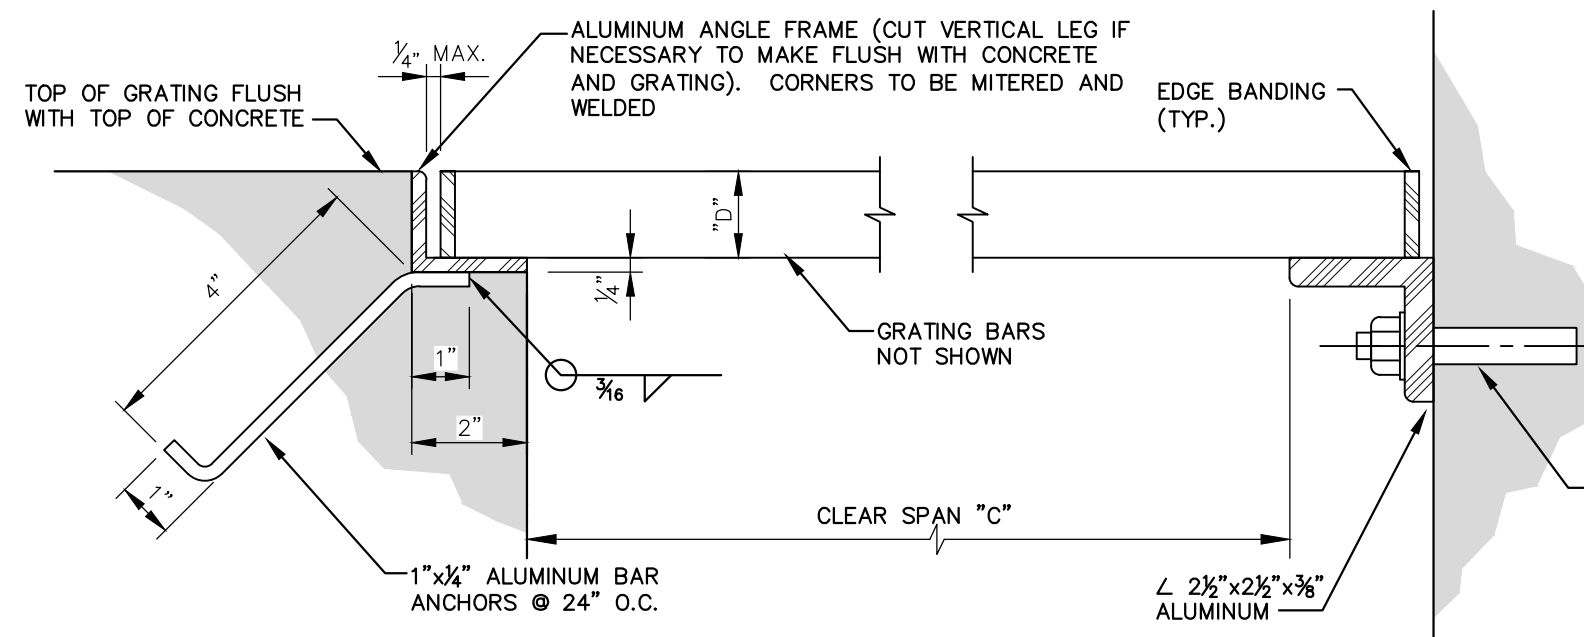

EMBEDDED SUPPORT

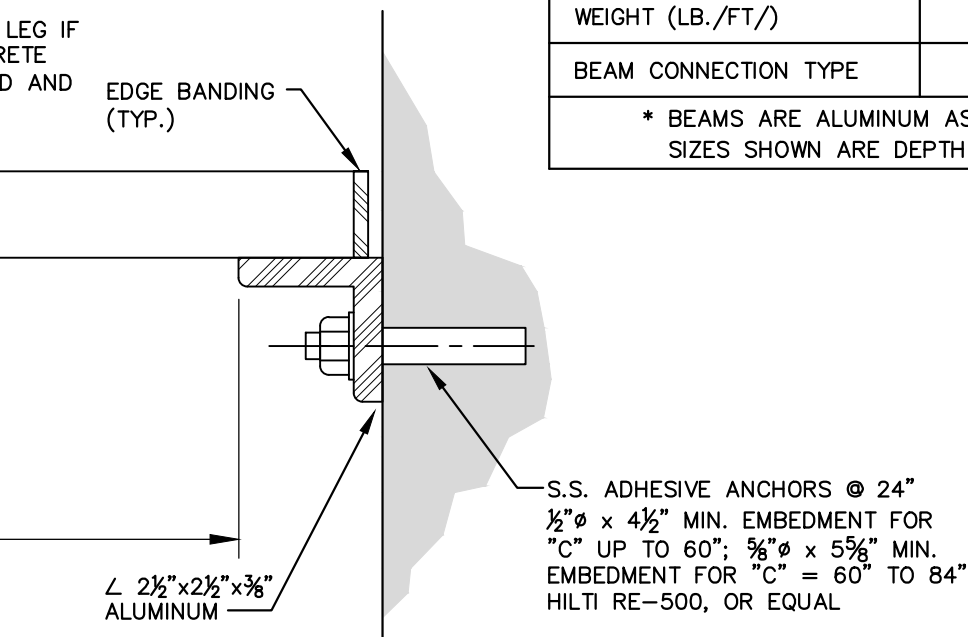


SURFACE MOUNTED SUPPORT

ALUMINUM GRATING DETAILS
NOT TO SCALE


GRATING SCHEDULE	
SPAN	DEPTH (MIN.)
0'-0" TO 3'-0"	1"
3'-0" TO 4'-0"	1 1/4"
4'-0" TO 4'-6"	1 1/2"
4'-6" TO 5'-0"	1 3/4"
5'-0" TO 5'-6"	2"
5'-6" TO 6'-0"	2 1/4"
6'-0" TO 6'-6"	2 1/2"

GRATING SHALL NOT SPAN MORE THAN 6'-6" UNLESS SPECIAL PROVISION IS MADE BY THE ENGINEER.


NOTE: UNLESS OTHERWISE NOTED, GRATING SHALL BE ALUMINUM I-BAR TYPE WITH MINIMUM 3/16" BEARING BARS SPACED NOT MORE THAN 1 3/8" C/C AND CROSS BARS SPACED NOT MORE THAN 4" C/C. COORDINATE SCHEDULE WITH STRUCTURE PLANS. PROVIDE SAME DEPTH WHERE REQUIRED TO MATCH ADJACENT SPANS IN SAME OR ADJOINING STRUCTURES

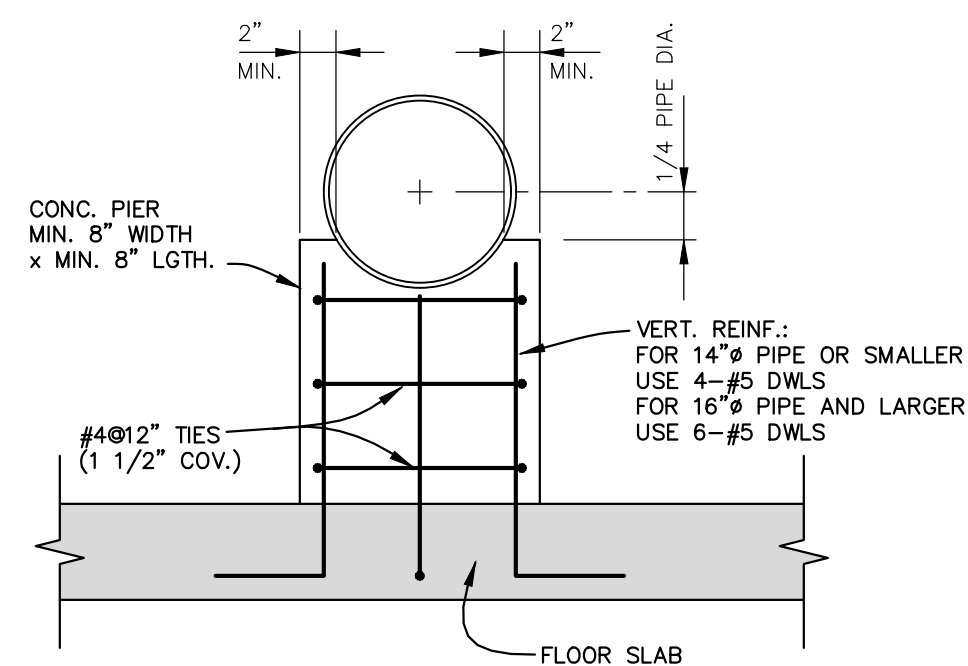


TYPICAL CONCRETE PIPE SUPPORT
PIER TO CONCRETE FLOOR
NOT TO SCALE

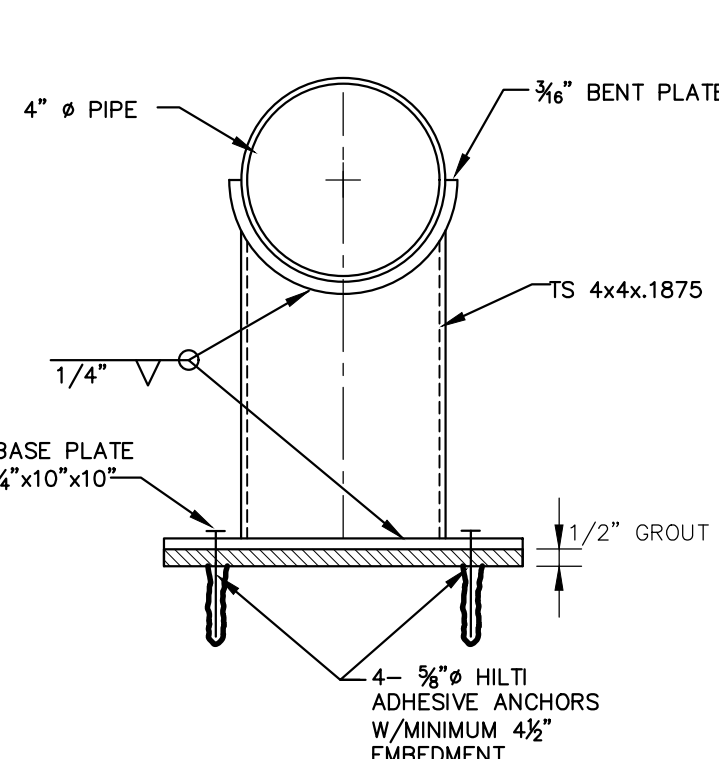


PIPE SUPPORT
NOT TO SCALE

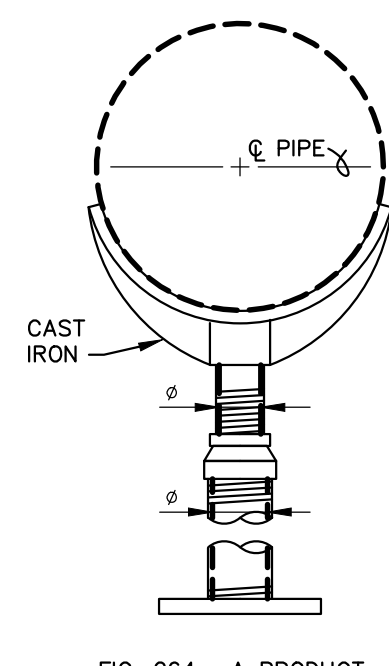


ADJUSTABLE PIPE
SADDLE SUPPORT
NOT TO SCALE

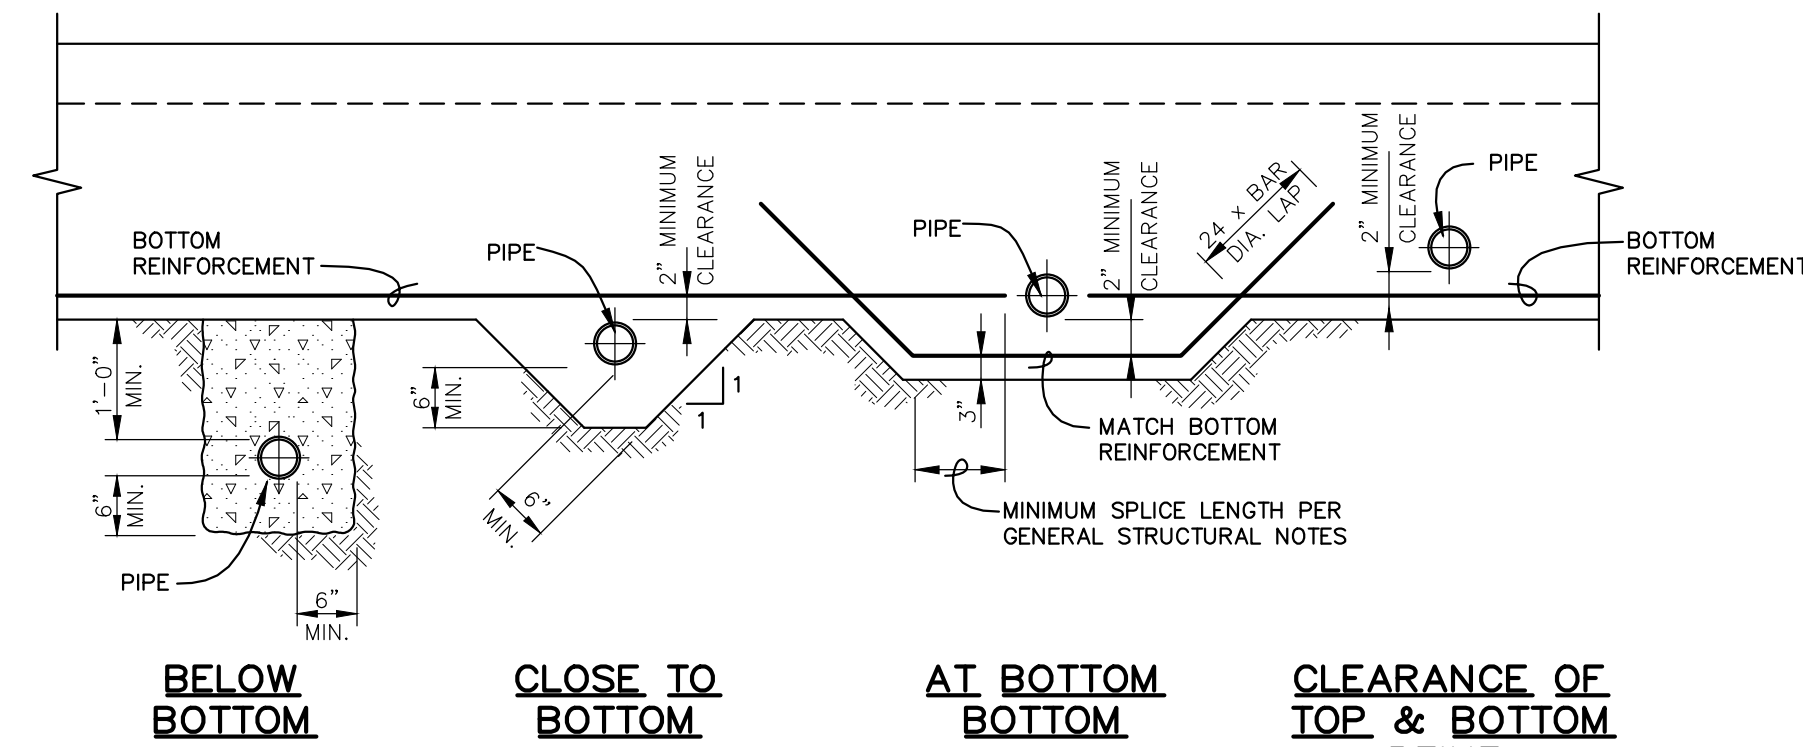


PIPE PERPENDICULAR TO
GRADE BEAM OR FOOTING
NOT TO SCALE

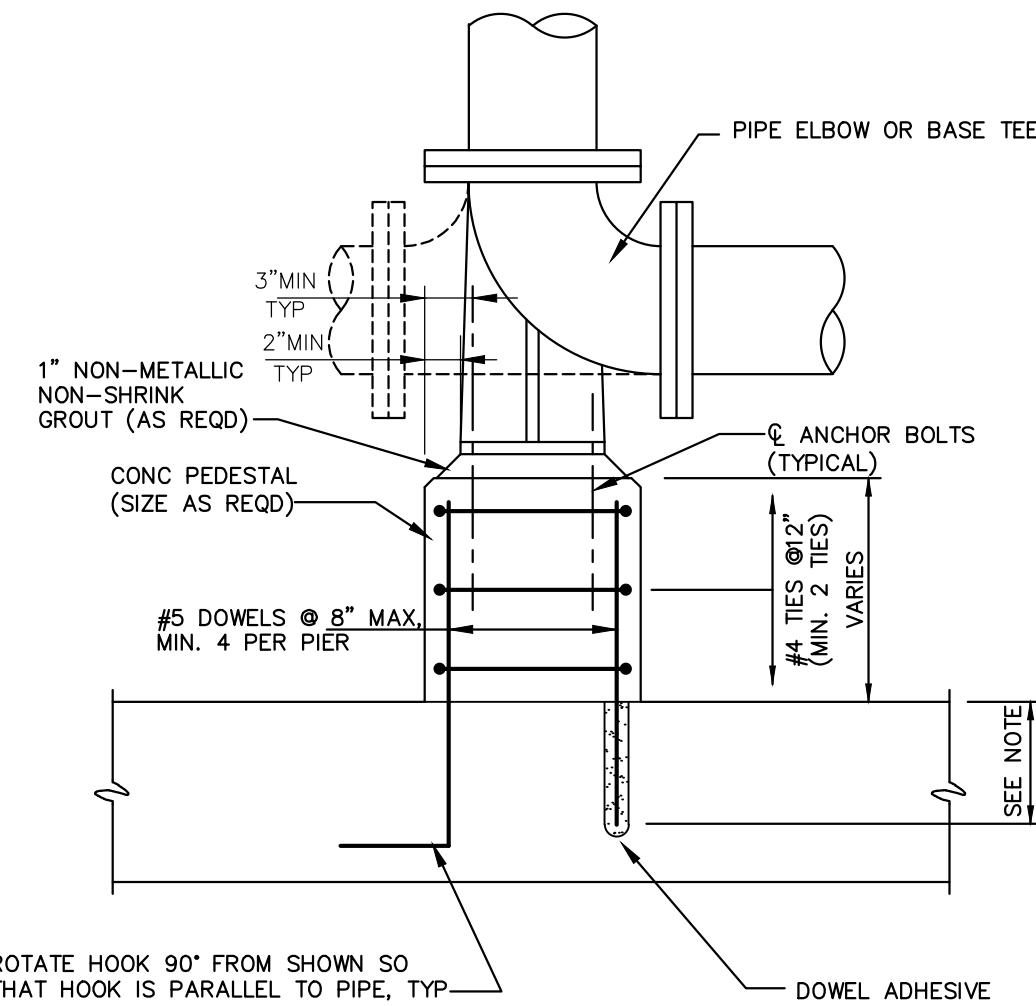


SUPPORT PIER UNDER
BASE ELBOW OR BASE TEE
NOT TO SCALE

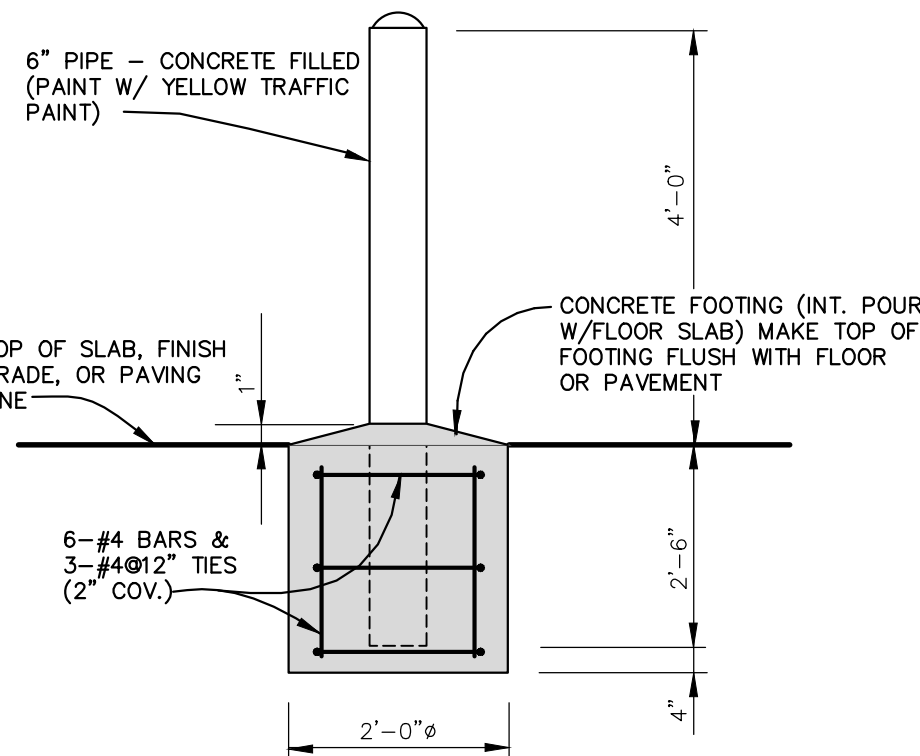


DETAIL - GUARD POST
NOT TO SCALE

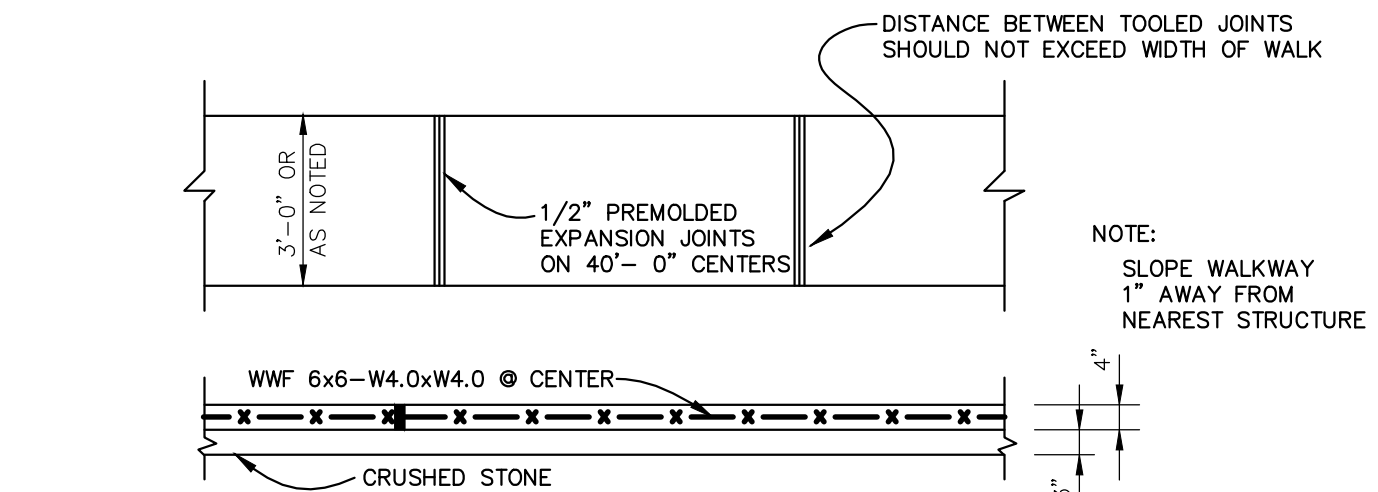


TYPICAL EXTERIOR WALKS
NOT CANTILEVERED FROM STRUCTURES
NOT TO SCALE

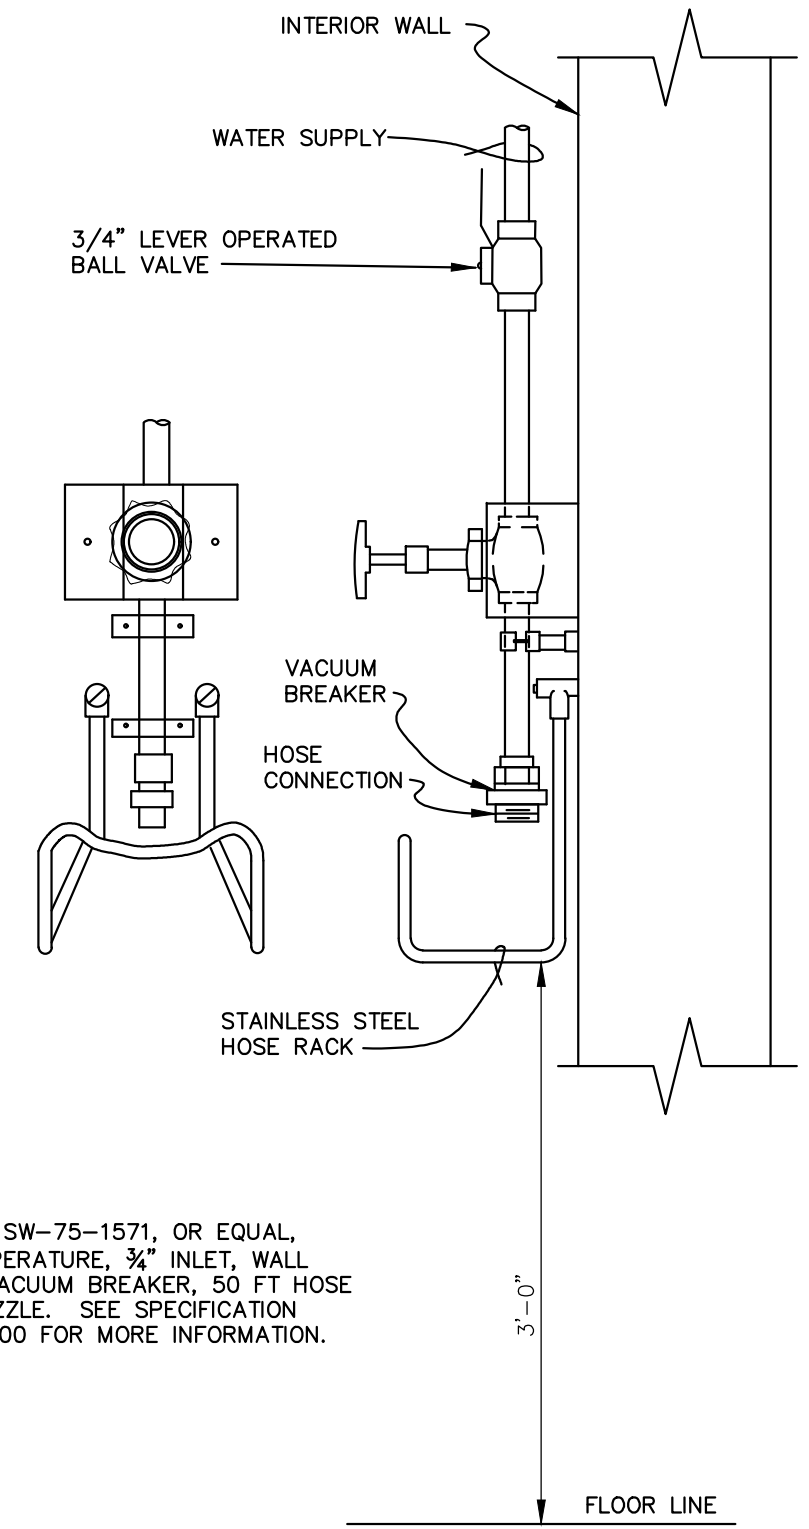


SINGLE TEMPERATURE HOSE STATION
(BLENDING HOSE STATION SIMILAR)
NOT TO SCALE

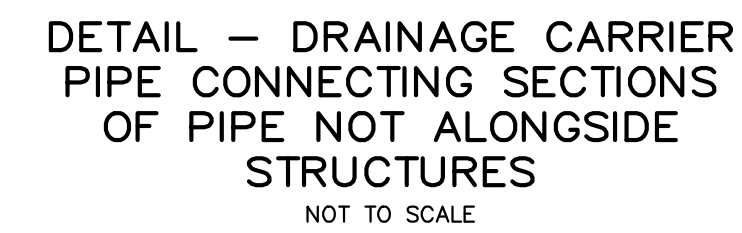


DETAIL - DRAINAGE CARRIER
PIPE CONNECTING SECTIONS
OF PIPE NOT ALONGSIDE
STRUCTURES
NOT TO SCALE

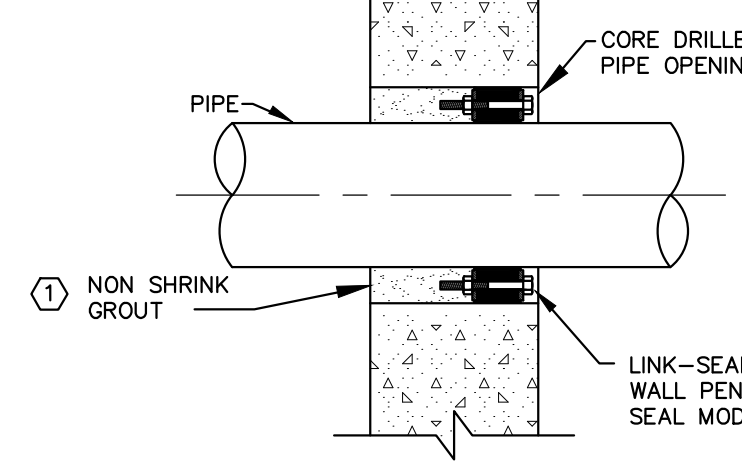


CORE PIPE OPNG. IN NEW
OR EXISTING WALL OR SLAB

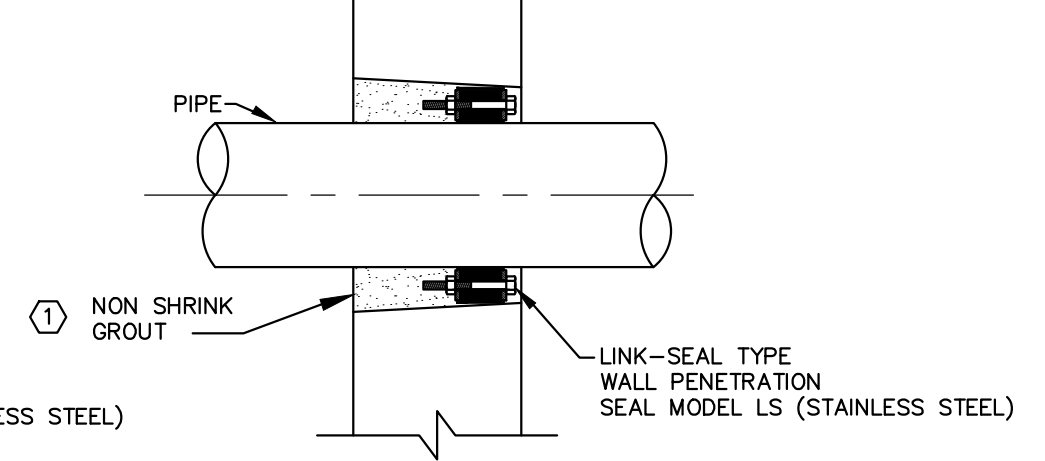

BOX-OUT PIPE OPNG. IN NEW
WALL OR SLAB

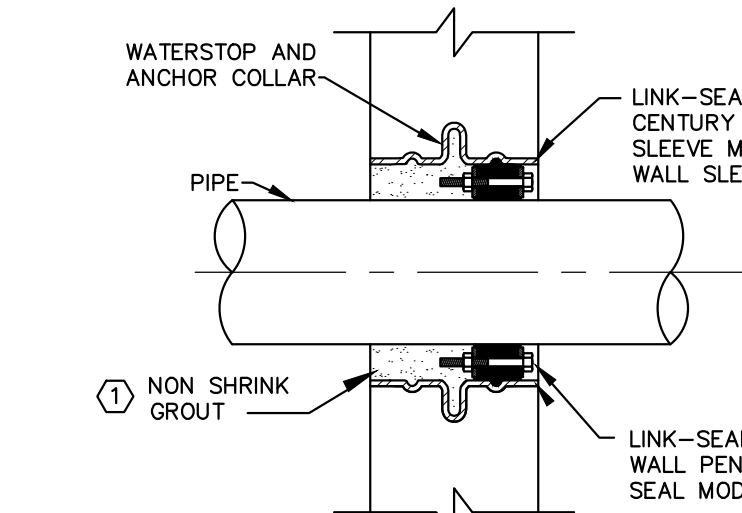


WALL SLEEVE IN NEW
WALL OR SLAB

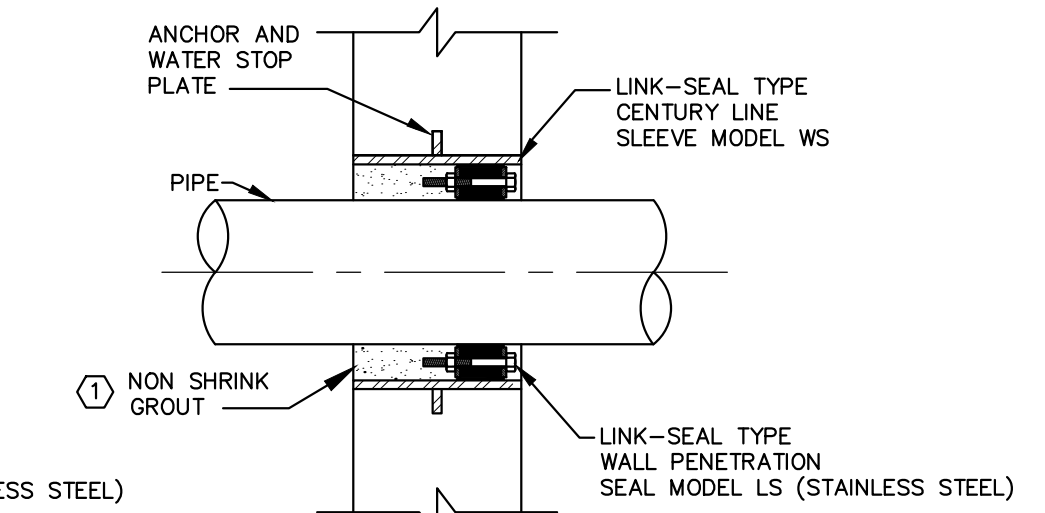

WALL SLEEVE IN NEW
WALL OR SLAB

PIPE PENETRATION THROUGH
CONCRETE WALLS AND SLABS
NOT TO SCALE

① WHERE LINK-SEALS ARE CALLED FOR GROUT SHALL NOT BE USED UNLESS THE CAVITY LEAKS WATER AND ALL POSSIBLE ADJUSTMENTS TO THE LINK-SEAL(S) HAVE BEEN MADE. IF THE CAVITY IS FOUND TO LEAK WATER PRIOR TO OR DURING THE WARRANTY PERIOD THE CONTRACTOR SHALL ADJUST LINK-SEAL(S) TO FIX THE PROBLEM. IF IT IS DETERMINED THAT THE LINK-SEAL ALONE CANNOT ELIMINATE THE LEAKING, THE CONTRACTOR SHALL PLACE NON-SHRINK GROUT IN THE CAVITY AS SHOWN.

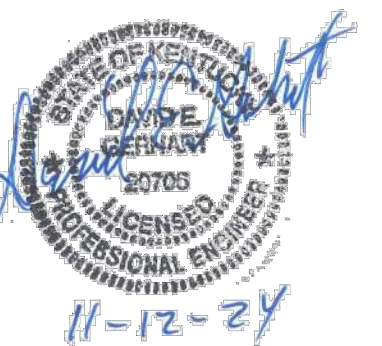


DESIGNER	DEG	DATE	BY	REVISION
DRAWN	TEW			
CHECKED	DEG			
APPROVED	DEG			

GRAPHIC SCALE	
SCALE:	AS NOTED

ALL RIGHTS RESERVED
THIS DOCUMENT IS THE PROPERTY OF BELL ENGINEERING AND SHALL NOT BE REPRODUCED IN WHOLE OR IN PART OR USED FOR CONSTRUCTION OF OTHER THAN THIS SPECIFIC PROJECT WITHOUT THE WRITTEN PERMISSION OF BELL ENGINEERING. FACSIMILES OF LICENSED PROFESSIONAL ENGINEER AND/OR LAND SURVEYOR SEALS, IF AFFIXED TO THIS DOCUMENT, SHALL BE CONSIDERED LEGITIMATE ONLY IF SIGNED AND DATED BY THE REGISTRANT.



Lexington, KY (859) 278-5412
Hopkinsville, KY (270) 886-5466
Somerset, KY (606) 485-4011

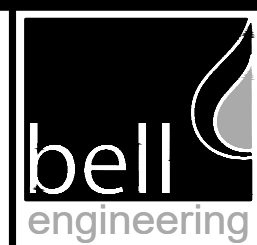

WATER SYSTEM IMPROVEMENTS
SHOPE'S CREEK ROAD AREA
CANNONSBURG WATER DISTRICT
CANNONSBURG, KENTUCKY


MISCELLANEOUS DETAILS

DIVISION	-
CONTRACT NO.	691-21-01
DATE	SEPTEMBER 2021
SHEET NO.	17 OF 17

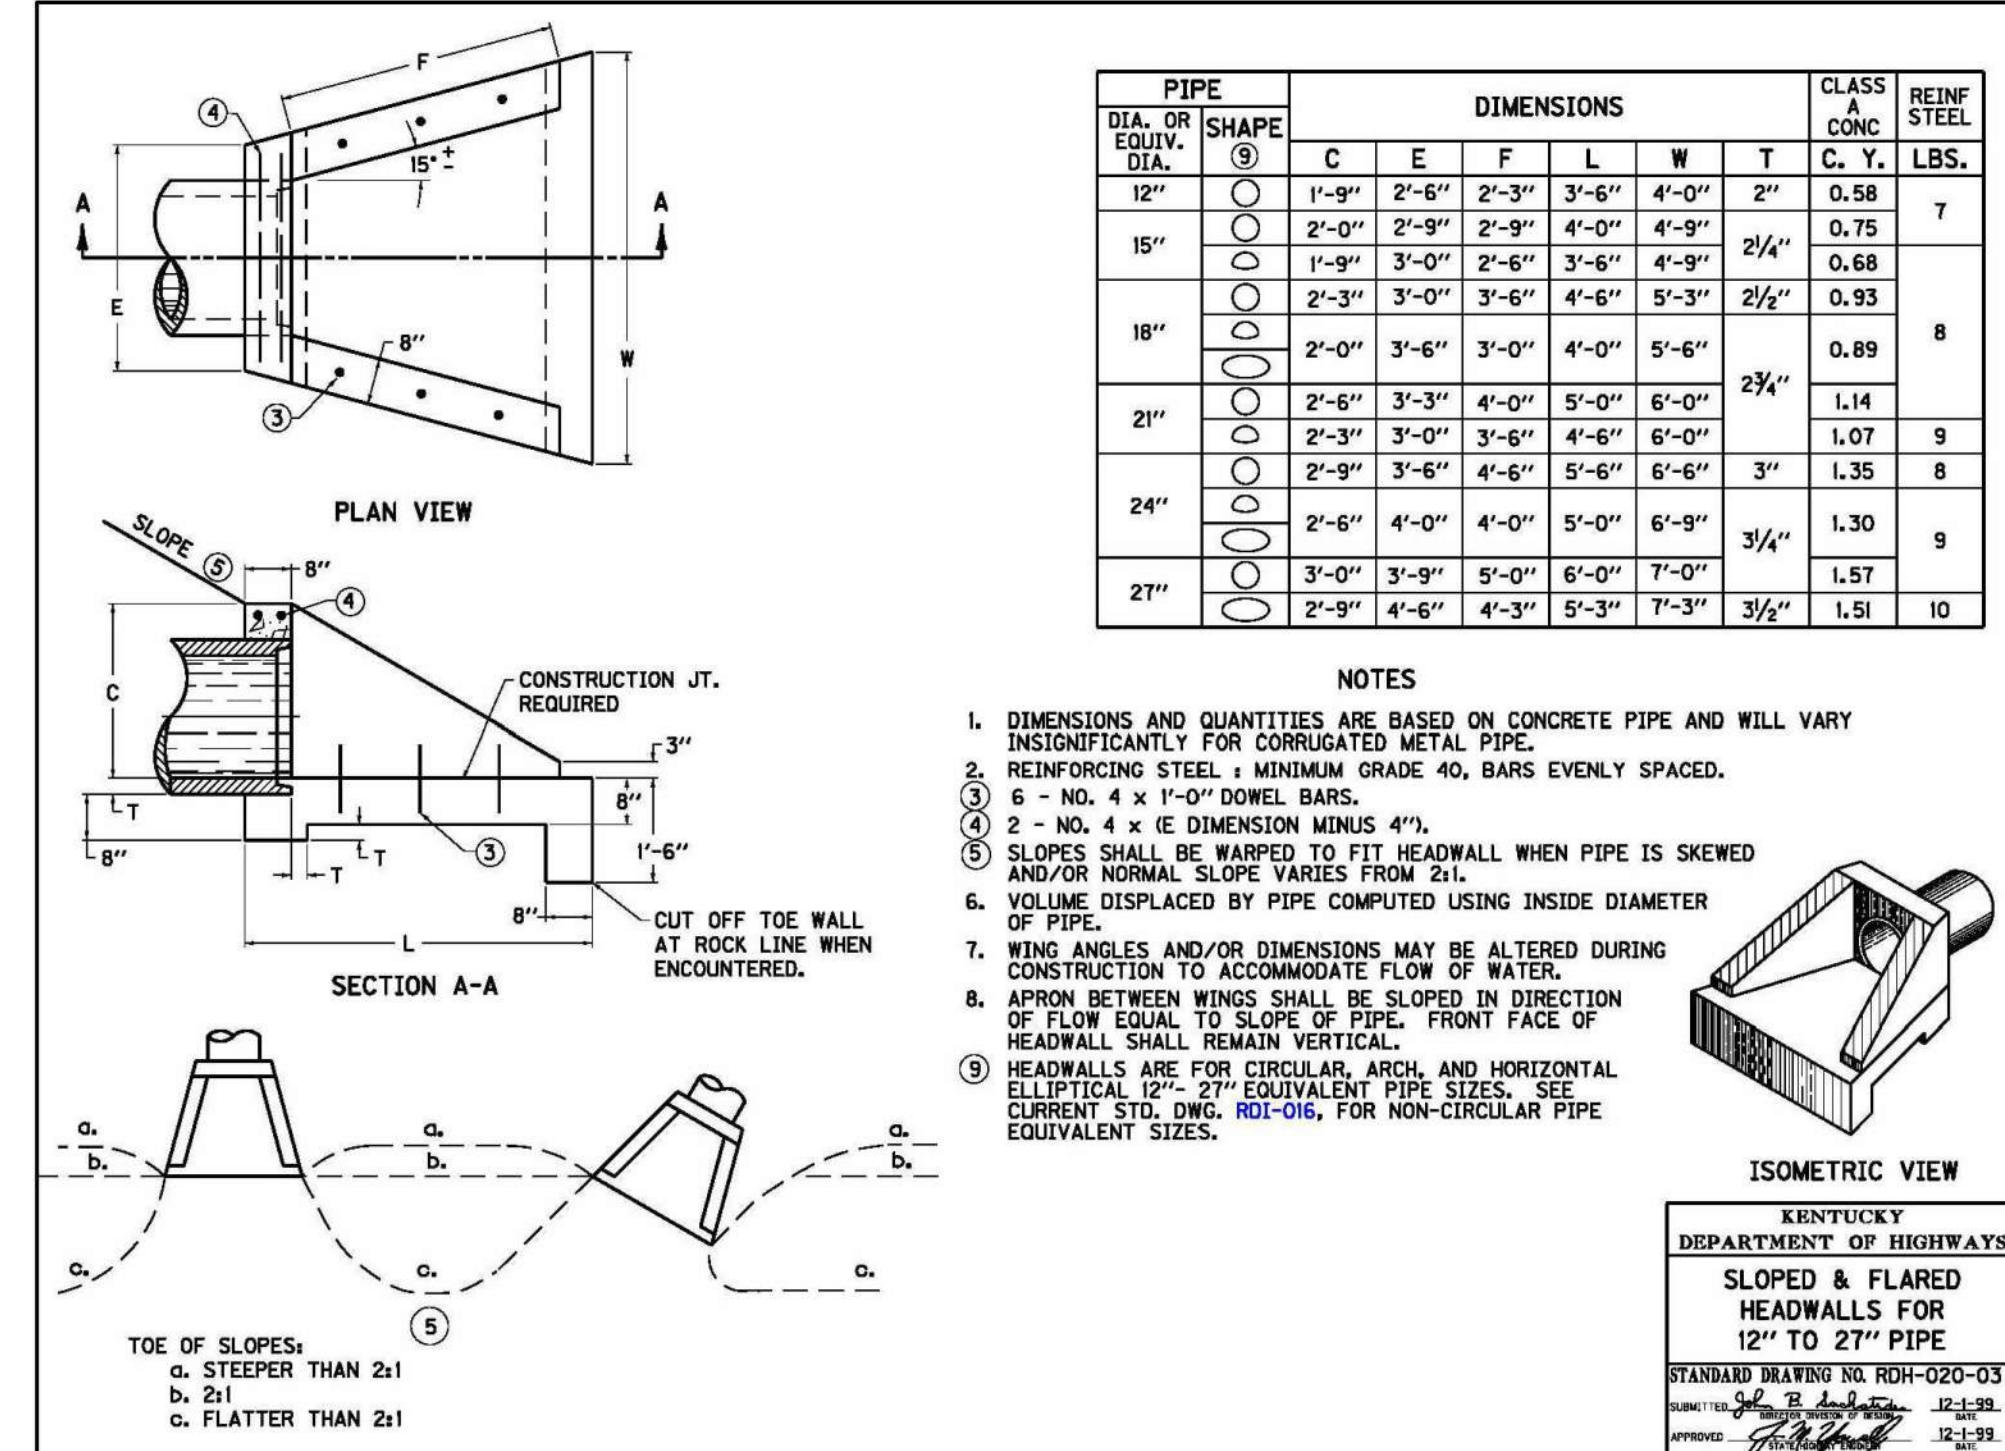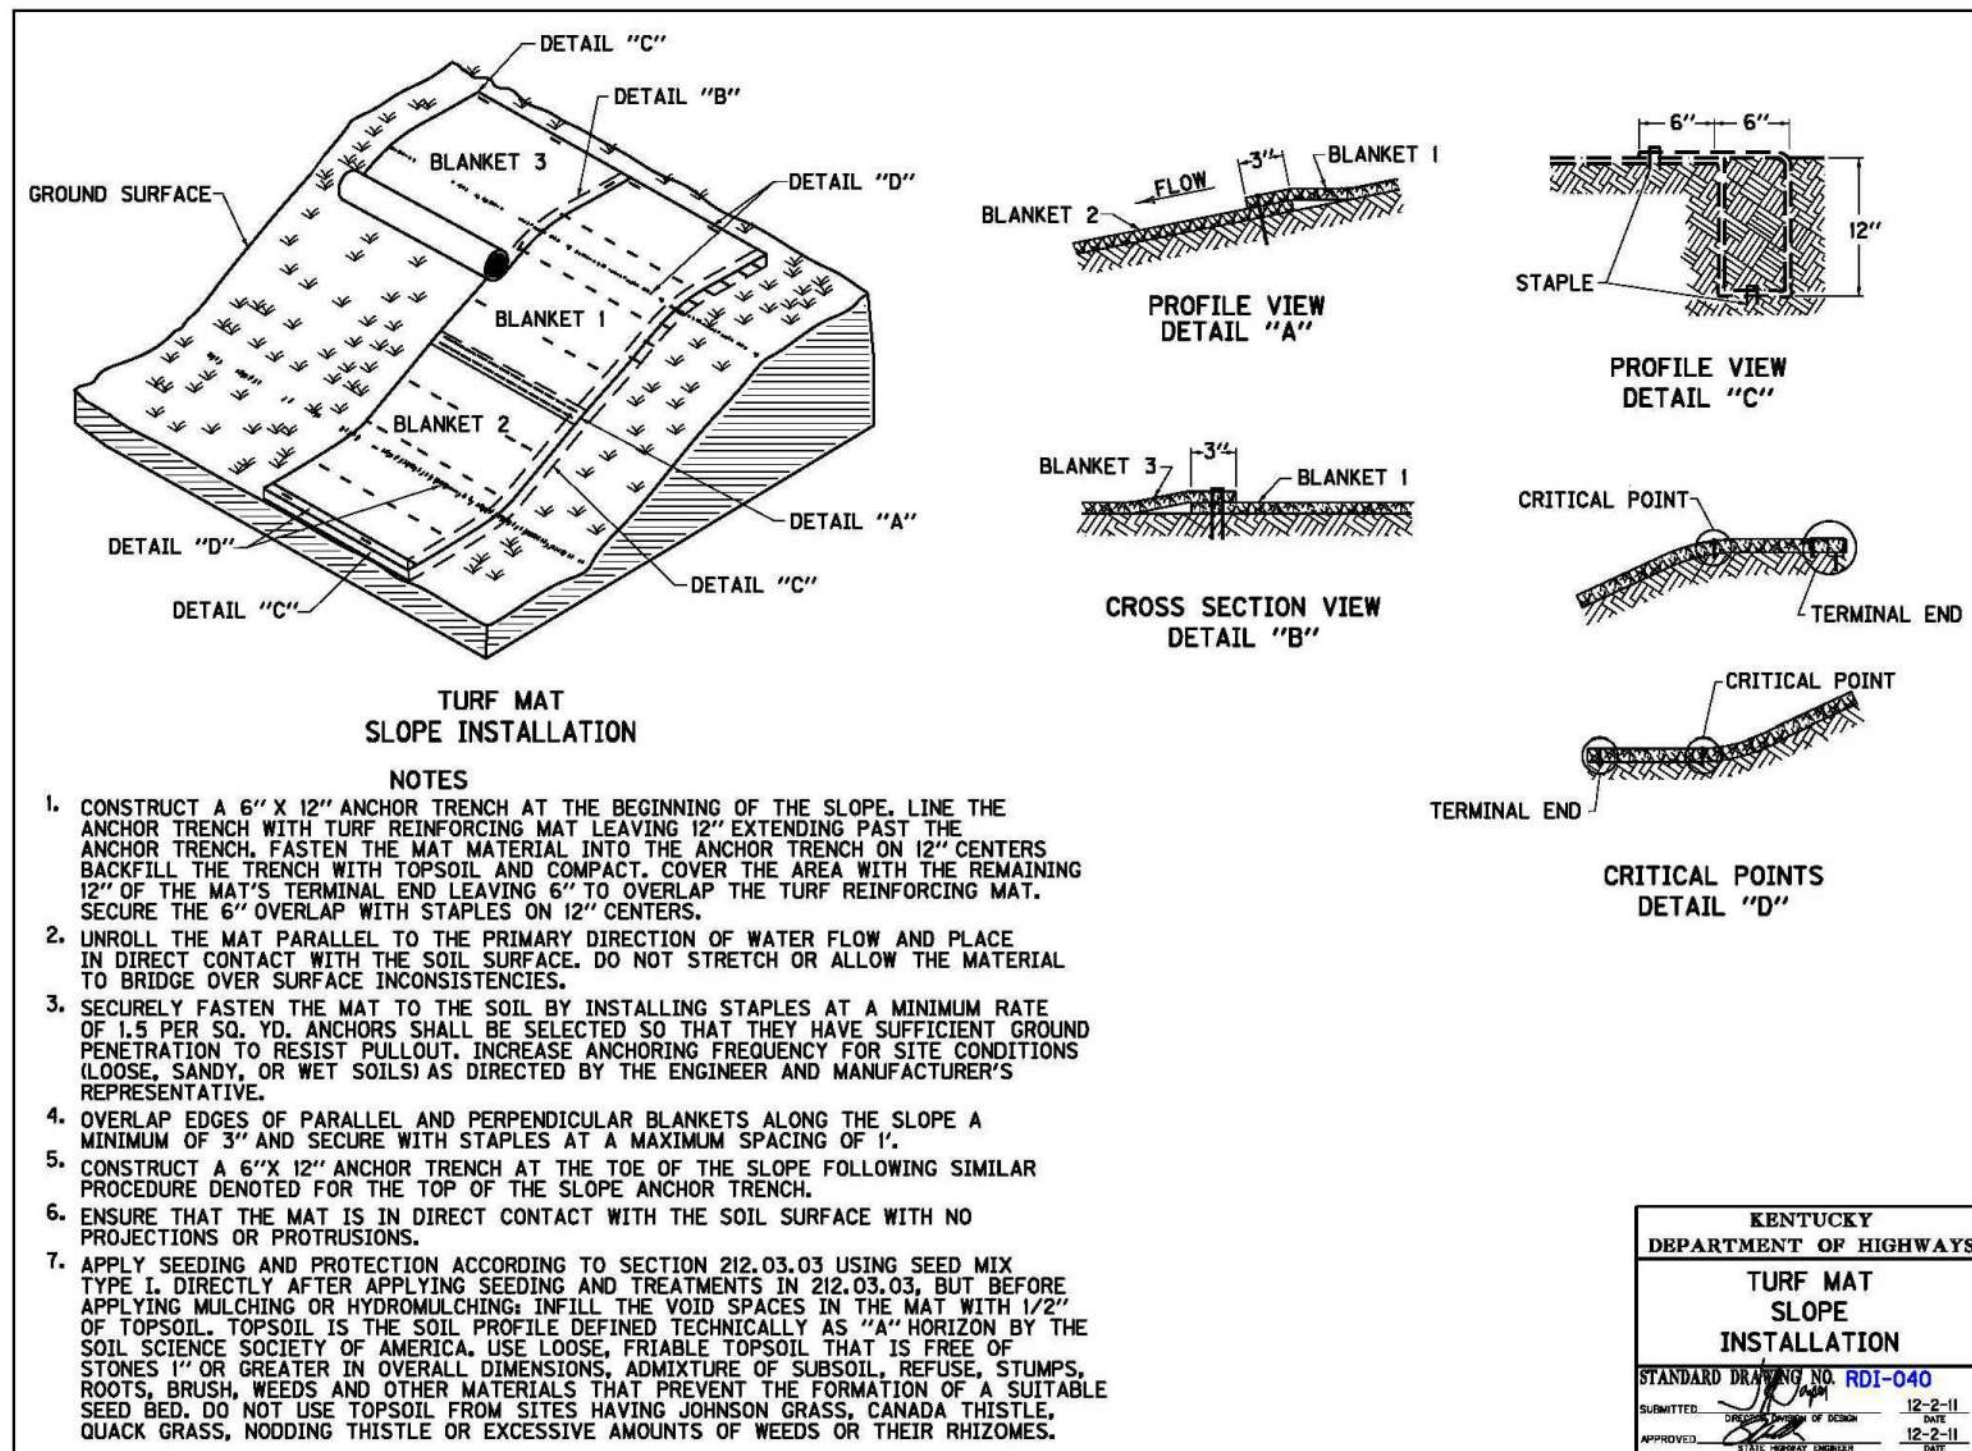


DAVID GERNERT
20705
11-12-24

DIVISION	—		
CONTRACT NO.	691-21-01		
DATE	SEPTEMBER 2021		
SHEET NO.	EC1	OF	EC1

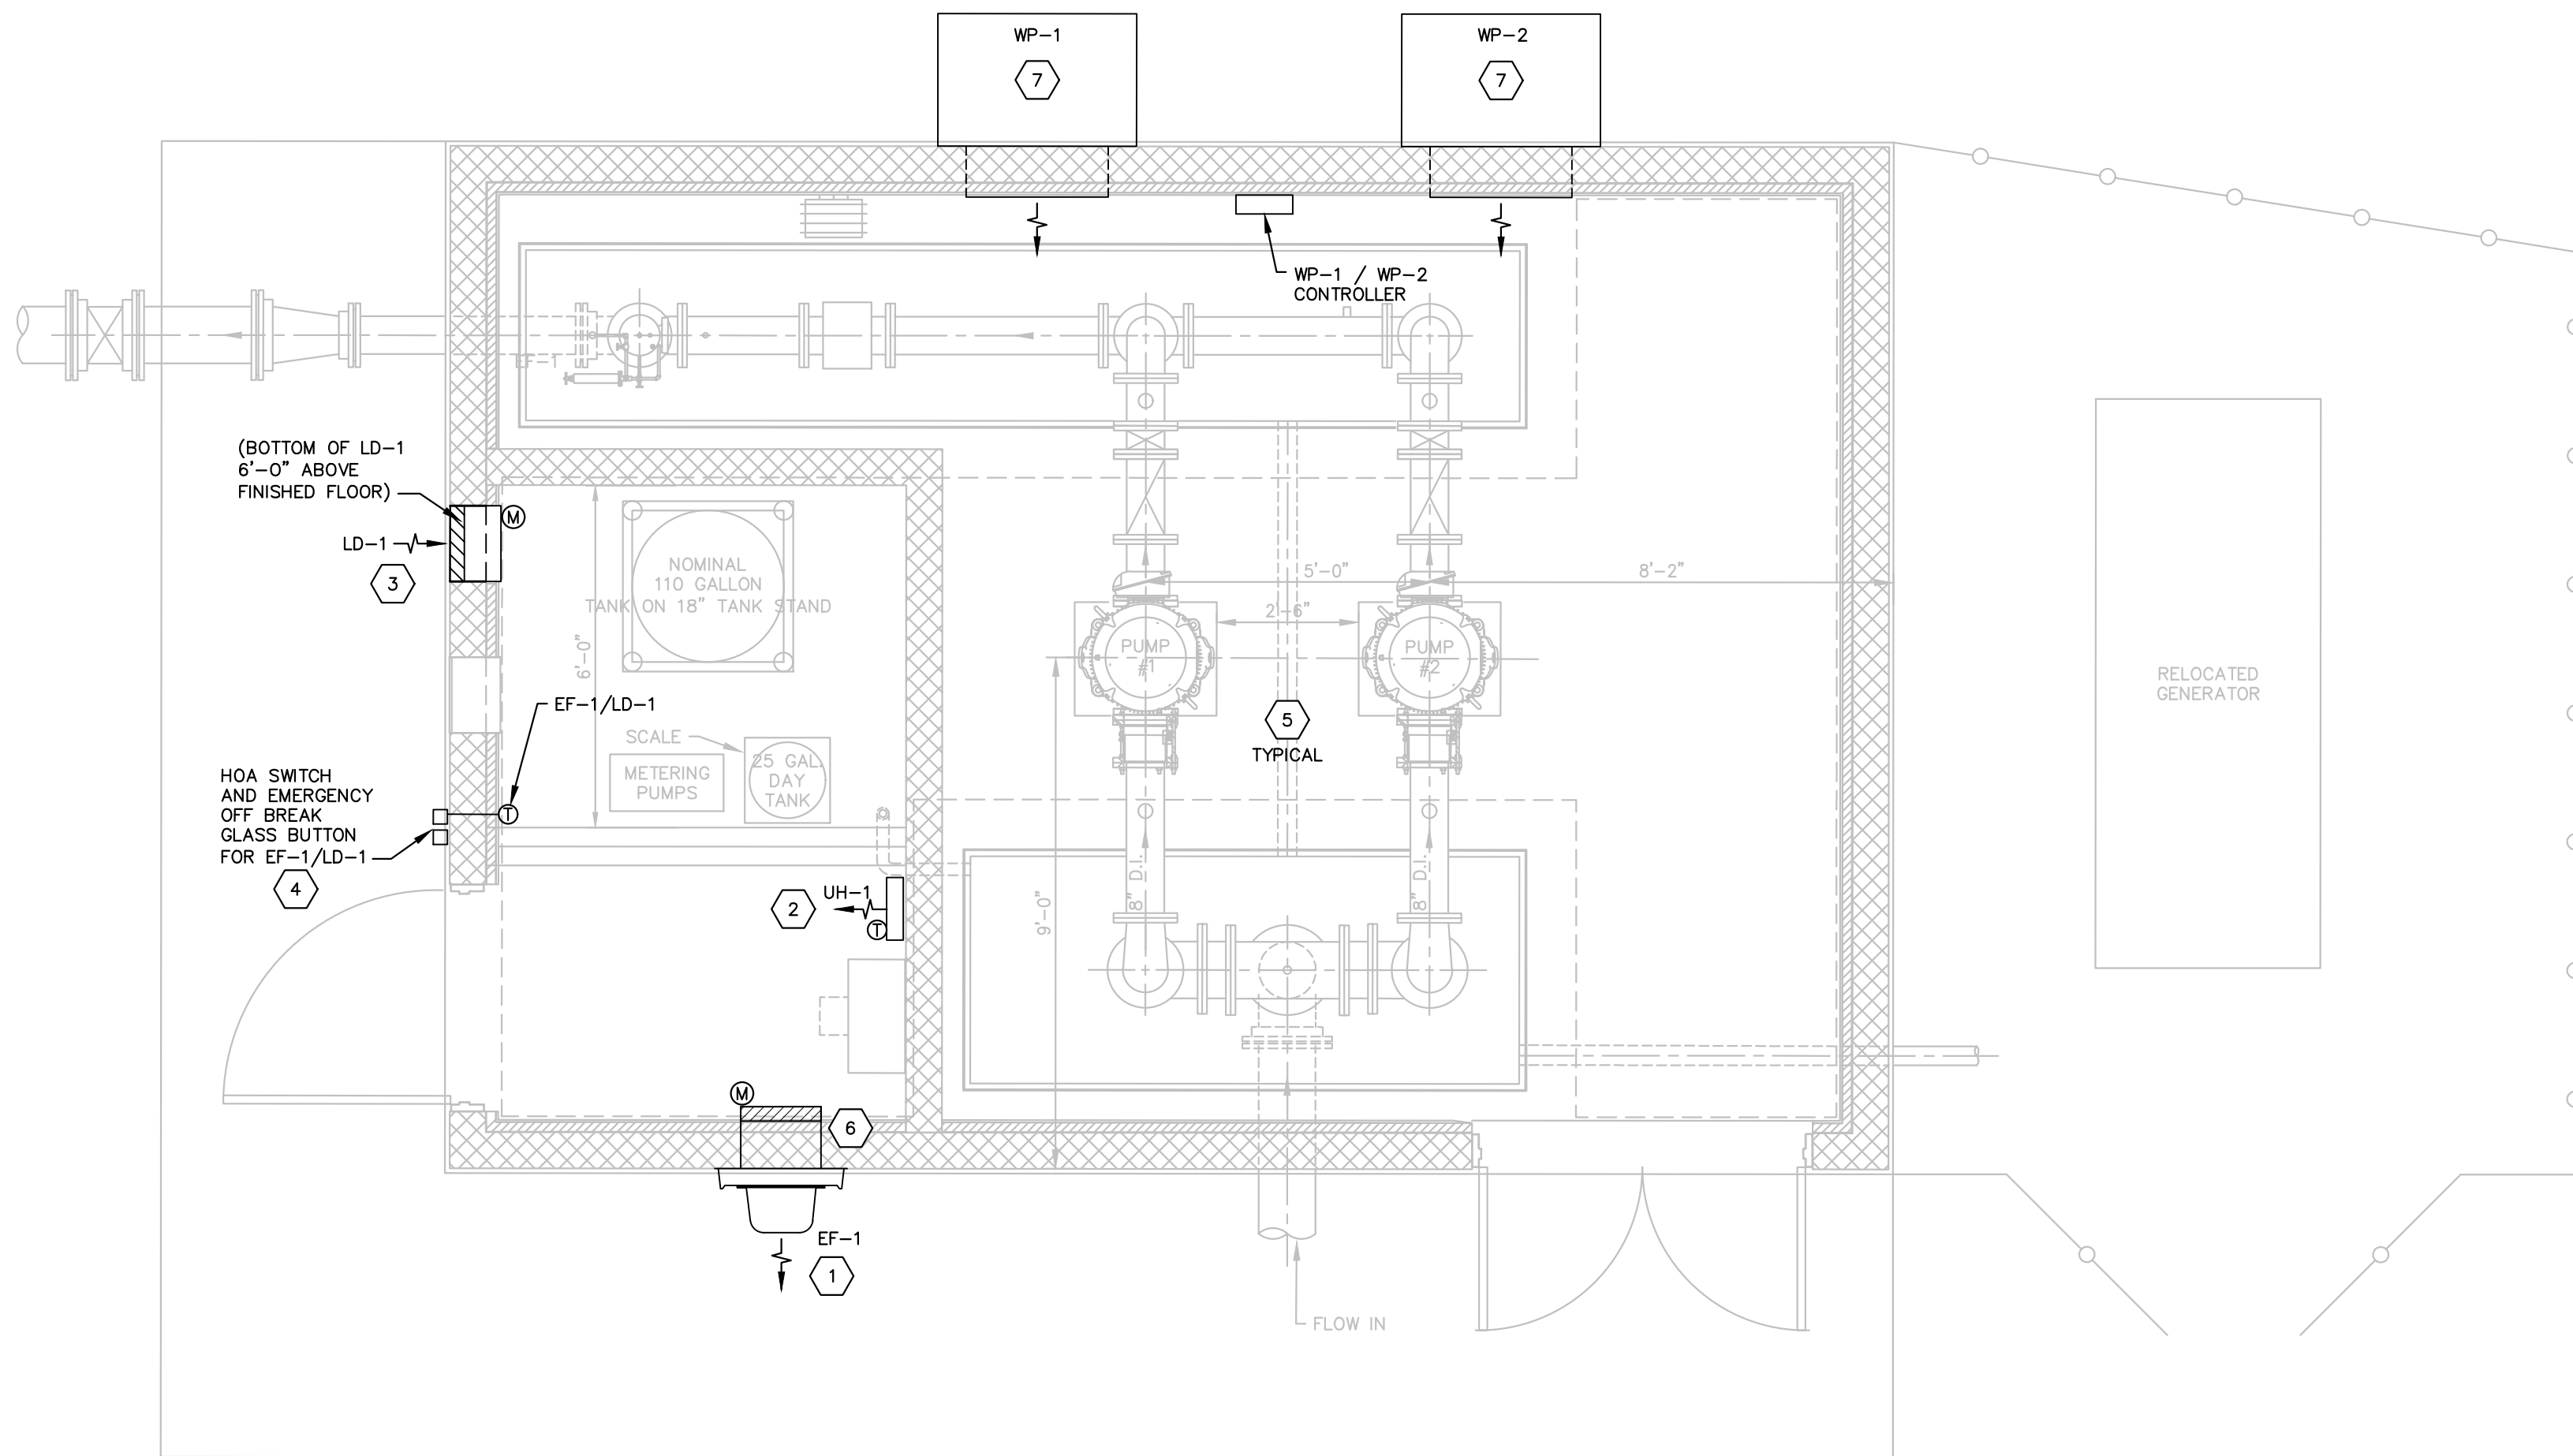


BOOSTER PUMP STATION
HVAC PLAN

3/8" = 1'-0"

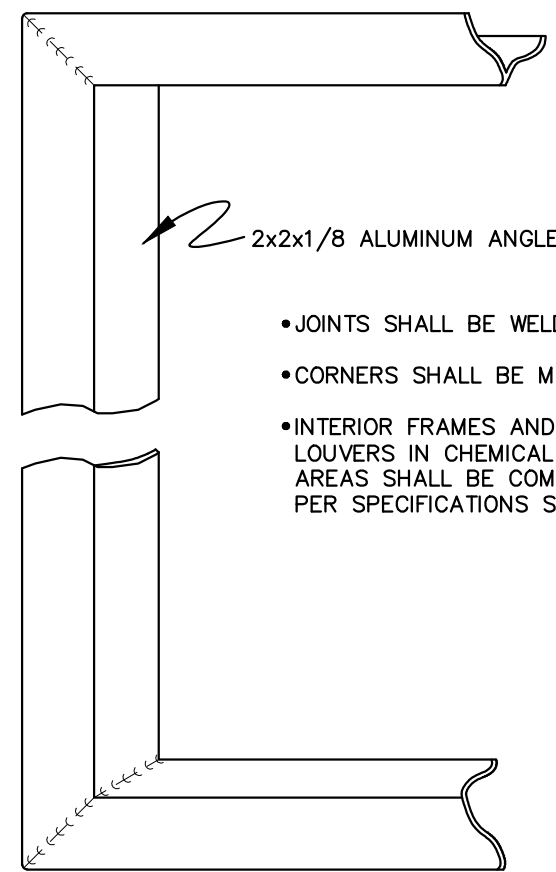

INTERIOR PERIMETER FRAME
FOR WALL LOUVERS

NOT TO SCALE

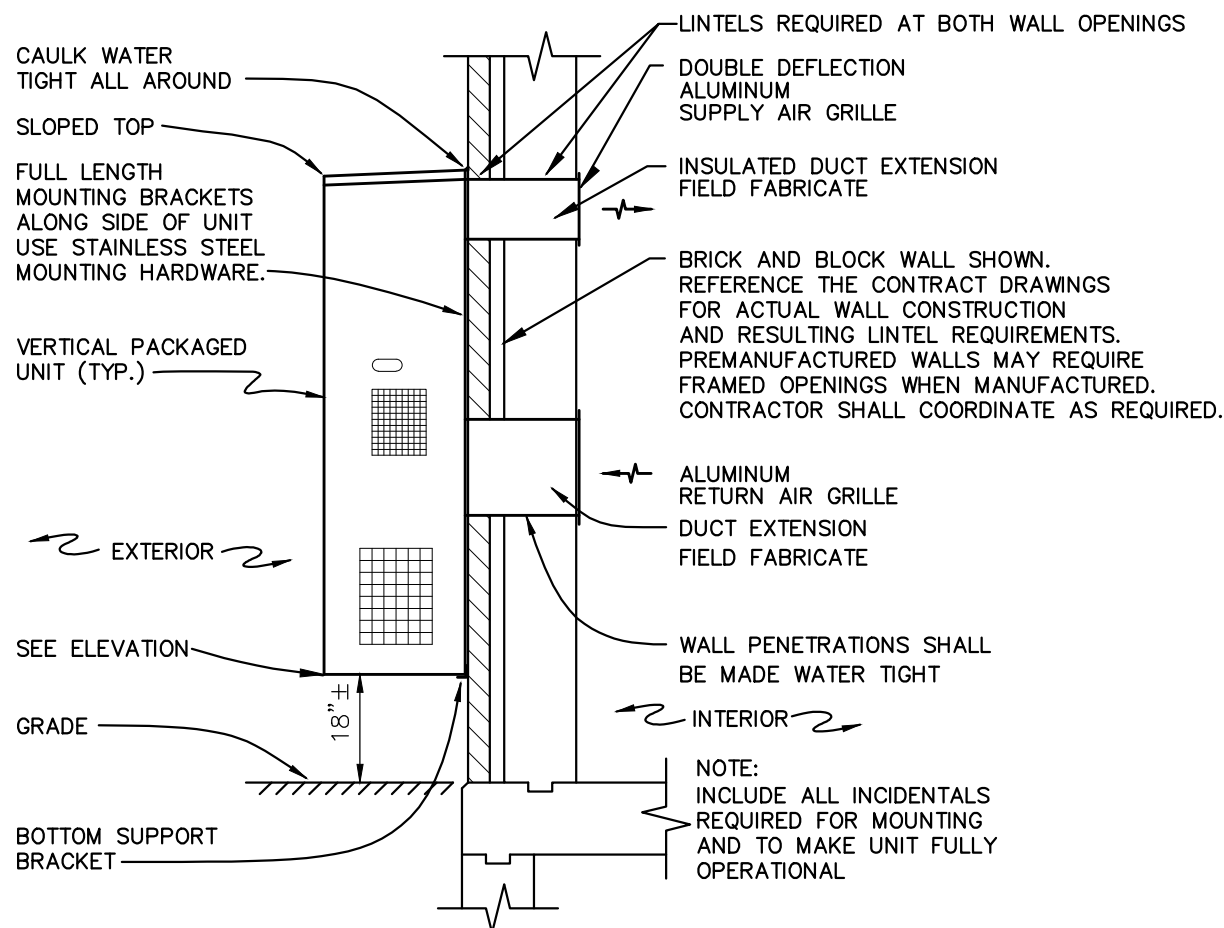

VERTICAL PACKAGED UNIT
DETAIL

NOT TO SCALE

HVAC NOTES:

1. EXHAUST FAN EF-1, FULL WALL SLEEVE, MOTORIZED BACKDRAFT DAMPER REQUIRED, POWER OPEN, SPRING CLOSE. TRIM ALL AROUND INTERIOR OF ROUGH CUT OPENING. TWIN CITY FIBER AIR (SWARTWOUT) MODEL 12SA2, 531 CFM AT 3/8" SP, 1/8 HP, 1140 RPM, 120V/1P FAN. DAMPER JUST INSIDE ROOM IN WALL SLEEVE EXTENSION.
2. UNIT HEATER UH-1 SHALL HAVE INTEGRAL THERMOSTAT (50 TO 90F) AND CONTACTORS. MARKEL MODEL 3420. IT SHALL BE 4,000 WATT (240V / 1 PHASE).
3. COMBINATION LOUVER/DAMPER LD-1 SHALL HAVE FULL WALL SLEEVE AND INTERIOR PERIMETER FRAME AROUND ROUGH OPENING. RUSKIN MODEL ELC6375DAX, 16" WIDE X 24" HIGH, 531 CFM AT 0.05 SP, 6" DEEP ALUMINUM FRAME, RECESSED WITH EXTENDED SILL, INSECT SCREEN, 0.9 SF FREE AREA, 593 FPM VELOCITY. KYNAR COLOR SELECTION DURING SHOP DRAWING REVIEW.
4. CONTROLS FOR EF-1/LD-1: INTERIOR CHROMOLOX WCR7 THERMOSTAT (COOLING), HOA SWITCH AND ALLEN BRADLEY BREAK GLASS EMERGENCY OFF SWITCH ON OUTSIDE WALL, BOTH TO BE WATER PROOF OR HAVE WATERPROOF COVERS.
5. SEE ELECTRICAL DRAWINGS FOR FINAL REQUIRED VOLTAGE/PHASE OF UH-1, EF-1, LD-1, AND MOTORIZED BACKDRAFT DAMPERS AT EF-1 AND LD-1.
6. FULL WALL SLEEVE WITH DAMPER EXTENSION INTO ROOM AND A POWER OPEN SPRING RETURN DAMPER MOTOR. BOTTOM OF EF-1 WALL OPENING AT 2 FT AFF.
7. COORDINATE WITH PRIME CONTRACTOR TO ENSURE THAT SMOOTH FACE BLOCK IS INSTALLED WHERE THE WP UNIT(S) WILL BE MOUNTED ON THE EXTERIOR WALL. VERIFY SIZE AND LOCATION OF MOUNTING AREA FOR SMOOTH FACE BLOCK USING APPROVED SHOP DRAWING. NO SMOOTH FACE BLOCK SHALL BE VISIBLE AFTER THE WP UNIT(S) HAS BEEN INSTALLED.

WALL MOUNTED AC UNIT

TAG	LOCATION OR AREA SERVED	MANUFACTURER	MODEL (INDOOR / OUTDOOR)	CFM	EXTERNAL STAT. PRESS (INCHES)	COOLING TOTAL/SENSIBLE (MBH)	HEAT PUMP HEATING (MBH)	SUPP. ELEC. HEAT (KW)	SEER / EER	VOLT / PHASE	REMARKS	WEIGHT (LBS)
WP - 1	BOOSTER PUMP STATION	MARVAIR	MAA 2060 AD (2 STAGE)	1,800	0.25	54 / 36.5	0.0	6.0	NA / 11	480 / 3	1, 2, 3, 4, 5	545
WP - 2	BOOSTER PUMP STATION	MARVAIR	MAA 2060 AD (2 STAGE)	1,800	0.25	54 / 36.5	0.0	6.0	NA / 11	480 / 3	1, 2, 3, 4, 5	545

GENERAL COMMENTS: See remarks below. UNITS REQUIRE 2 STAGE COMPRESSORS, LOW AMBIENT CONTROL, AND FULL FLOW ENTHALPY CONTROLLED ECONOMIZER.

SEE SPECIFICATIONS FOR ADDITIONAL REQUIREMENTS. ALTERNATE MANUFACTURERS WILL BE CONSIDERED. PROOF OF EQUALITY IS THE CONTRACTOR'S RESPONSIBILITY.
INSTALL ENGRAVED EQUIPMENT TAGS (BLACK TEXT ON WHITE BACKGROUND) ON ALL MAJOR EQUIPMENT AND ASSOCIATED CONTROLS.
COOLING PERFORMANCE DESIGN CONDITIONS: 95F OUTDOOR, 80F DB / 67F WB INDOOR. HEAT PUMP HEATING PERFORMANCE DESIGN CONDITIONS: 17F OUTDOOR, 70F DB INDOOR.
VERIFY WEIGHTS AND DIMENSIONS WITH EQUIPMENT FROM FINAL ACCEPTED SHOP DRAWINGS. PROVIDE STRUCTURAL SUPPORT AND FRAMING FOR WALL MOUNTED EQUIPMENT AS REQUIRED.
FOR EACH UNIT NOTED ABOVE, A FULL FLOW ECONOMIZER WITH ENTHALPY CONTROL, DAMPER CONTROLLED AIR MIXING, AND INTERNAL PRESSURE RELIEF IS REQUIRED.
FOR INSTALLATION INTO NEW BLOCK WALLS WITH BOND BEAMS, IF WALL REINFORCEMENT IS INTERRUPTED, OFFSET IT ABOVE OR BELOW THE WALL OPENING TO ENSURE IT REMAINS CONTINUOUS.
FOR INSTALLATION ONTO SPLIT FACE BLOCK WALLS, INSTALL SMOOTH FACE BLOCK WHERE UNIT AND MOUNTING FLANGES WILL BE TO MAKE A SECURE AND GAP FREE CONNECTION. SMOOTH FACE BLOCK FOR MOUNTING SHALL NOT EXTEND GREATER THAN 2 INCHES BEYOND THE MOUNTING PERIMETER OF THE UNIT.

REMARKS:


1. VERTICAL PACKAGED WALL MOUNT UNIT WITH: LOW AMBIENT PACKAGE (FOR OPERATION DOWN TO 20 DEGREES F.), DELUXE ALUMINUM SUPPLY AND RETURN GRILLES, 4 FACTORY FILTERS, BLANK OFF PLATE TO RESTRICT OUTSIDE AIR UNLESS ECONOMIZER IS NOTED, TIME DELAY, THERMAL EXPANSION VALVE, ANTI SHORT CYCLE TIMER, HIGH PRESSURE SWITCH, LOSS OF CHARGE, UTILIZE R-410a REFRIGERANT, LOCKOUT RELAY, TIMED LOW PRESSURE BYPASS, WALL SLEEVE, FACTORY INSTALLED DISCONNECT, COLOR SELECTION DURING SHOP DWG. REVIEW, SCROLL COMPRESSOR, SINGLE POINT POWER ENTRY, SLOPED TOP, STAINLESS MOUNTING HARDWARE. CHECKLIST, TEST, AND STARTUP WITH A WRITTEN REPORT TO ENGINEER SHALL BE PERFORMED BY A TECHNICIAN FROM THE MANUFACTURER'S REPRESENTATIVE AND SHALL BE INCLUDED IN THE BID PRICE.
2. UNIT SHALL HAVE A DIRTY FILTER INDICATOR, STAINLESS STEEL FASTNERS & DRAIN PAN, THERMAL EXPANSION VALVE, LOW AMBIENT CONTROL WITH FAN CYCLE CONTROL AND EVAP FREEZE SENSOR
3. VERTICAL PACKAGED WALL MOUNTED UNIT SHALL HAVE BUILT-IN FACTORY INSTALLED ECONOMIZER WITH USER ADJUSTABLE ENTHALPY CONTROLLER, INTEGRAL PRESSURE RELIEF, AND MIXED AIR SENSOR TO MODULATE DAMPER FOR CORRECT MIX OF RETURN AND OUTDOOR AIR TO MAINTAIN A 50 TO 63 DEGREE F SUPPLY.
4. VERTICAL PACKAGED WALL MOUNTED UNIT SHALL HAVE 2 STAGESCROLL COMPRESSOR WITH FIRST STAGE COOLING APPROXIMATELY 65% OF THE TOTAL COOLING CAPACITY.
5. THE MANUFACTURER'S COMMSTAT 4 TELECOM HVAC CONTROLLER CAPABLE OF CONTROLLING UP TO 2 UNITS, EACH WITH A 2 STAGE COMPRESSOR AND FULL FLOW ECONOMIZER IS REQUIRED INCLUDING FURNISHING AND INSTALLING CONDUIT AND WIRE FOR REMOTE SENSORS.

11 / 13 / 2024

DESIGNER	JDP	DATE	BY	REVISION
DRAWN	TEW			
CHECKED	JDP			
APPROVED	JDP			

GRAPHIC SCALE
SCALE: AS NOTED

ALL RIGHTS RESERVED
THIS DOCUMENT IS THE PROPERTY OF BELL ENGINEERING AND SHALL NOT BE REPRODUCED IN WHOLE OR IN PART OR USED FOR CONSTRUCTION OF OTHER THAN THIS SPECIFIC PROJECT WITHOUT THE WRITTEN PERMISSION OF BELL ENGINEERING.
FACSIMILES OF LICENSED PROFESSIONAL ENGINEER AND/OR LAND SURVEYOR SEALS, IF AFFIXED TO THIS DOCUMENT, SHALL BE CONSIDERED LEGITIMATE ONLY IF SIGNED AND DATED BY THE REGISTRANT.

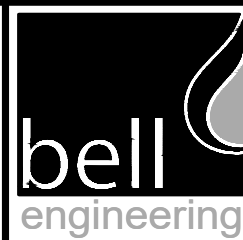

Lexington, KY (859) 278-5412
Hopkinsville, KY (270) 886-5466
Somerset, KY (606) 485-4011

WATER SYSTEM IMPROVEMENTS
SHOPES CREEK ROAD AREA
CANNONBURG WATER DISTRICT
CANNONBURG, KENTUCKY


BOOSTER PUMP STATION
HVAC PLAN

DIVISION	-
CONTRACT NO.	691-21-01
DATE	SEPTEMBER 2021
SHEET NO.	M1 OF M1




ABBREVIATION OR ACRONYM	DESCRIPTION	ABBREVIATION OR ACRONYM	DESCRIPTION	SYMBOL	DESCRIPTION	SYMBOL	DESCRIPTION	SYMBOL	DESCRIPTION
A	AMPERE	PS	PRESSURE SWITCH		THERMOSTAT		REMOTE LOCATION FROM STARTER		FUSED CUTOUT
AF	AMPERE FRAME	PVC	POLY-VINYL CHLORIDE		MOTOR DISCONNECT SWITCH (NONFUSED SAFETY SWITCH) UNLESS OTHERWISE NOTED		ELAPSED TIME METER		SECTIONALIZING SWITCH (3 PHASE)
AFF	ABOVE FINISHED FLOOR OR DECK TO CENTERLINE	PWR	POWER		MOTOR (A NUMBER SUBSTITUTED FOR THE LETTER M IN THE CIRCLE IS THE NAMEPLATE HP)		MOTOR STARTER COIL		NEW OVERHEAD WIRING (NUMBER OF HASH MARKS INDICATES NUMBER OF PHASES - 3 PHASE SHOWN)
AFC	AUTOMATIC FREQUENCY CONTROL (ALSO SEE VFD)	P/W	PLYWOOD		EXPLOSION PROOF JUNCTION BOX		AUTO TRANSFORMER		EXISTING OVERHEAD WIRING (3 PHASE SHOWN)
AHU	AIR HANDLING UNIT	RECEPT	RECEPTACLE		JUNCTION BOX - SMALL		TIMER CLUTCH (OR SOLENOID)		EXISTING UNDERGROUND CONDUIT
AT	AMPERE TRIP	R/C	REMOTE CONTROL		JUNCTION BOX - SQUARE\RECTANGULAR - LARGE		IN CONTROL CIRCUITS INFERS MECHANICAL INTERLOCKING IN SITE PLANS AND BUILDING PLANS MAY INFER UNDERGROUND OR CONCEALED CONDUITS, HIDDEN LINES, ETC.		NEW UNDERGROUND CONDUIT
ATS	AUTOMATIC TRANSFER SWITCH	RV	RELIEF VENT		MAGNETIC COMBINATION STARTER		KEY INTERLOCK		MANHOLE OR PULLBOX
AWG	AMERICAN WIRE GAUGE	SHT	SHEET		CCTV CAMERA OUTLET		CIRCUIT BREAKER; THERMAL MAGNETIC TYPE, SINGLE POLE		KEYNOTE
ATRV	AUTOTRANSFORMER REDUCED-VOLTAGE	SIG	SIGNAL		CABLE TV OR ANTENNA CABLE OUTLET		CIRCUIT BREAKER; THERMAL MAGNETIC TYPE, 2 POLE		CALL SWITCH
BC	BARE COPPER	SMR	SURFACE-METAL-RACEWAY		CCTV MONITOR OUTLET		CIRCUIT BREAKER; THERMAL MAGNETIC TYPE, 3 POLE		WALL MOUNTED SPEAKER OR ALARM HORN
C	CONDUIT (RACEWAY)	S/N	SOLID NEUTRAL		TELEPHONE OUTLET FLOORBOX MOUNTED		CIRCUIT BREAKER; MAGNETIC TYPE, SINGLE POLE		PASSIVE INFRARED MOTION DETECTOR, ARROW DENOTES CURTAIN DIRECTION
⊙	AT	SP	SINGLE POLE		TELEPHONE OUTLET		CIRCUIT BREAKER (GENERAL), 2 POLE		MAGNETIC CONTACT, DOOR MOUNTED
CB	CIRCUIT BREAKER	SS	STAINLESS STEEL		COMPUTER DATA OUTLET		CIRCUIT BREAKER (GENERAL), 3 POLE OR MOLDED CASE SWITCH		MAGNETIC CONTACT, WINDOW MOUNTED
CCTV	CLOSED CIRCUIT TELEVISION	SVCS	SERVICE(S)		DATA OUTLET, FLOORBOX MOUNTED		GROUND FAULT PROTECTED CIRCUIT BREAKER, 3 POLE		END-OF-LINE RESISTOR
CKT	CIRCUIT	STA	STATION		GENERATOR/PHASE CONVERTER		GROUND FAULT PROTECTED CIRCUIT BREAKER, ONE LINE DIAGRAM REPRESENTATION		HEAT DETECTOR, GENERAL (SUBSCRIPT INDICATES RATE OF RISE OR FIXED TEMPERATURE)
C/L	CENTERLINE	STD	STANDARD		EXHAUST FAN/VENTILATOR		GROUND FAULT PROTECTED CIRCUIT BREAKER, ONE LINE DIAGRAM REPRESENTATION		SMOKE DETECTOR GENERAL (SUBSCRIPT INDICATES PHOTOELECTRIC OR IONIZATION)
CLG	CEILING	SW	SWITCH		COMBINATION POWER/TELEPHONE FLOORBOX		GROUND FAULT PROTECTED CIRCUIT BREAKER, ONE LINE DIAGRAM REPRESENTATION		FIRE ALARM MANUAL PULL STATION
CTL	CONTROL	TEL	TELEPHONE		CONDUIT SLEEVED THROUGH WALL		GROUND FAULT PROTECTED CIRCUIT BREAKER, ONE LINE DIAGRAM REPRESENTATION		FIRE ALARM HORN/SPEAKER WITH BUILT-IN STROBE
CU	COPPER OR IN HVAC CONTEXT 'CONDENSING UNIT'	TM	THERMAL MAGNETIC		CONDUIT TURNED UP		GROUND FAULT PROTECTED CIRCUIT BREAKER, ONE LINE DIAGRAM REPRESENTATION		SPRINKLER SYSTEM FLOW SWITCH
Δ/Y	DELTA/WYE	TS	TAMPER SWITCH		CONDUIT TURNED DOWN		GROUND FAULT PROTECTED CIRCUIT BREAKER, ONE LINE DIAGRAM REPRESENTATION		TAMPER SWITCH
DACT	DIGITAL ALARM COMMUNICATOR TRANSMITTER	TV	TELEVISION		CURRENT TRANSFORMER		GROUND FAULT PROTECTED CIRCUIT BREAKER, ONE LINE DIAGRAM REPRESENTATION		RELAY IN FIRE ALARM SCHEMATICS
DB	DIRECT BURIAL	TVSS	TRANSIENT VOLTAGE SURGE SUPPRESSOR		POTENTIAL TRANSFORMER		GROUND FAULT PROTECTED CIRCUIT BREAKER, ONE LINE DIAGRAM REPRESENTATION		MAGNETIC DOOR HOLDER
DN	DOWN	UG	UNDERGROUND		SPEAKER GENERAL		GROUND FAULT PROTECTED CIRCUIT BREAKER, ONE LINE DIAGRAM REPRESENTATION		DUCT SMOKE DETECTOR
DP\ST	DOUBLE POLE-SINGLE THROW	UH	UNIT HEATER		CLOCK, SINGLE FACE		GROUND FAULT PROTECTED CIRCUIT BREAKER, ONE LINE DIAGRAM REPRESENTATION		FIREMANS TELEPHONE STATION
EC	EMPTY CONDUIT	UV	UNIT VENTILATOR		CLOCK, DOUBLE FACE		GROUND FAULT PROTECTED CIRCUIT BREAKER, ONE LINE DIAGRAM REPRESENTATION		MUSHROOM HEAD EMERGENCY SWITCH
EF	EXHAUST FAN	V	VOLTAGE OR VOLTS		FLUORESCENT LTG. FIXTURE - CONTINUOUS ROW		GROUND FAULT PROTECTED CIRCUIT BREAKER, ONE LINE DIAGRAM REPRESENTATION		PRESSURE DETECTOR IN FIRE ALARM SCHEMATICS
EG	EQUIPMENT GROUND	VFD	VARIABLE FREQUENCY DRIVE		LIGHTNING ARRESTOR		GROUND FAULT PROTECTED CIRCUIT BREAKER, ONE LINE DIAGRAM REPRESENTATION		LEVEL DETECTOR IN FIRE ALARM SCHEMATICS
EJ	EXPANSION JOINT	W	WIRE		CAPACITOR		GROUND FAULT PROTECTED CIRCUIT BREAKER, ONE LINE DIAGRAM REPRESENTATION		BELL FOR FIRE ALARM SYSTEM
EL	ELEVATION	WP	WEATHERPROOF		GROUND		GROUND FAULT PROTECTED CIRCUIT BREAKER, ONE LINE DIAGRAM REPRESENTATION		FIRE EXTINGUISHER, DRY CHEMICAL ABC RATED
ELEC	ELECTRIC	W/	WITH		MULTI-OUTLET STRIP (PLUGMOLD)		GROUND FAULT PROTECTED CIRCUIT BREAKER, ONE LINE DIAGRAM REPRESENTATION		FIRE EXTINGUISHER, HALON TYPE
EOL	END-OF-LINE	XFMR	TRANSFORMER		TRANSFORMER		GROUND FAULT PROTECTED CIRCUIT BREAKER, ONE LINE DIAGRAM REPRESENTATION		GAS DETECTOR
EMERG	EMERGENCY				LIGHTING PANELBOARD (IN ONE-LINE OR RISER DIAGRAMS)		GROUND FAULT PROTECTED CIRCUIT BREAKER, ONE LINE DIAGRAM REPRESENTATION		FLAME DETECTOR
EM#	EMERGENCY LIGHT				CIRCUIT BREAKER (GENERAL), SINGLE POLE, OR A REPRESENTATION OF A 2 OR 3 POLE BREAKER ON THE ONE LINE DIAGRAM.		GROUND FAULT PROTECTED CIRCUIT BREAKER, ONE LINE DIAGRAM REPRESENTATION		
ES	EMERGENCY SOLENOID				RELAY CONTACTS (NORMALLY CLOSED)		GROUND FAULT PROTECTED CIRCUIT BREAKER, ONE LINE DIAGRAM REPRESENTATION		
EUH	ELECTRIC UNIT HEATER				THERMAL OVERLOAD PROTECTION		GROUND FAULT PROTECTED CIRCUIT BREAKER, ONE LINE DIAGRAM REPRESENTATION		
EW	ELECTRIC WATER COOLER				MOTOR (IN CONTROL CIRCUIT DRAWINGS)		GROUND FAULT PROTECTED CIRCUIT BREAKER, ONE LINE DIAGRAM REPRESENTATION		
EW	ELECTRIC WALL HEATER OR WATER HEATER				FUSE		GROUND FAULT PROTECTED CIRCUIT BREAKER, ONE LINE DIAGRAM REPRESENTATION		
EX	EXISTING				DISCONNECT SWITCH		GROUND FAULT PROTECTED CIRCUIT BREAKER, ONE LINE DIAGRAM REPRESENTATION		
FA	FIRE ALARM				FUSED DISCONNECT SWITCH		GROUND FAULT PROTECTED CIRCUIT BREAKER, ONE LINE DIAGRAM REPRESENTATION		
FACP	FIRE ALARM CONTROL PANEL				AUTOMATIC TRANSFER SWITCH		GROUND FAULT PROTECTED CIRCUIT BREAKER, ONE LINE DIAGRAM REPRESENTATION		
FCU	FAN COIL UNIT				FLOAT SWITCH		GROUND FAULT PROTECTED CIRCUIT BREAKER, ONE LINE DIAGRAM REPRESENTATION		
FIXT	FIXTURE				TEMPERATURE SWITCH (THERMOSTAT)		GROUND FAULT PROTECTED CIRCUIT BREAKER, ONE LINE DIAGRAM REPRESENTATION		
FTG	FITTING				DOT INDICATES A CONNECTION OF TWO WIRES		GROUND FAULT PROTECTED CIRCUIT BREAKER, ONE LINE DIAGRAM REPRESENTATION		
FOR	'FORWARD-OFF-REVERSE' SELECTOR SWITCH				WALL MOUNTED, GENERIC LIGHT FIXTURE		GROUND FAULT PROTECTED CIRCUIT BREAKER, ONE LINE DIAGRAM REPRESENTATION		
FS	FLOAT SWITCH				2 LAMP FLUORESCENT FIXTURE		GROUND FAULT PROTECTED CIRCUIT BREAKER, ONE LINE DIAGRAM REPRESENTATION		
FSS	FUSED SAFETY SWITCH				2,3,OR 4 LAMP FLUORESCENT LIGHT FIXTURE		GROUND FAULT PROTECTED CIRCUIT BREAKER, ONE LINE DIAGRAM REPRESENTATION		
FVNR	FULL VOLTAGE, NON-REVERSING				FLUORESCENT FIXTURE WITH BUILT-IN EMERGENCY BACKUP		GROUND FAULT PROTECTED CIRCUIT BREAKER, ONE LINE DIAGRAM REPRESENTATION		
GEN	GENERATOR				EXTERIOR LIGHT FIXTURE (WALL PACK)		GROUND FAULT PROTECTED CIRCUIT BREAKER, ONE LINE DIAGRAM REPRESENTATION		
GFCI	GROUND FAULT CURRENT INTERRUPTING				EMERGENCY LIGHT (ADJUSTABLE, DOUBLE-HEAD SHOWN)		GROUND FAULT PROTECTED CIRCUIT BREAKER, ONE LINE DIAGRAM REPRESENTATION		
GND	GROUND				ILLUMINATED EXIT SIGN (UNIT WITH DIRECTIONAL ARROW SHOWN)		GROUND FAULT PROTECTED CIRCUIT BREAKER, ONE LINE DIAGRAM REPRESENTATION		
GNDG	GROUNDING				PANELBOARD (SURFACE MOUNTED)		GROUND FAULT PROTECTED CIRCUIT BREAKER, ONE LINE DIAGRAM REPRESENTATION		
HOA	'HAND-OFF-AUTOMATIC' SELECTOR SWITCH				PANELBOARD (FLUSH MOUNTED IN WALL)		GROUND FAULT PROTECTED CIRCUIT BREAKER, ONE LINE DIAGRAM REPRESENTATION		
HP	HORSEPOWER				HEATER-WALL MOUNTED		GROUND FAULT PROTECTED CIRCUIT BREAKER, ONE LINE DIAGRAM REPRESENTATION		
HPU	HEAT PUMP UNIT						GROUND FAULT PROTECTED CIRCUIT BREAKER, ONE LINE DIAGRAM REPRESENTATION		
HTC	HIGH TEMPERATURE CUTOFF						GROUND FAULT PROTECTED CIRCUIT BREAKER, ONE LINE DIAGRAM REPRESENTATION		
JB	JUNCTION BOX						GROUND FAULT PROTECTED CIRCUIT BREAKER, ONE LINE DIAGRAM REPRESENTATION		
KVA	KILOVOLT-AMPERES						GROUND FAULT PROTECTED CIRCUIT BREAKER, ONE LINE DIAGRAM REPRESENTATION		
KWH	KILOWATT-HOUR						GROUND FAULT PROTECTED CIRCUIT BREAKER, ONE LINE DIAGRAM REPRESENTATION		
KCML	THOUSAND CIRCULAR MILS						GROUND FAULT PROTECTED CIRCUIT BREAKER, ONE LINE DIAGRAM REPRESENTATION		
LF	LIGHTING FIXTURE (LUMINAIRE)						GROUND FAULT PROTECTED CIRCUIT BREAKER, ONE LINE DIAGRAM REPRESENTATION		
LOR	'LOCAL-OFF-REMOTE' SELECTOR SWITCH						GROUND FAULT PROTECTED CIRCUIT BREAKER, ONE LINE DIAGRAM REPRESENTATION		
LTG	LIGHTING						GROUND FAULT PROTECTED CIRCUIT BREAKER, ONE LINE DIAGRAM REPRESENTATION		
LTS	LIGHTS						GROUND FAULT PROTECTED CIRCUIT BREAKER, ONE LINE DIAGRAM REPRESENTATION		
LS	LIMIT SWITCH						GROUND FAULT PROTECTED CIRCUIT BREAKER, ONE LINE DIAGRAM REPRESENTATION		
LV	LOW VOLTAGE						GROUND FAULT PROTECTED CIRCUIT BREAKER, ONE LINE DIAGRAM REPRESENTATION		
LVDT	LINEAR VARIABLE DIFFERENTIAL TRANSFORMER						GROUND FAULT PROTECTED CIRCUIT BREAKER, ONE LINE DIAGRAM REPRESENTATION		
MATV	MASTER ANTENNA TELEVISION						GROUND FAULT PROTECTED CIRCUIT BREAKER, ONE LINE DIAGRAM REPRESENTATION		
MAU	MAKE UP AIR UNIT						GROUND FAULT PROTECTED CIRCUIT BREAKER, ONE LINE DIAGRAM REPRESENTATION		
M/C	MAGNETIC CONTRACTOR CONTROL						GROUND FAULT PROTECTED CIRCUIT BREAKER, ONE LINE DIAGRAM REPRESENTATION		
MCB	MAIN CIRCUIT BREAKER						GROUND FAULT PROTECTED CIRCUIT BREAKER, ONE LINE DIAGRAM REPRESENTATION		
MCP	MOTOR CIRCUIT PROTECTOR						GROUND FAULT PROTECTED CIRCUIT BREAKER, ONE LINE DIAGRAM REPRESENTATION		
MCC	MOTOR CONTROL CENTER						GROUND FAULT PROTECTED CIRCUIT BREAKER, ONE LINE DIAGRAM REPRESENTATION		
MDP	MAIN DISTRIBUTION PANEL						GROUND FAULT PROTECTED CIRCUIT BREAKER, ONE LINE DIAGRAM REPRESENTATION		
MFR	MANUFACTURER						GROUND FAULT PROTECTED CIRCUIT BREAKER, ONE LINE DIAGRAM REPRESENTATION		
MH	MANHOLE						GROUND FAULT PROTECTED CIRCUIT BREAKER, ONE LINE DIAGRAM REPRESENTATION		
MIN	MINIMUM						GROUND FAULT PROTECTED CIRCUIT BREAKER, ONE LINE DIAGRAM REPRESENTATION		
MLO	'MAIN LUGS ONLY'						GROUND FAULT PROTECTED CIRCUIT BREAKER, ONE LINE DIAGRAM REPRESENTATION		
MTG HGT	MOUNTING HEIGHT						GROUND FAULT PROTECTED CIRCUIT BREAKER, ONE LINE DIAGRAM REPRESENTATION		
MTD	MOUNTED						GROUND FAULT PROTECTED CIRCUIT BREAKER, ONE LINE DIAGRAM REPRESENTATION		
MV	MEDIUM VOLTAGE						GROUND FAULT PROTECTED CIRCUIT BREAKER, ONE LINE DIAGRAM REPRESENTATION		
NA	NOT APPLICABLE						GROUND FAULT PROTECTED CIRCUIT BREAKER, ONE LINE DIAGRAM REPRESENTATION		
NC	NORMALLY CLOSED						GROUND FAULT PROTECTED CIRCUIT BREAKER, ONE LINE DIAGRAM REPRESENTATION		
NEC	NATIONAL ELECTRICAL CODE						GROUND FAULT PROTECTED CIRCUIT BREAKER, ONE LINE DIAGRAM REPRESENTATION		
NFSS	NON-FUSIBLE SAFETY SWITCH						GROUND FAULT PROTECTED CIRCUIT BREAKER, ONE LINE DIAGRAM REPRESENTATION		
NL	NON LINEAR						GROUND FAULT PROTECTED CIRCUIT BREAKER, ONE LINE DIAGRAM REPRESENTATION		
NO	NORMALLY OPEN						GROUND FAULT PROTECTED CIRCUIT BREAKER, ONE LINE DIAGRAM REPRESENTATION		
NS	NORMAL SOLENOID						GROUND FAULT PROTECTED CIRCUIT BREAKER, ONE LINE DIAGRAM REPRESENTATION		
NTS	'NOT TO SCALE'						GROUND FAULT PROTECTED CIRCUIT BREAKER, ONE LINE DIAGRAM REPRESENTATION		
OH	OVERHEAD						GROUND FAULT PROTECTED CIRCUIT BREAKER, ONE LINE DIAGRAM REPRESENTATION		
OL	OVERLOAD						GROUND FAULT PROTECTED CIRCUIT BREAKER, ONE LINE DIAGRAM REPRESENTATION		
P	POLE						GROUND FAULT PROTECTED CIRCUIT BREAKER, ONE LINE DIAGRAM REPRESENTATION		
PMT	PAD MOUNTED TRANSFORMER						GROUND FAULT PROTECTED CIRCUIT BREAKER, ONE LINE DIAGRAM REPRESENTATION		
OT	OVER TEMPERATURE						GROUND FAULT PROTECTED CIRCUIT BREAKER, ONE LINE DIAGRAM REPRESENTATION		
PH OR ⌀	PHASE						GROUND FAULT PROTECTED CIRCUIT BREAKER, ONE LINE DIAGRAM REPRESENTATION		
PNL	PANEL						GROUND FAULT PROTECTED CIRCUIT BREAKER, ONE LINE DIAGRAM REPRESENTATION		

- THIS LIST OF ABBREVIATIONS, ACRONYMS, AND SYMBOLS IS A STANDARD LIST. NOT ALL SYMBOLS ARE USED ON THIS PROJECT.
- SYMBOLS USED BUT NOT LISTED HERE SHALL BE DEFINED ELSEWHERE IN THE BID DOCUMENTS IF NOT, CONTACT THE ENGINEER FOR CLARIFICATION AT LEAST 10 DAYS PRIOR TO BID OPENING.
- SOME SYMBOLS ARE DRAWN THE SAME WITH DIFFERENT MEANINGS. USE OF THE PROPER MEANING SHALL BE JUSTIFIED BY THE CONTEXT IN WHICH IT IS APPLIED.
- BASIC ENGLISH LANGUAGE, MATHEMATIC AND SCIENTIFIC TERMINOLOGY AS ACCEPTED BY INDUSTRY IS IMPLIED FOR GENERAL USE TERMS AND ABBREVIATIONS SUCH AS MIGHT BE FOUND IN A DICTIONARY OR MATH HANDBOOK.

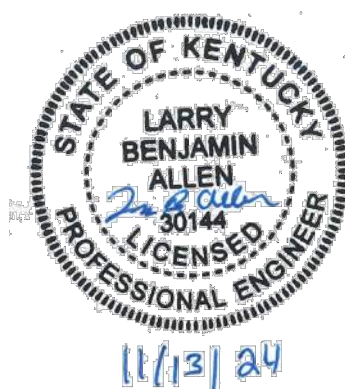


DESIGNER	LBA	DATE	BY	REVISION
DRAWN	TEW			
CHECKED	LBA			
APPROVED	LBA			

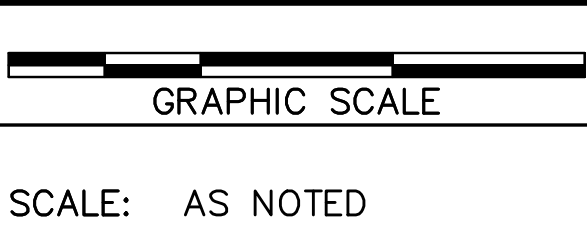

ALL RIGHTS RESERVED

THIS DOCUMENT IS THE PROPERTY OF BELL ENGINEERING AND SHALL NOT BE REPRODUCED IN WHOLE OR IN PART OR USED FOR CONSTRUCTION OF OTHER THAN THIS SPECIFIC PROJECT WITHOUT THE WRITTEN PERMISSION OF BELL ENGINEERING.

FACSIMILES OF LICENSED PROFESSIONAL ENGINEER AND/OR LAND SURVEYOR SEALS, IF AFFIXED TO THIS DOCUMENT, SHALL BE CONSIDERED LEGITIMATE ONLY IF SIGNED AND DATED BY THE REGISTRANT.


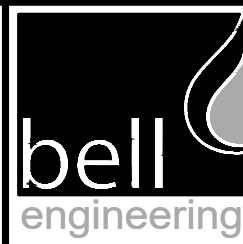


Lexington, KY (859) 278-5412
Hopkinsville, KY (270) 886-5466
Somerset, KY (606) 485-4011

WATER SYSTEM IMPROVEMENTS
SHOPEs CREEK ROAD AREA
CANNONSBURG WATER DISTRICT
CANNONSBURG, KENTUCKY

ELECTRICAL SYMBOLS AND ABBREVIATIONS


DIVISION	-
CONTRACT NO.	691-21-01
DATE	SEPTEMBER 2021
SHEET NO.	E01 OF E07

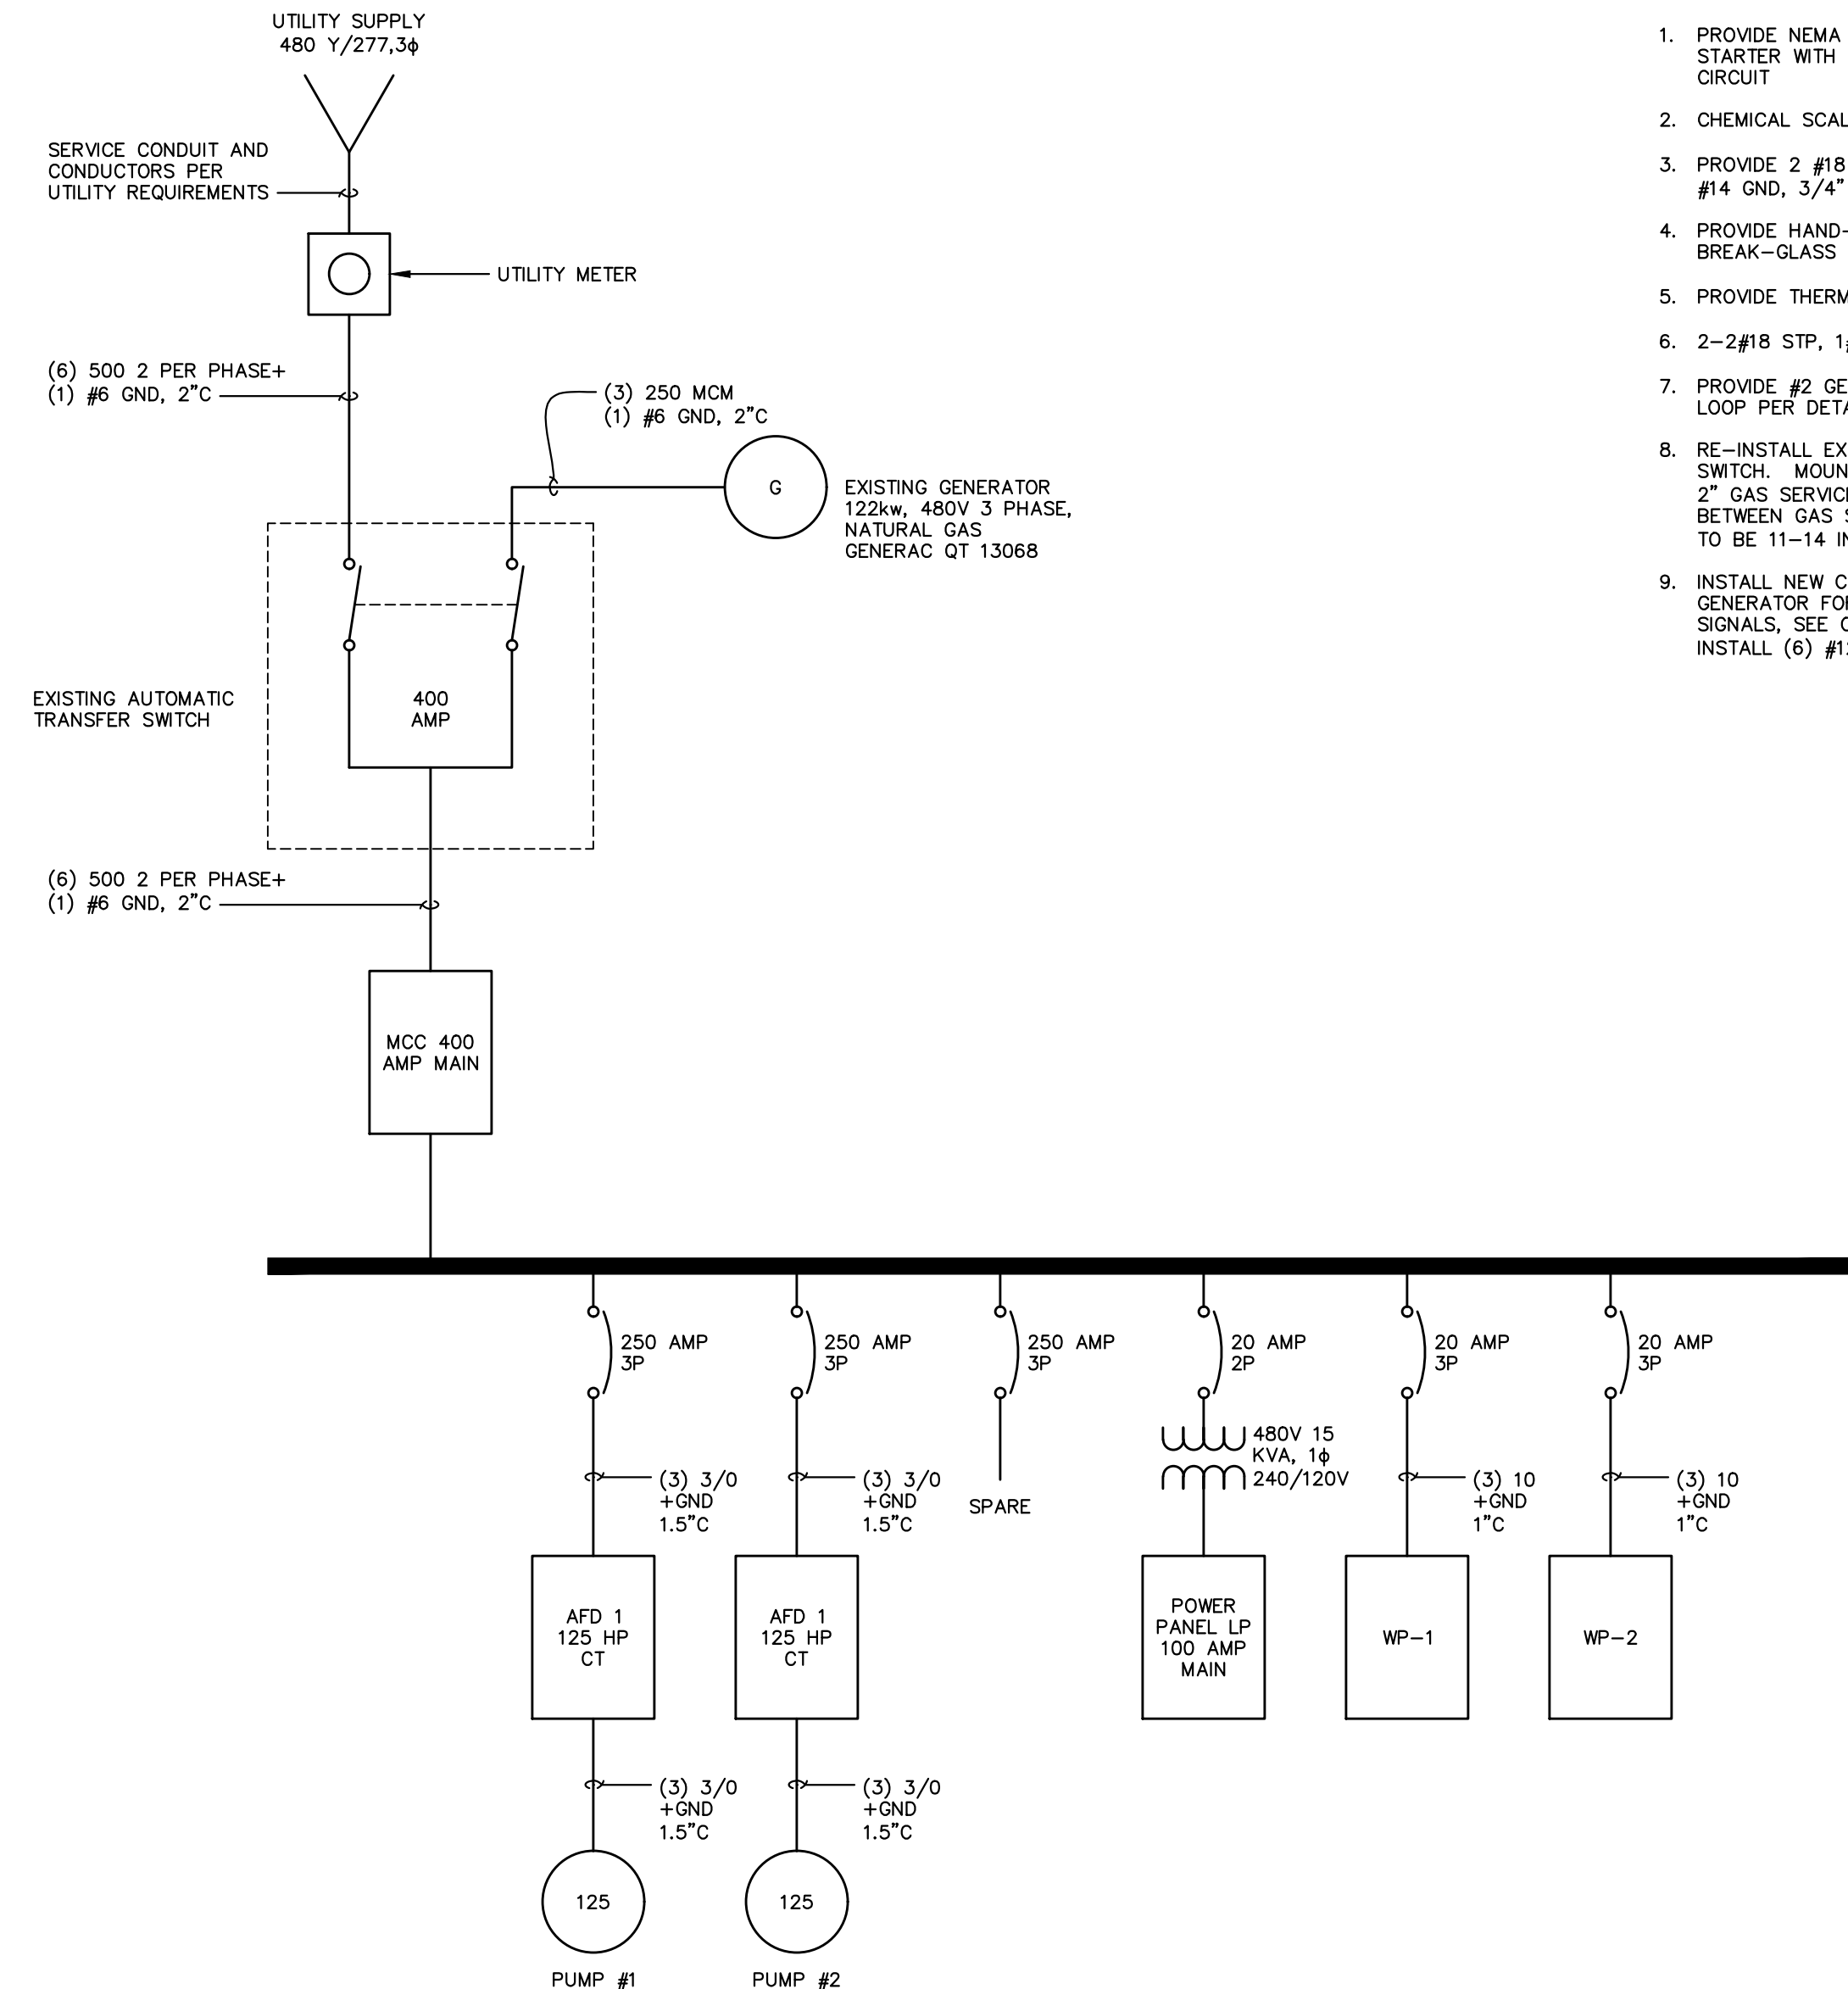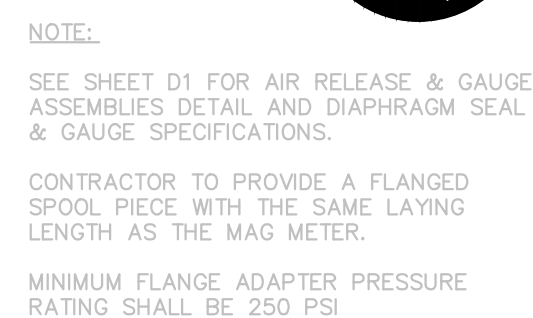


1. PROVIDE NEMA 4X SINGLE PHASE SIZE 1 COMBINATION STARTER WITH DISCONNECT. SEE EXHAUST FAN CONTROL CIRCUIT
2. CHEMICAL SCALE WITH PRIMARY CABLE PER DIVISION 11
3. PROVIDE 2 #18 STP, 3/4" FOR HYPO SPEED AND 4 #14, 1 #14 GND, 3/4" FOR HYPO CALL TO RUP SIGNALS.
4. PROVIDE HAND-OFF-AUTO SWITCH WITH PILOT LIGHT AND A BREAK-GLASS EMERGENCY SWITCH FOR FAN EF-1
5. PROVIDE THERMOSTAT CABLE 1 #14G, 3/4"
6. 2-#18 STP, 1#14G, 3/4"
7. PROVIDE #2 GEC, 3/4" AND PROVIDE #2 BUILDING GROUP LOOP PER DIVISION 11
8. RE-INSTALL EXISTING BACKUP GENERATOR AND TRANSFER SWITCH. MOUNT TRANSFER SWITCH TO WALL. RE-INSTALL 2" GAS SERVICE TO GENERATOR. INCLUDE FLEX CONNECTION BETWEEN GAS SERVICE AND GENERATOR SKID. GAS SERVICE TO BE 11-14 IN. W.C. WITH FLOW RATE OF 1807-432 BTU/HR.
9. INSTALL NEW CONDUIT BETWEEN TRANSFER SWITCH AND GENERATOR FOR POWER CABLES AND CONTROL SIGNALS. SEE ONE-LINE FOR POWER CABLES AND INSTALL (6) #2 THHN FOR CONTROL SIGNALS..

VOLTAGE		240 / 120 3 WIRE				PANEL		LP	
MAIN AMP RATING		100 AMP				ENCLOSURE		NEMA 1	
TOTAL SPACES		24				LOCATION		SHOPES CREEK BOOSTER PUMP	
CIRCUIT	BREAKER	POLES	NO	PHASE A	PHASE B	NO	POLES	BREAKER	CIRCUIT
			1	100		2	1	15	FLOW METER
SPD	30A	2	3		800	4	1	20	LIGHTING
SCADA RTU	15	1	5	1000	800	6	1	20	RECEPTS
RECPTS	20	1	7	400	400	8	1	20	SPARE
RECPTS	20	1	9	400		10	1	20	SPARE
SPARE	20	1	11			12	1	20	SPARE
SPARE	20	1	13			14	1	20	SPARE
SPARE	20	1	15			16	1	20	SPARE
SPARE	20	1	17			18	1	20	SPARE
SPARE	20	1	19			20	1	20	SPARE
SPARE	20	1	21			22	1	20	SPARE
SPARE	20	1	23			24	1	20	SPARE
TOTAL VA PER PHASE				1900	2000				
TOTAL AMPS PER PHASE				15.83	16.67				

ELECTRICAL LP PANEL SCHEDULE

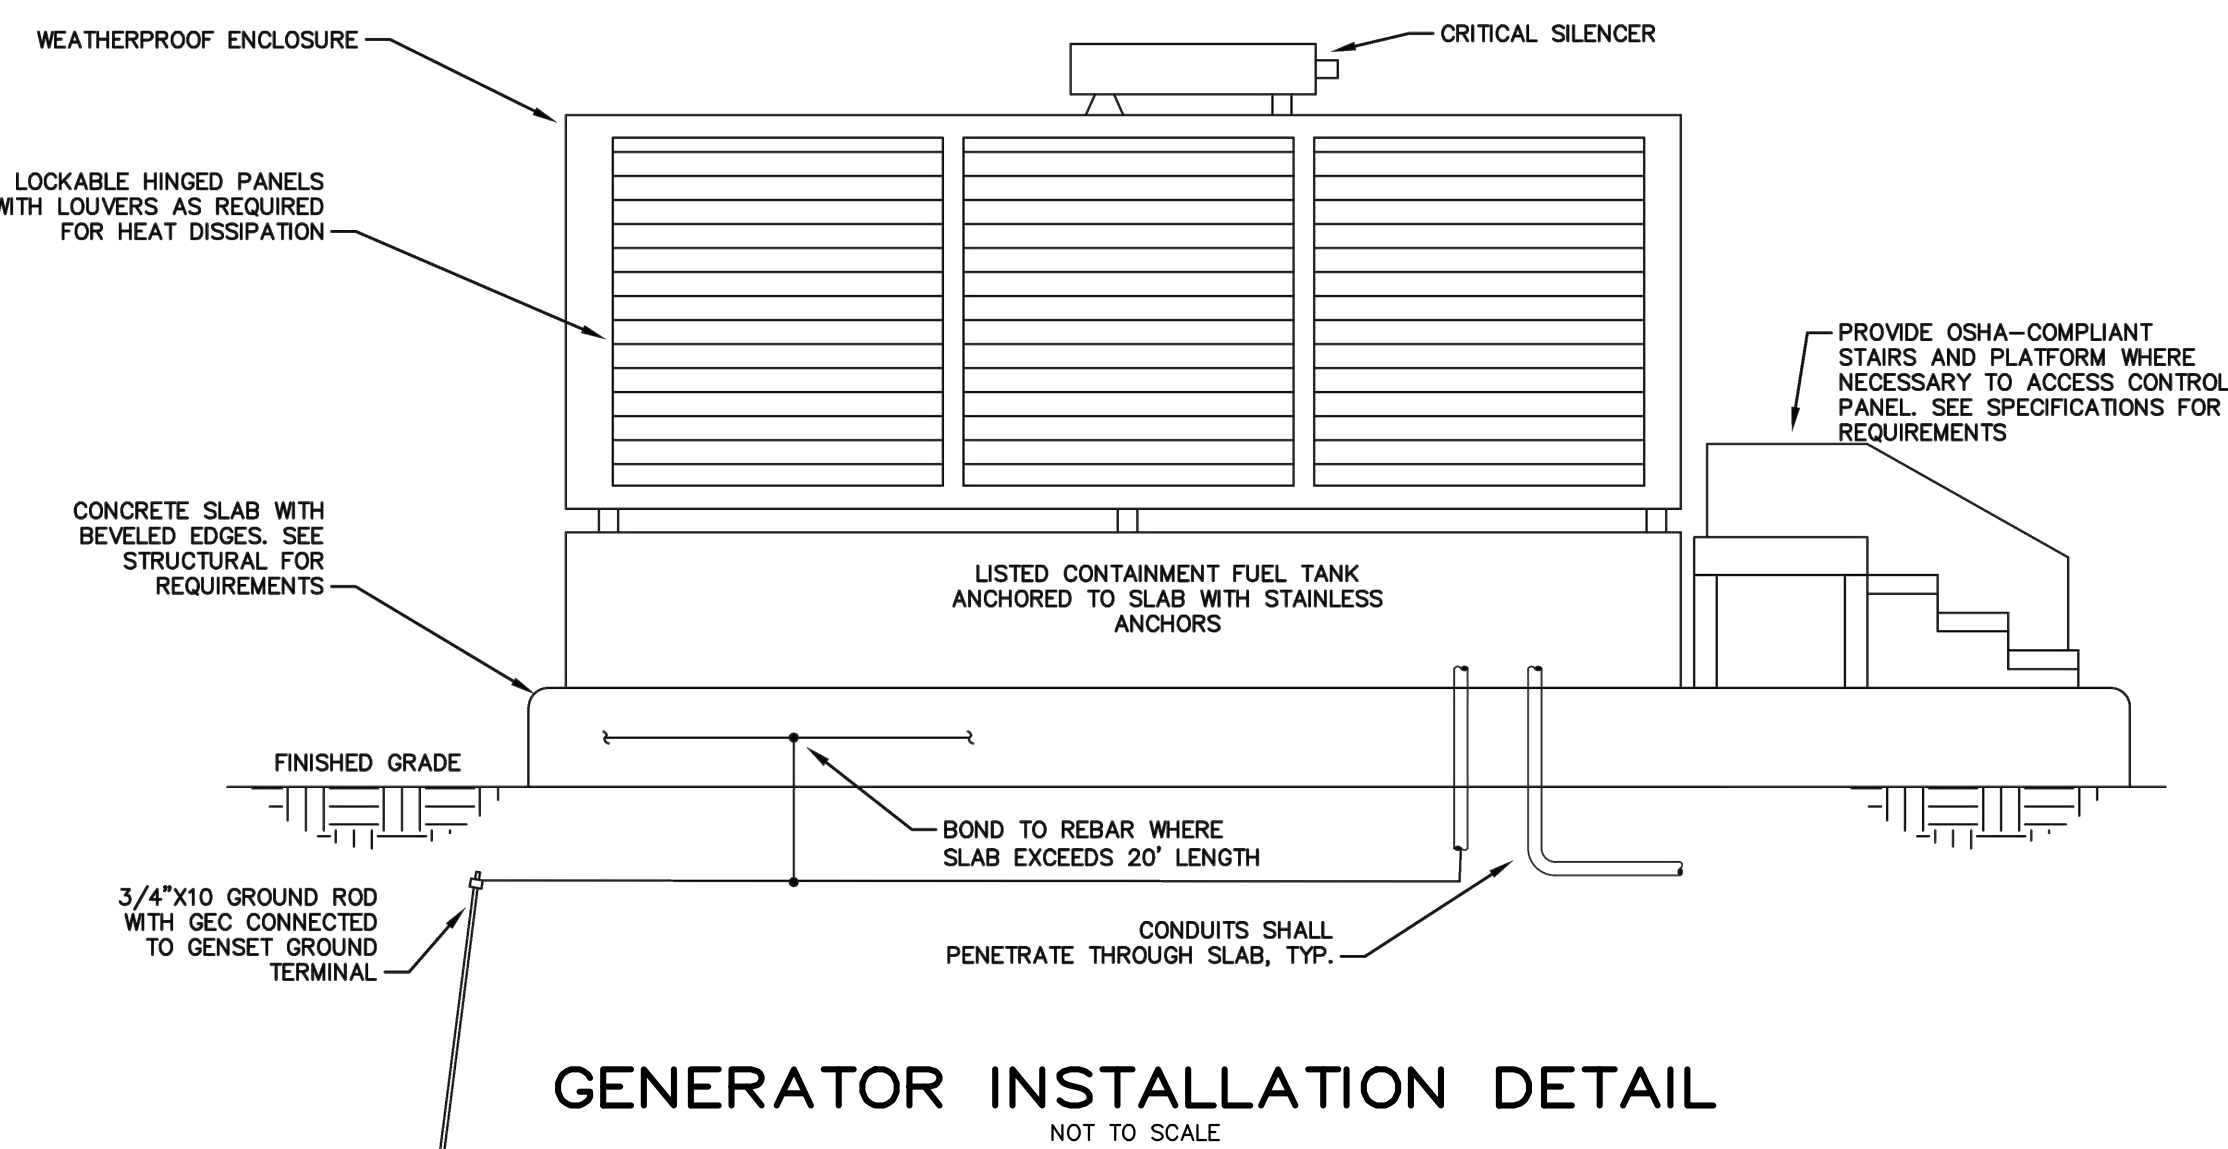

GENERATOR INSTALLATION DETAIL

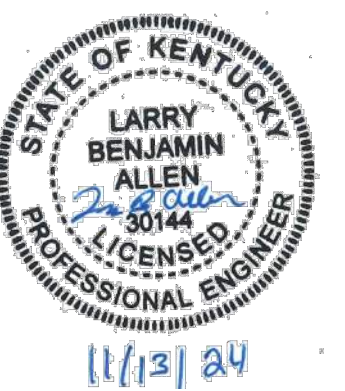

DESIGNER	LBA	DATE	BY	REVISION
DRAWN	TEW			
CHECKED	LBA			
APPROVED	LBA			


GRAPHIC SCALE

SCALE: AS NOTED

ALL RIGHTS RESERVED

THIS DOCUMENT IS THE PROPERTY OF BELL ENGINEERING AND SHALL NOT BE REPRODUCED IN WHOLE OR IN PART OR USED FOR CONSTRUCTION OF OTHER THAN THIS SPECIFIC PROJECT WITHOUT THE WRITTEN PERMISSION OF BELL ENGINEERING

FACSIMILES OF LICENSED PROFESSIONAL ENGINEER AND/OR LAND SURVEYOR SEALS, IF AFFIXED TO THIS DOCUMENT, SHALL BE CONSIDERED LEGITIMATE ONLY IF SIGNED AND DATED BY THE REGISTRANT

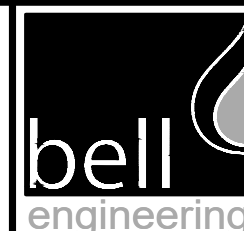


Lexington, KY (859) 278-5412
Hopkinsville, KY (270) 886-5466
Somerset, KY (606) 485-4011


WATER SYSTEM IMPROVEMENTS
SHOPES CREEK ROAD AREA
CANNONBURG WATER DISTRICT
CANNONBURG, KENTUCKY

ELECTRICAL POWER DISTRIBUTION PLAN

DIVISION	—
CONTRACT NO.	691-21-01
DATE	SEPTEMBER 2021
SHEET NO.	E02 OF E07

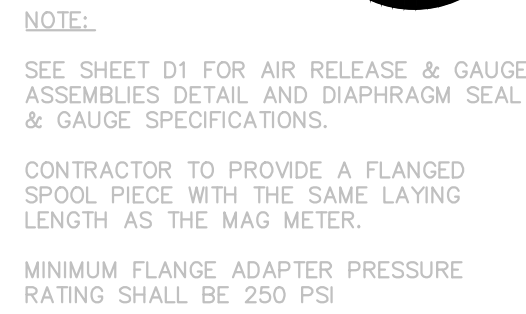

DIVISION	—
CONTRACT NO.	691—21—01
DATE	SEPTEMBER 2021
SHEET NO.	E03 OF E07

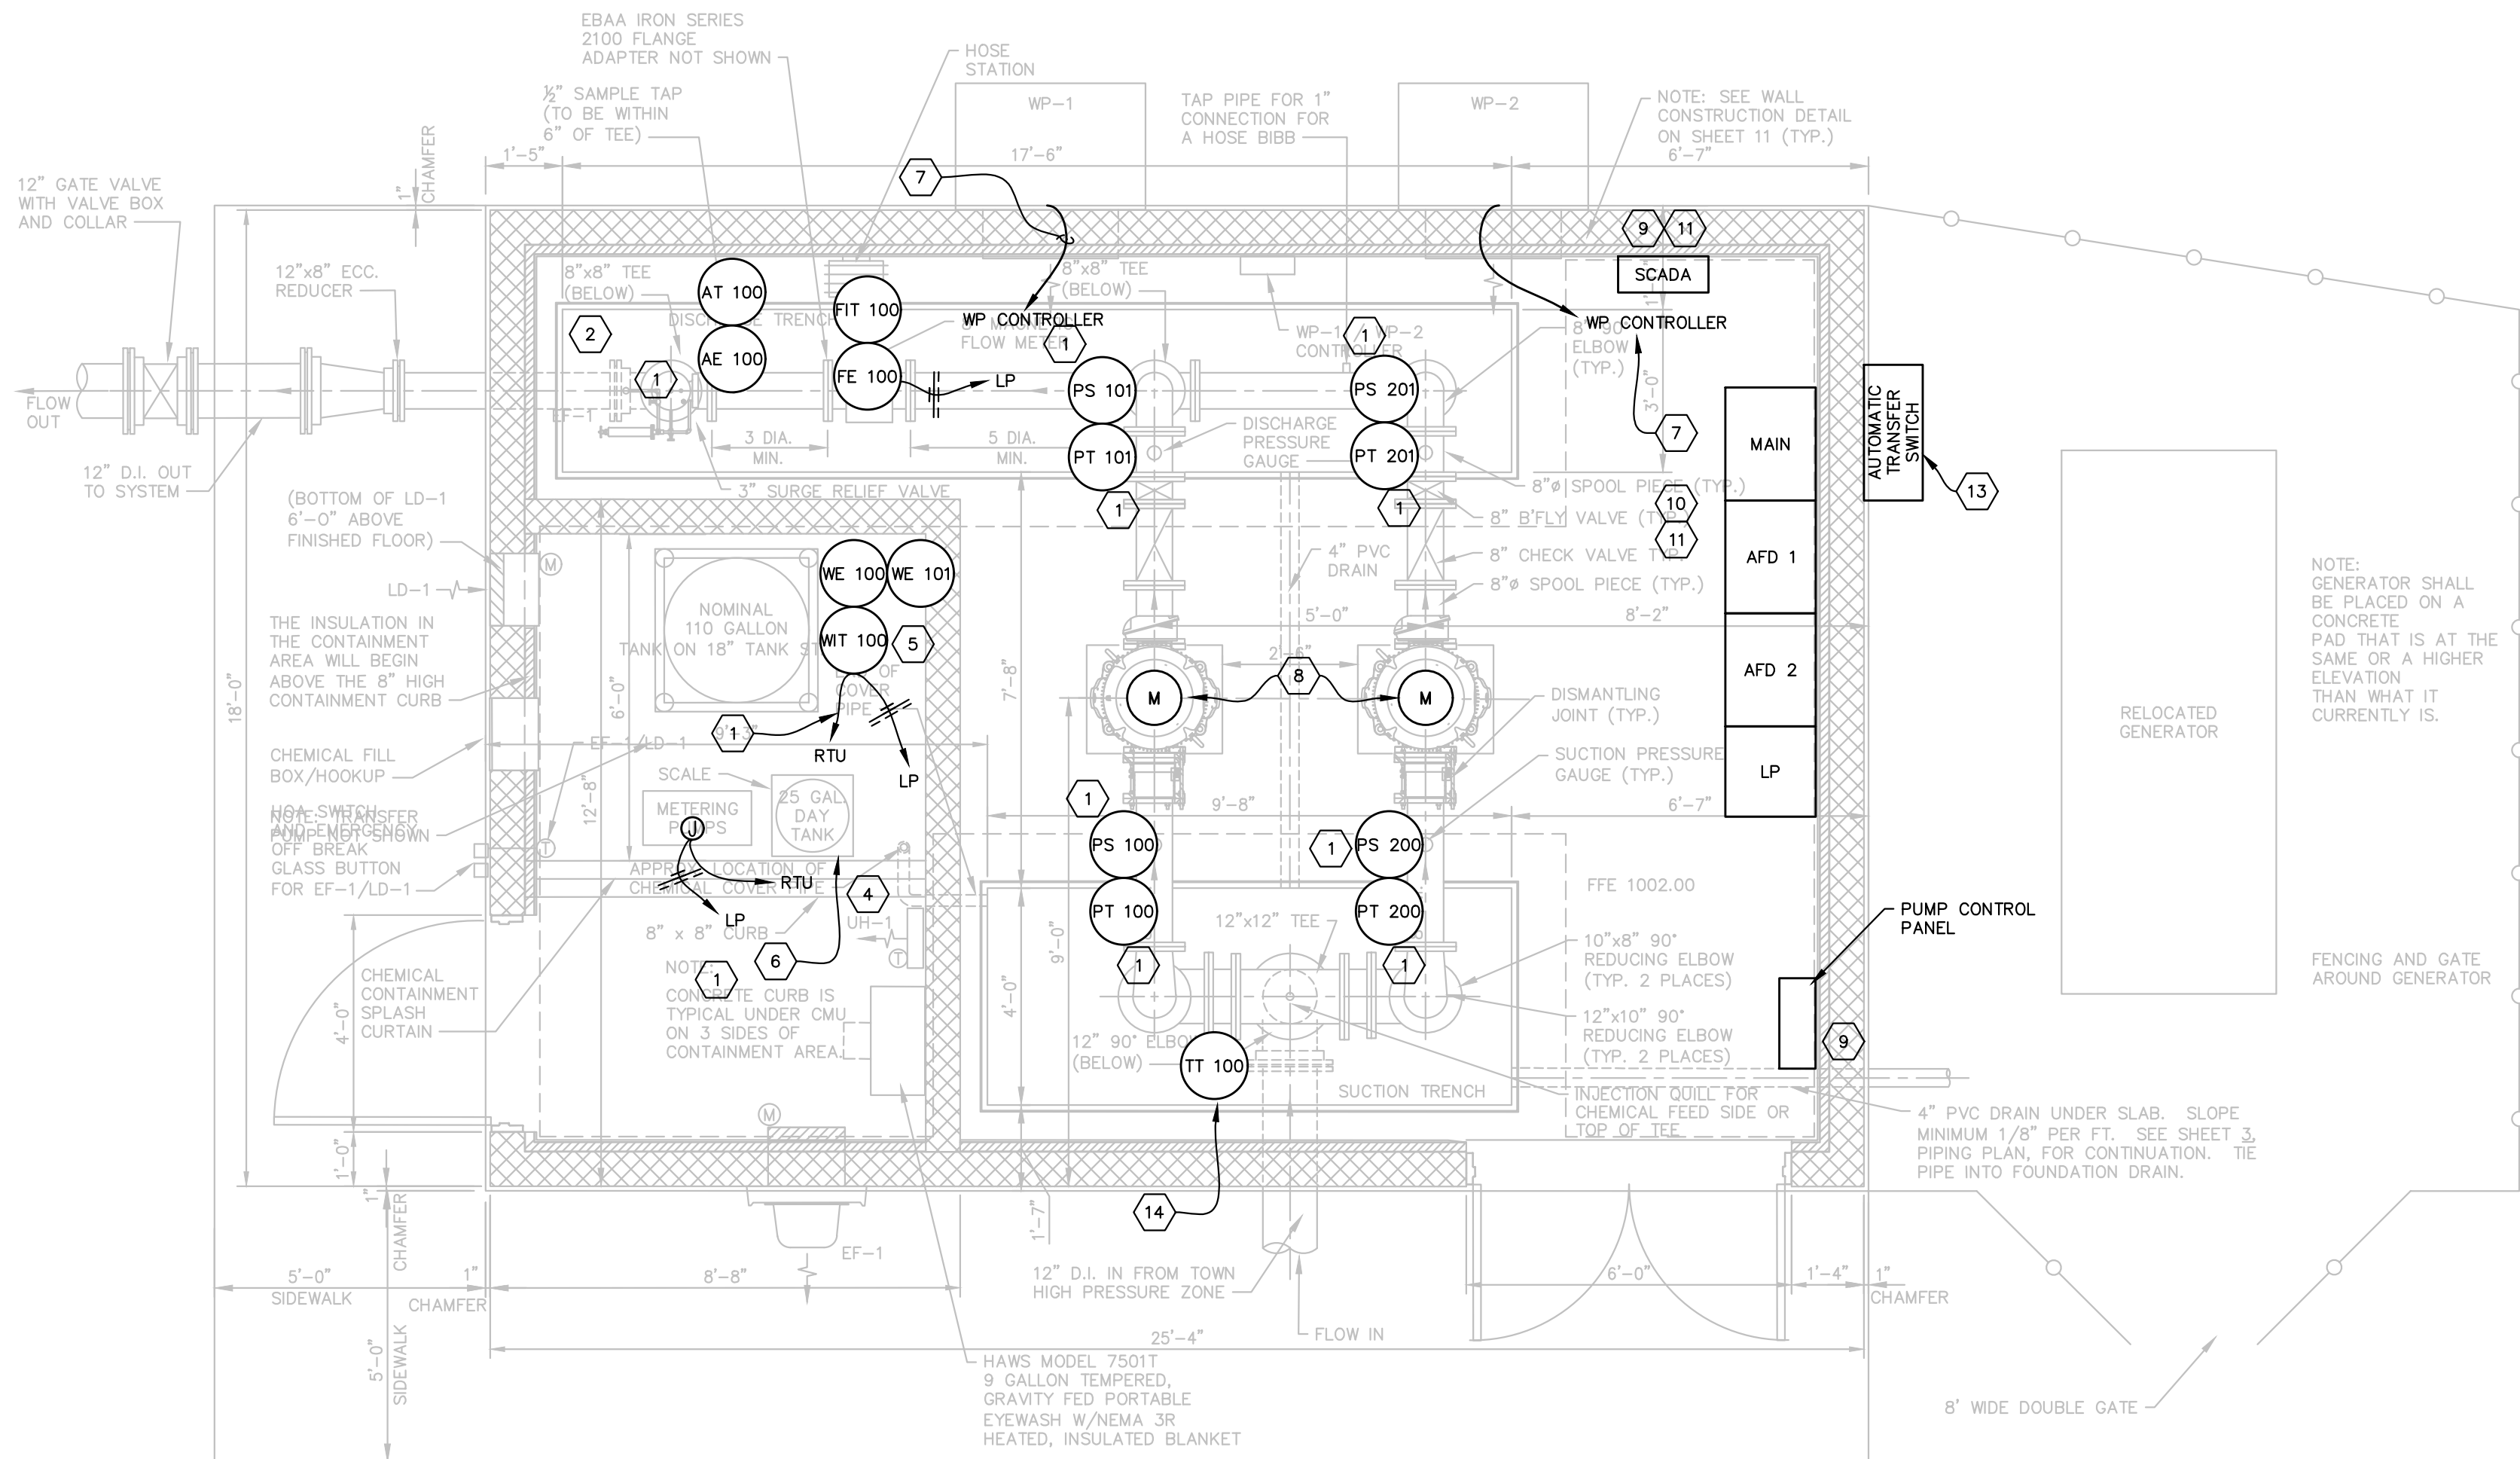


- NOTES:
1. PROVIDE 2 #18 STP, 1 #14, 3/4" C. FROM METER TO RTU
 2. CHEMICAL SCALE WITH PRIMARY CABLE PER DIVISION 11
 3. PROVIDE 2 #18 STP, 3/4" C FOR HYPO SPEED AND 4 #14, 1 #14 GND, 3/4" C FOR HYPO CALL TO RUN SIGNALS.
 4. PROVIDE 10 #18 STP, 1" C AND 12 #14, 1#14 GND, 3/4" C
 5. PROVIDE LOCKABLE 20A / 1 P SAFETY SWITCH FOR VALVE
 6. HYPO DISCHARGE SAFETY VALVE, PROVIDE INTERLOCK WITH PUMP CONTROL PANEL, IF NO PUMPS ARE RUNNING, THE VALVE IS CLOSED.
 7. PROVIDE THERMOSTAT CABLE 1 #14G, 3/4" C
 8. 2-2#18 STP, 1#14G, 3/4" C
 9. PROVIDE (8) #18 STP, 1#14G, 1" C FROM PUMP CONTROL PANEL TO SCADA PANEL. SIGNALS FOR OVER TEMP, DRIVE FAULT, AND SCADA FAULT FOR 2 PUMPS.
 10. PROVIDE (6) #18 STP, 1#14G, 1" C FROM PUMP CONTROL PANEL TO MCC. SIGNALS FOR PUMP CALL AND RUN STATUS, AFD1, AFD2.
 11. PROVIDE (4) #18 STP, 1#14G, 1" C FROM SCADA PANEL TO MCC. SIGNALS FOR PUMP SPEED REFERENCE AND PUMP SPEED FEEDBACK. AFD 1, AFD 2, AND SPARE FOR AFD 3
 12. 2-2#18 STP, 1#14G, 3/4" C BETWEEN HVAC CONTROL PANEL AND SCADA
 13. INSTALL NEW CONDUIT BETWEEN TRANSFER SWITCH AND GENERATOR FOR POWER CONDUCTORS AND CONTROL SIGNALS, SEE ONE-LINE FOR POWER CONDUCTORS AND INSTALL (6) #12 THWN FOR CONTROL SIGNALS.
 14. AMBIENT AIR TEMPERATURE AND HUMIDITY INDICATING TRANSMITTER, OMEGA HX93B OR EQUAL, WALL MOUNTED, (3) #18 STP IN 3/4" CONDUIT. CONNECT TO STATION SCADA ANALOG INPUT. ALARM ON HIGH TEMPERATURE 82 DEGREES.

PLAN
SCALE: 3/8"=1'-0"


NOTE:
SEE SHEET D1 FOR AIR RELEASE & GAUGE ASSEMBLIES DETAIL AND DIAPHRAGM SEAL & GAUGE SPECIFICATIONS.
CONTRACTOR TO PROVIDE A FLANGED SPOOL PIECE WITH THE SAME LAYING LENGTH AS THE MAG METER.
MINIMUM FLANGE ADAPTER PRESSURE RATING SHALL BE 250 PSI

INSTRUMENTATION SCHEDULE								
TAG	DESCRIPTION	TYPE	RANGE	UNITS	OUTPUT	POWER	SENSOR MOUNTING	TRANS. MOUNTING
FT-100	FLOW TRANSMITTER	FLOW	0-500	GPM	4-20 mA	LOOP	ANSI FLANGE	ANSI FLANGE
PT-100	SUCTION PRESSURE TRANSMITTER	PRESSURE	0-250	PSIG	4-20 mA	LOOP	ANSI FLANGE	ANSI FLANGE
PT-101	DISCHARGE PRESSURE TRANSMITTER	PRESSURE	0-250	PSIG	4-20 mA	LOOP	ANSI FLANGE	ANSI FLANGE
PT-200	SUCTION PRESSURE TRANSMITTER	PRESSURE	0-250	PSIG	4-20 mA	LOOP	ANSI FLANGE	ANSI FLANGE
PT-201	DISCHARGE PRESSURE TRANSMITTER	PRESSURE	0-250	PSIG	4-20 mA	LOOP	ANSI FLANGE	ANSI FLANGE
WT-100	SCALE TRANSMITTER	SCALE	0-500	LBS	4-20 mA	LOOP	PAD	PAD
WE-100	DAY TANK SCALE	SCALE	0-500	LBS	4-20 mA	LOOP	PAD	PAD
WE-101	BULK TANK SCALE	SCALE	0-500	LBS	4-20 mA	LOOP	PAD	PAD
AT-100	RESIDUAL CHLORINE	CHLORINE ANALYZER	0-5	MG/L	4-20 mA	120VAC	WALL MOUNT	WALL MOUNT
TIT-100	AMBIENT AIR TEMPERATURE / HUMIDITY TRANSMITTER	TEMPERATURE	0-100 F	DEGREES	4-20 mA	LOOP		WALL
PS-100	SUCTION PRESSURE ALARM	PRESSURE SWITCH			DI	LOOP	ANSI FLANGE	ANSI FLANGE
PT-100	DISCHARGE PRESSURE ALARM	PRESSURE SWITCH			DI	LOOP	ANSI FLANGE	ANSI FLANGE
PS-201	SUCTION PRESSURE ALARM	PRESSURE SWITCH			DI	LOOP	ANSI FLANGE	ANSI FLANGE
PS-200	DISCHARGE PRESSURE ALARM	PRESSURE SWITCH			DI	LOOP	ANSI FLANGE	ANSI FLANGE

SCADA IO TABLE													
TAG	TYPE	UNIT	CONTROL	MONITOR	TREND	HISTORIZE	TOTALIZE	ALARM	AVERAGE	REPORT	SECURITY	NOTES	
WT-100	AI	LBS	X	X						X			
AIT-100	AI	MB / L	X	X	X		X	X		X		ALARM LOW AND HIGH LEVELS, PROVIDE HOURLY LOG REPORT	
HYPO METER PUMP #1 SPEED FEEDBACK	AI	%		X	X	X							
HYPO METER PUMP #2 SPEED FEEDBACK	AI	%		X	X	X							
FT-100	AI	FT		X	X	X							
PT-100	AI	PSI		X	X	X		X				SUCTION PRESSURE	
PT-101	AI	PSI		X	X	X		X				DISCHARGE PRESSURE	
PT-200	AI	PSI		X	X	X		X				SUCTION PRESSURE	
PT-201	AI	PSI		X	X	X		X				DISCHARGE PRESSURE	
RTU BATTERY ALARM	AI	V						X		X			
PUMP 1 SPEED FEEDBACK	AI	HZ		X	X	X							
PUMP 2 SPEED FEEDBACK	AI	HZ		X	X	X							
PUMP 3 SPEED FEEDBACK	AI	HZ		X	X	X							
AMBIENT AIR TEMPERATURE	AI	DEGREES		X	X			X		X		ALARM AT 82 DEGREES	
AMBIENT AIR HUMIDITY	AI	PERCENT		X	X			X					
PUMP 1 SPEED COMMAND	AO	HZ	X										
PUMP 2 SPEED COMMAND	AO	HZ	X										
PUMP 3 SPEED COMMAND	AO	HZ	X										
HYPO METER PUMP #1 RUN STATUS	DI			X		X		X		X		ALARM FAIL TO START, REPORT # OF STARTS AND RUNTIME	
HYPO METER PUMP#1 FAULT	DI			X		X		X		X			
HYPO METER PUMP #2 RUN STATUS	DI			X		X		X		X		ALARM FAIL TO START, REPORT # OF STARTS AND RUNTIME	
HYPO METER PUMP#2 FAULT	DI			X		X		X		X			
HVAC SUMMARY ALARM	DI			X		X		X					
FT-100	DI	FT		X	X	X		X					
PS-100	DI			X				X				SUCTION PRESSURE ALARM	
PS-101	DI			X				X				DISCHARGE PRESSURE ALARM	
PS-200	DI			X				X				SUCTION PRESSURE ALARM	
PS-201	DI			X				X				DISCHARGE PRESSURE ALARM	
RTU POWER LOSS ALARM	DI							X		X			
RTU SURGE PROTECTION ALARM	DI							X		X			
PUMP 1 RUNNING STATUS	DI									X			
PUMP 1 OVERTEMP	DI							X					
PUMP 1 DRIVE FAULT	DI							X					
PUMP 2 RUNNING STATUS	DI									X			
PUMP 2 OVERTEMP	DI							X					
PUMP 2 DRIVE FAULT	DI							X					
PUMP 3 RUNNING STATUS	DI									X			
PUMP 3 OVERTEMP	DI							X					
PUMP 3 DRIVE FAULT	DI							X					
HYPO METER PUMP #1 PERMISSIVE	DO		X			X							
HYPO METER PUMP #2 PERMISSIVE	DO		X			X							
PUMP 1 START	DO		X										
PUMP 2 START	DO		X										
PUMP 3 START	DO		X										

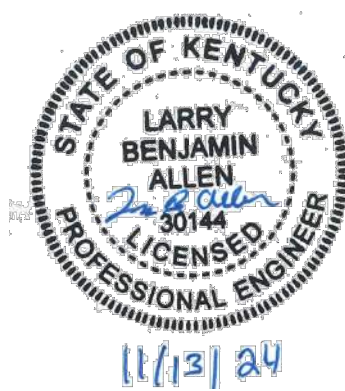


DESIGNER	LBA	DATE	BY	REVISION
DRAWN	TEW			
CHECKED	LBA			
APPROVED	LBA			

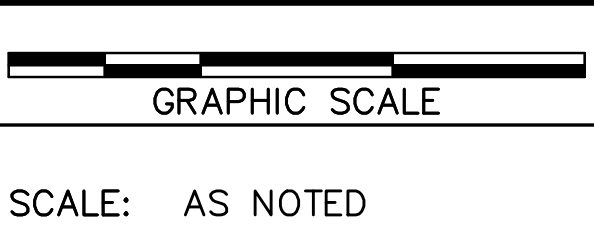

ALL RIGHTS RESERVED
THIS DOCUMENT IS THE PROPERTY OF BELL ENGINEERING AND SHALL NOT BE REPRODUCED IN WHOLE OR IN PART OR USED FOR CONSTRUCTION OF OTHER THAN THIS SPECIFIC PROJECT WITHOUT THE WRITTEN PERMISSION OF BELL ENGINEERING. FACSIMILES OF LICENSED PROFESSIONAL ENGINEER AND/OR LAND SURVEYOR SEALS, IF AFFIXED TO THIS DOCUMENT, SHALL BE CONSIDERED LEGITIMATE ONLY IF SIGNED AND DATED BY THE REGISTRANT.

Lexington, KY (859) 278-5412
Hopkinsville, KY (270) 886-5466
Somerset, KY (606) 485-4011

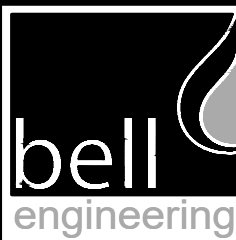


WATER SYSTEM IMPROVEMENTS
SHOPES CREEK ROAD AREA
CANNONBURG WATER DISTRICT
CANNONBURG, KENTUCKY


INSTRUMENTATION PLAN

DIVISION	-
CONTRACT NO.	691-21-01
DATE	SEPTEMBER 2021
SHEET NO.	E04 OF E07


J:\CANNONSURG\SHOPES CREEK ROAD AREA\CAD Design\21-691210\DWG05.dwg E05 12/22/2024 11:01:00 AM twbier AutoCAD PDF (General Documentation).pc3
Plot Style: 000-BELL-STD.ctb

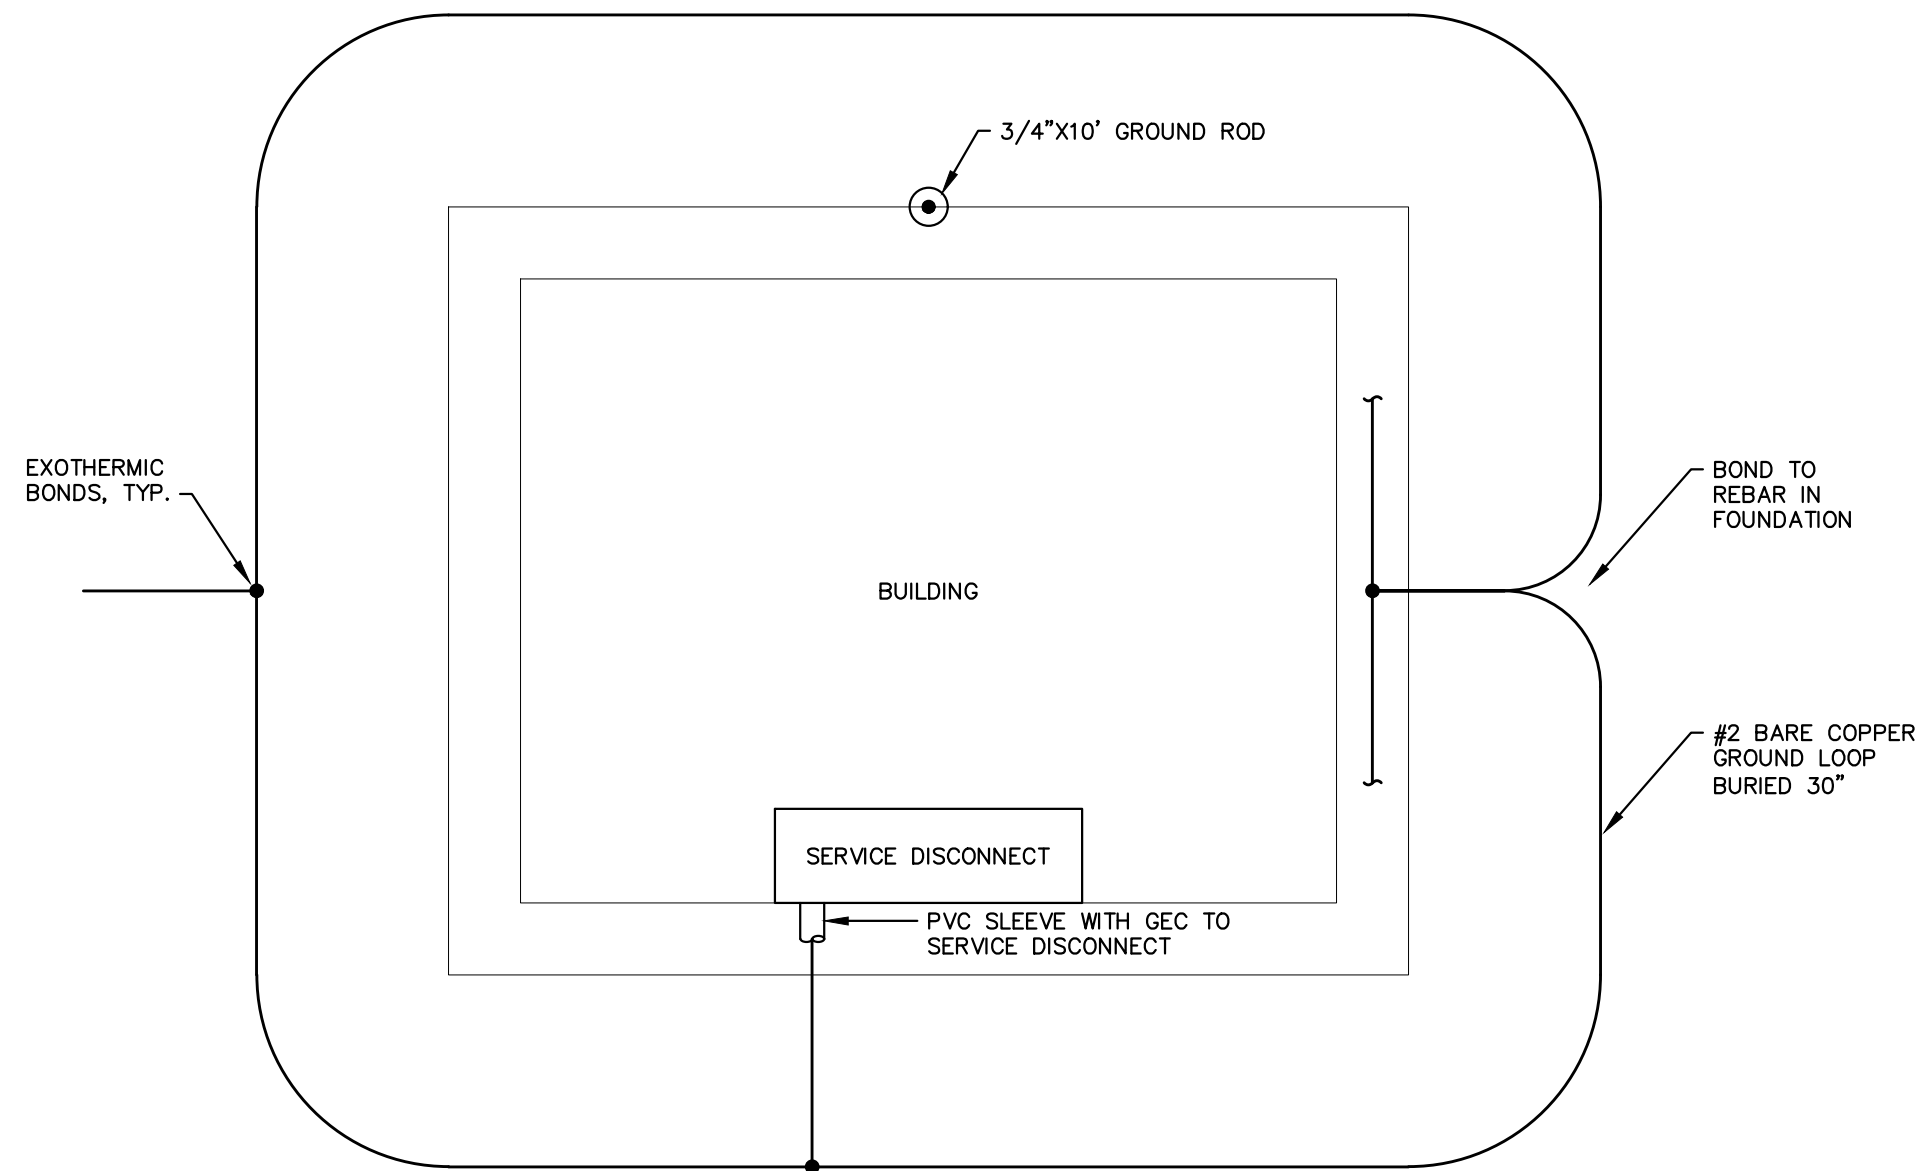

BUILDING GROUNDING DETAIL
NOT TO SCALE

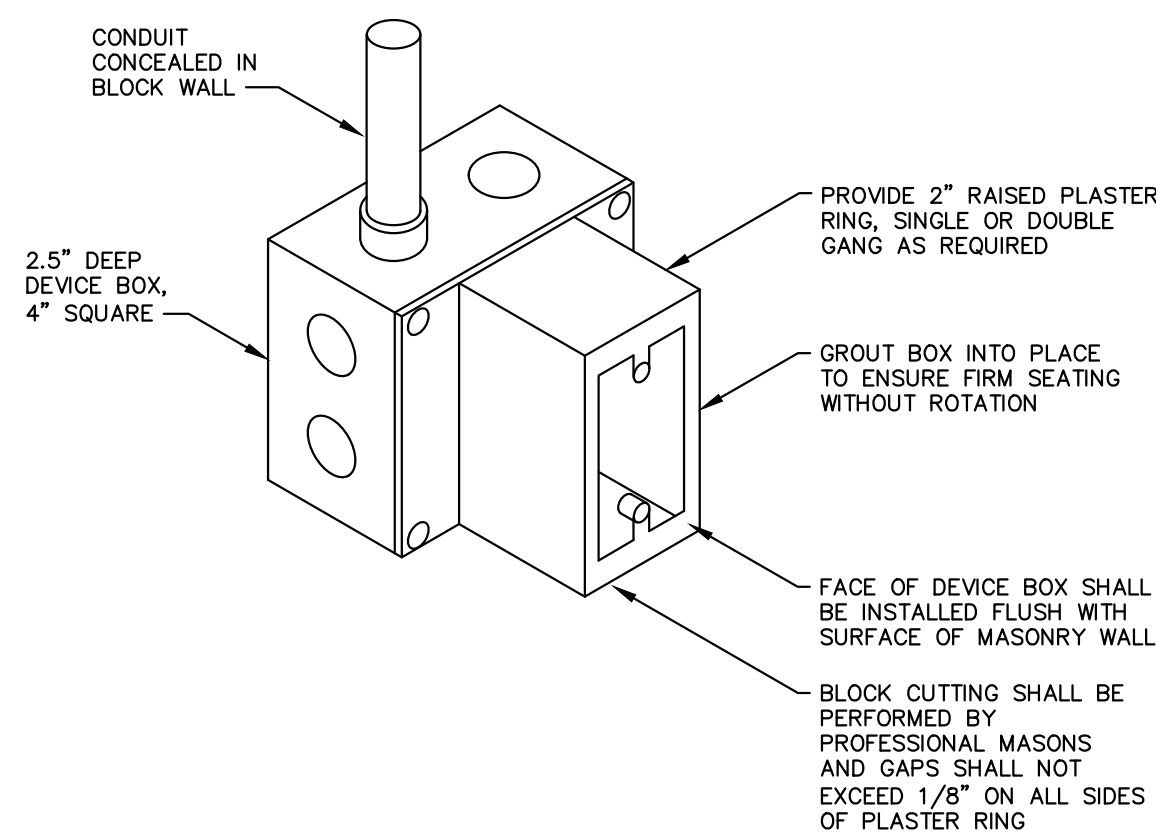


TYPICAL OUTLET
JUNCTION BOX DETAIL
NOT TO SCALE

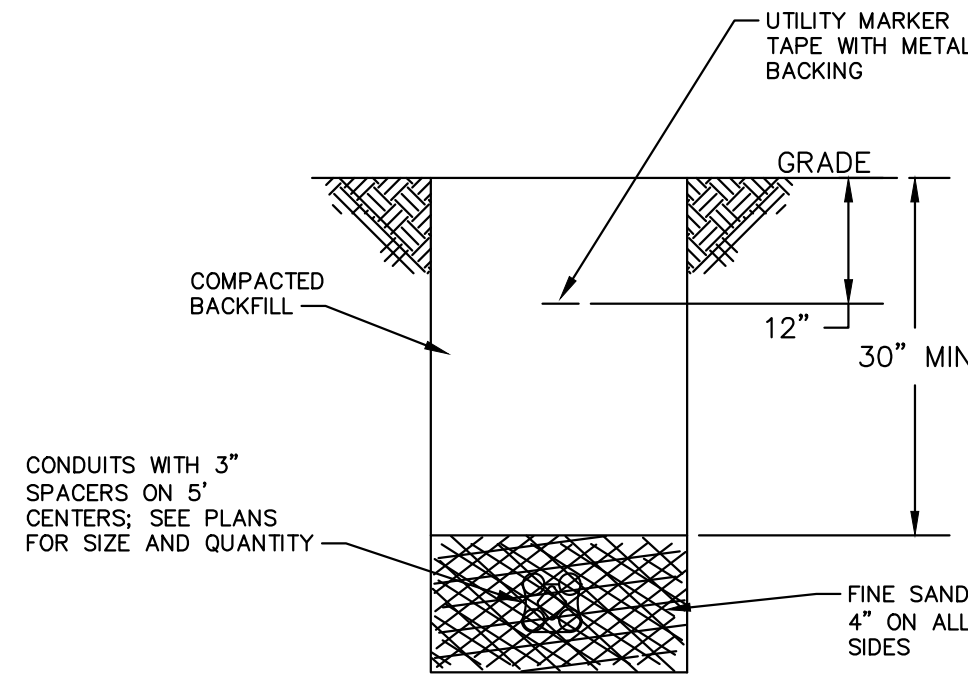


TYPICAL TRENCH DETAIL 1
NOT TO SCALE

TRENCHING NOTES:


- PROVIDE PULL CORD IN ALL CONDUITS.
- UTILITY MARKER TAPE SHALL RUN THE ENTIRE LENGTH OF DUCT BANK.
- MAINTAIN MINIMUM 36" SPACING BETWEEN OTHER SITE PIPING, INCLUDING WATER, AND GAS.

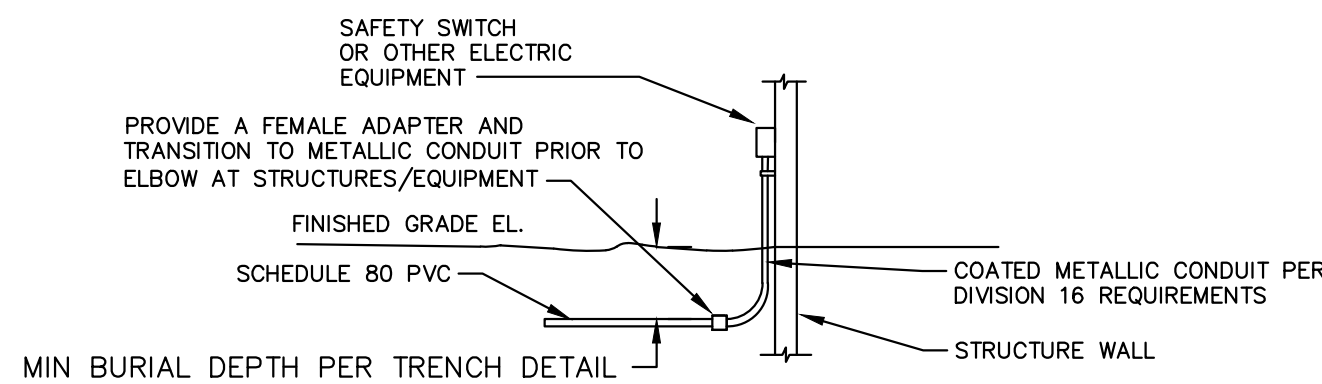

TYPICAL UNDERGROUND PVC CONDUIT
TRANSITION TO METALLIC CONDUIT DETAIL 3
NOT TO SCALE

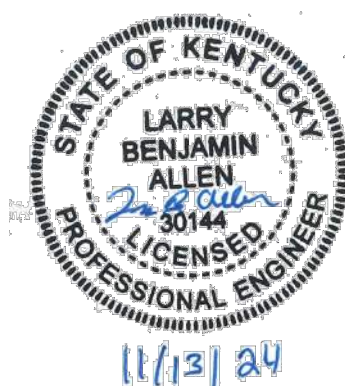


DESIGNER	LBA	DATE	BY	REVISION
DRAWN	TEW			
CHECKED	LBA			
APPROVED	LBA			

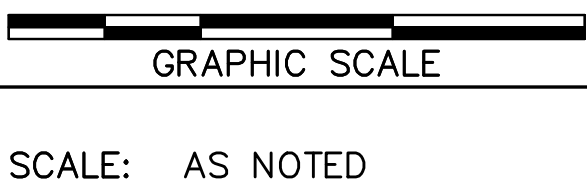

ALL RIGHTS RESERVED

THIS DOCUMENT IS THE PROPERTY OF BELL ENGINEERING AND SHALL NOT BE REPRODUCED IN WHOLE OR IN PART OR USED FOR CONSTRUCTION OF OTHER THAN THIS SPECIFIC PROJECT WITHOUT THE WRITTEN PERMISSION OF BELL ENGINEERING.

FACSIMILES OF LICENSED PROFESSIONAL ENGINEER AND/OR LAND SURVEYOR SEALS, IF AFFIXED TO THIS DOCUMENT, SHALL BE CONSIDERED LEGITIMATE ONLY IF SIGNED AND DATED BY THE REGISTRANT.


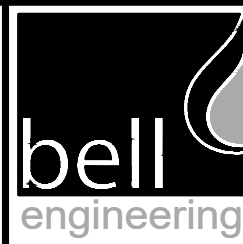


Lexington, KY (859) 278-5412
Hopkinsville, KY (270) 886-5466
Somerset, KY (606) 485-4011



WATER SYSTEM IMPROVEMENTS
SHOPES CREEK ROAD AREA
CANNONSURG WATER DISTRICT
CANNONSURG, KENTUCKY

ELECTRICAL DETAILS

DIVISION	—
CONTRACT NO.	691-21-01
DATE	SEPTEMBER 2021
SHEET NO.	E05 OF E07

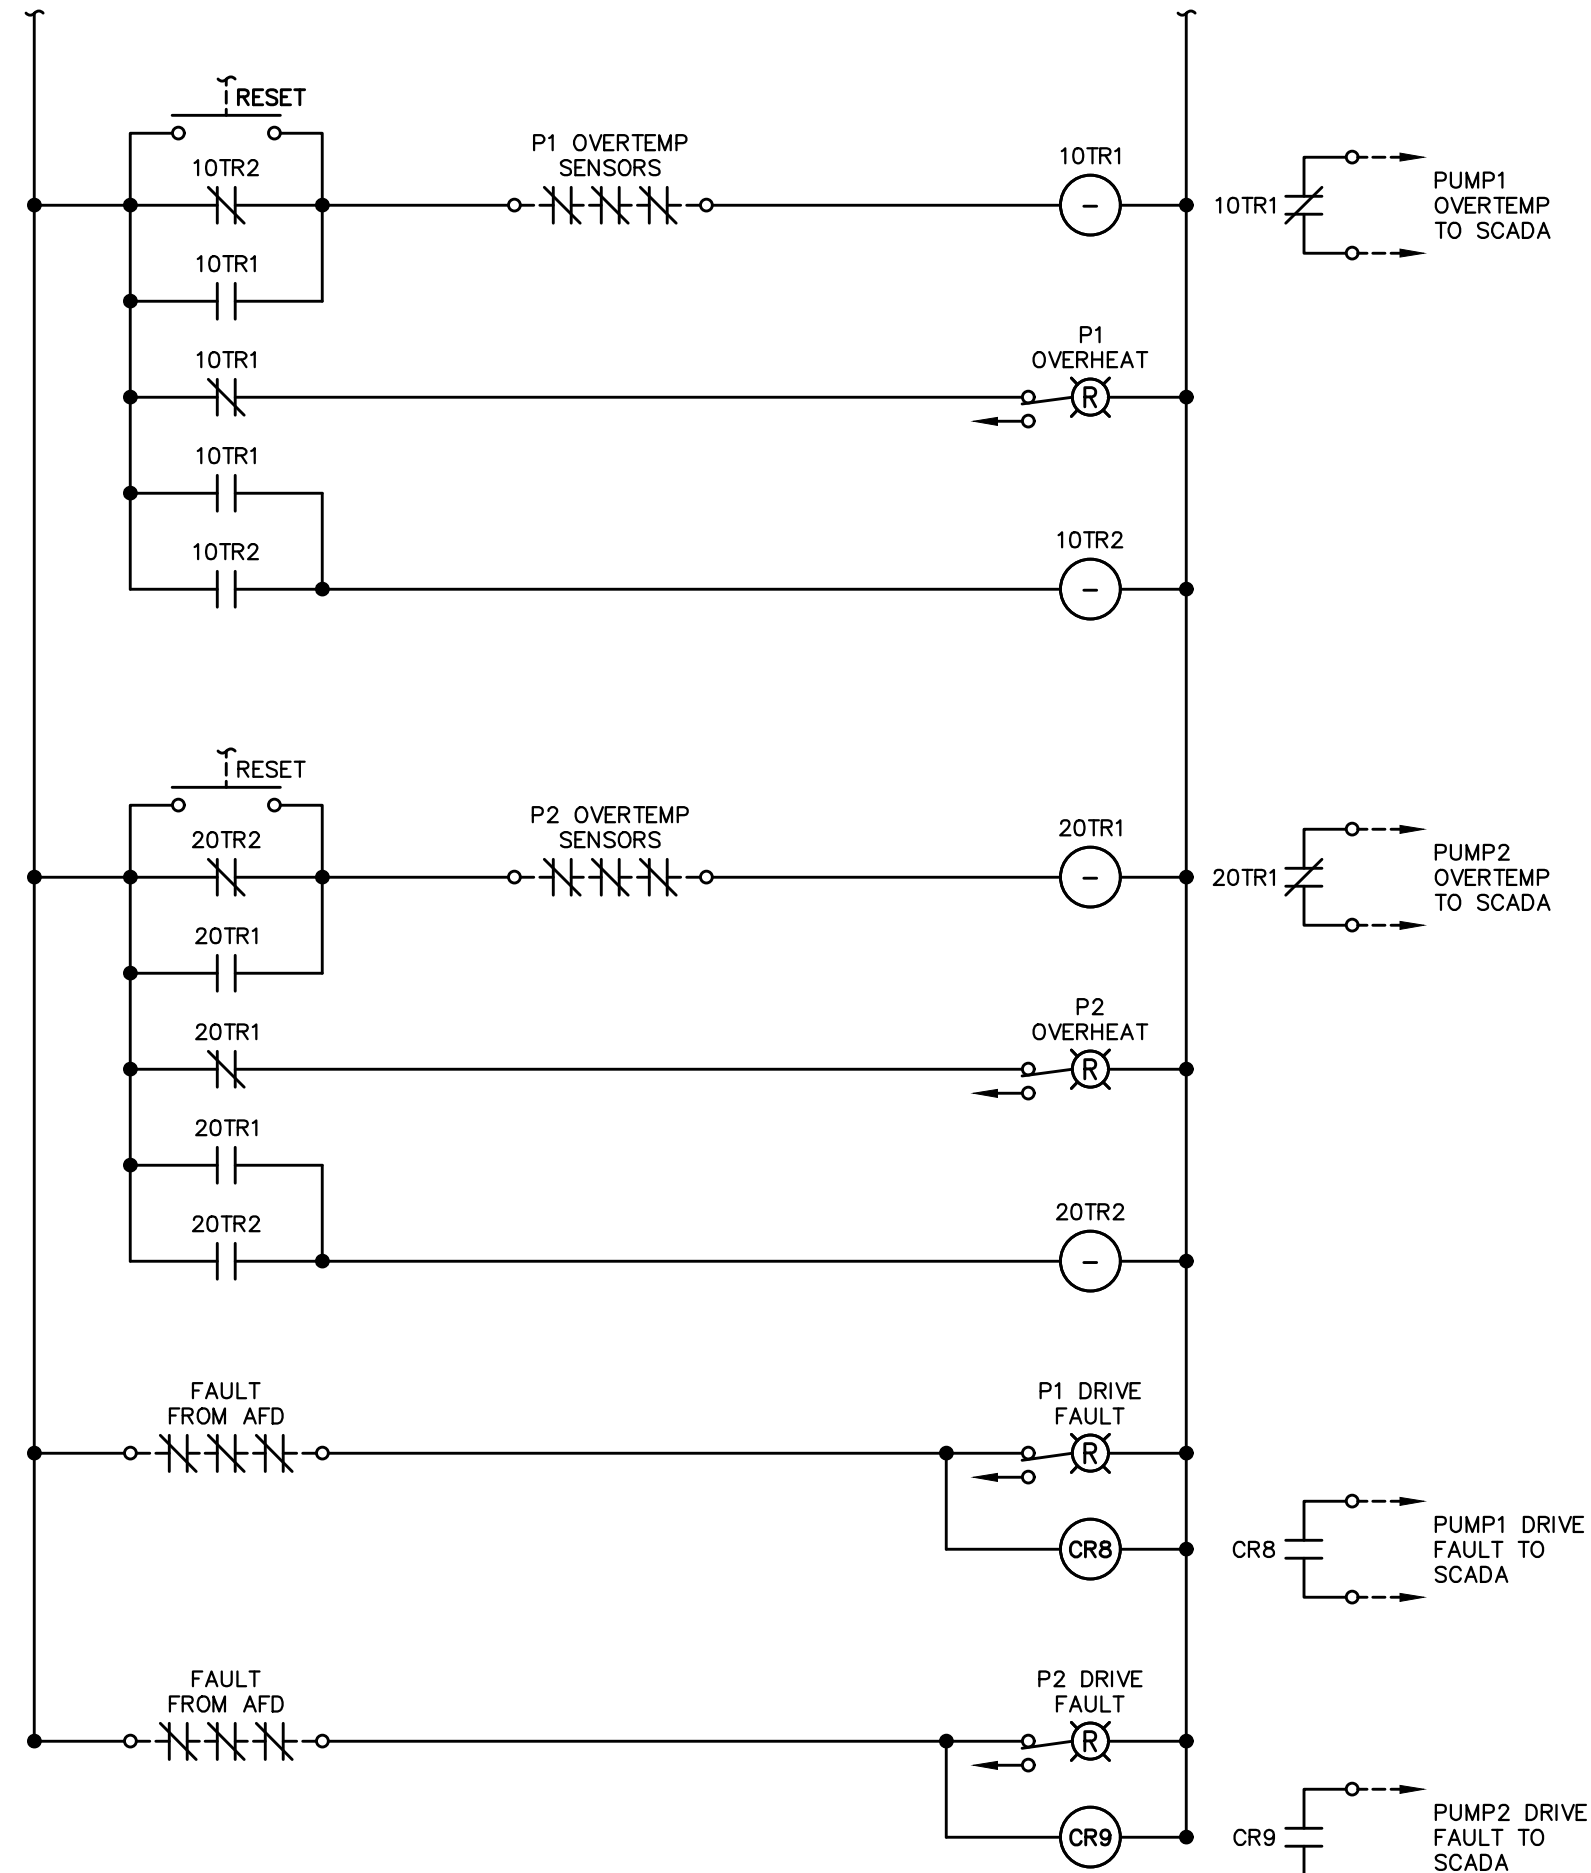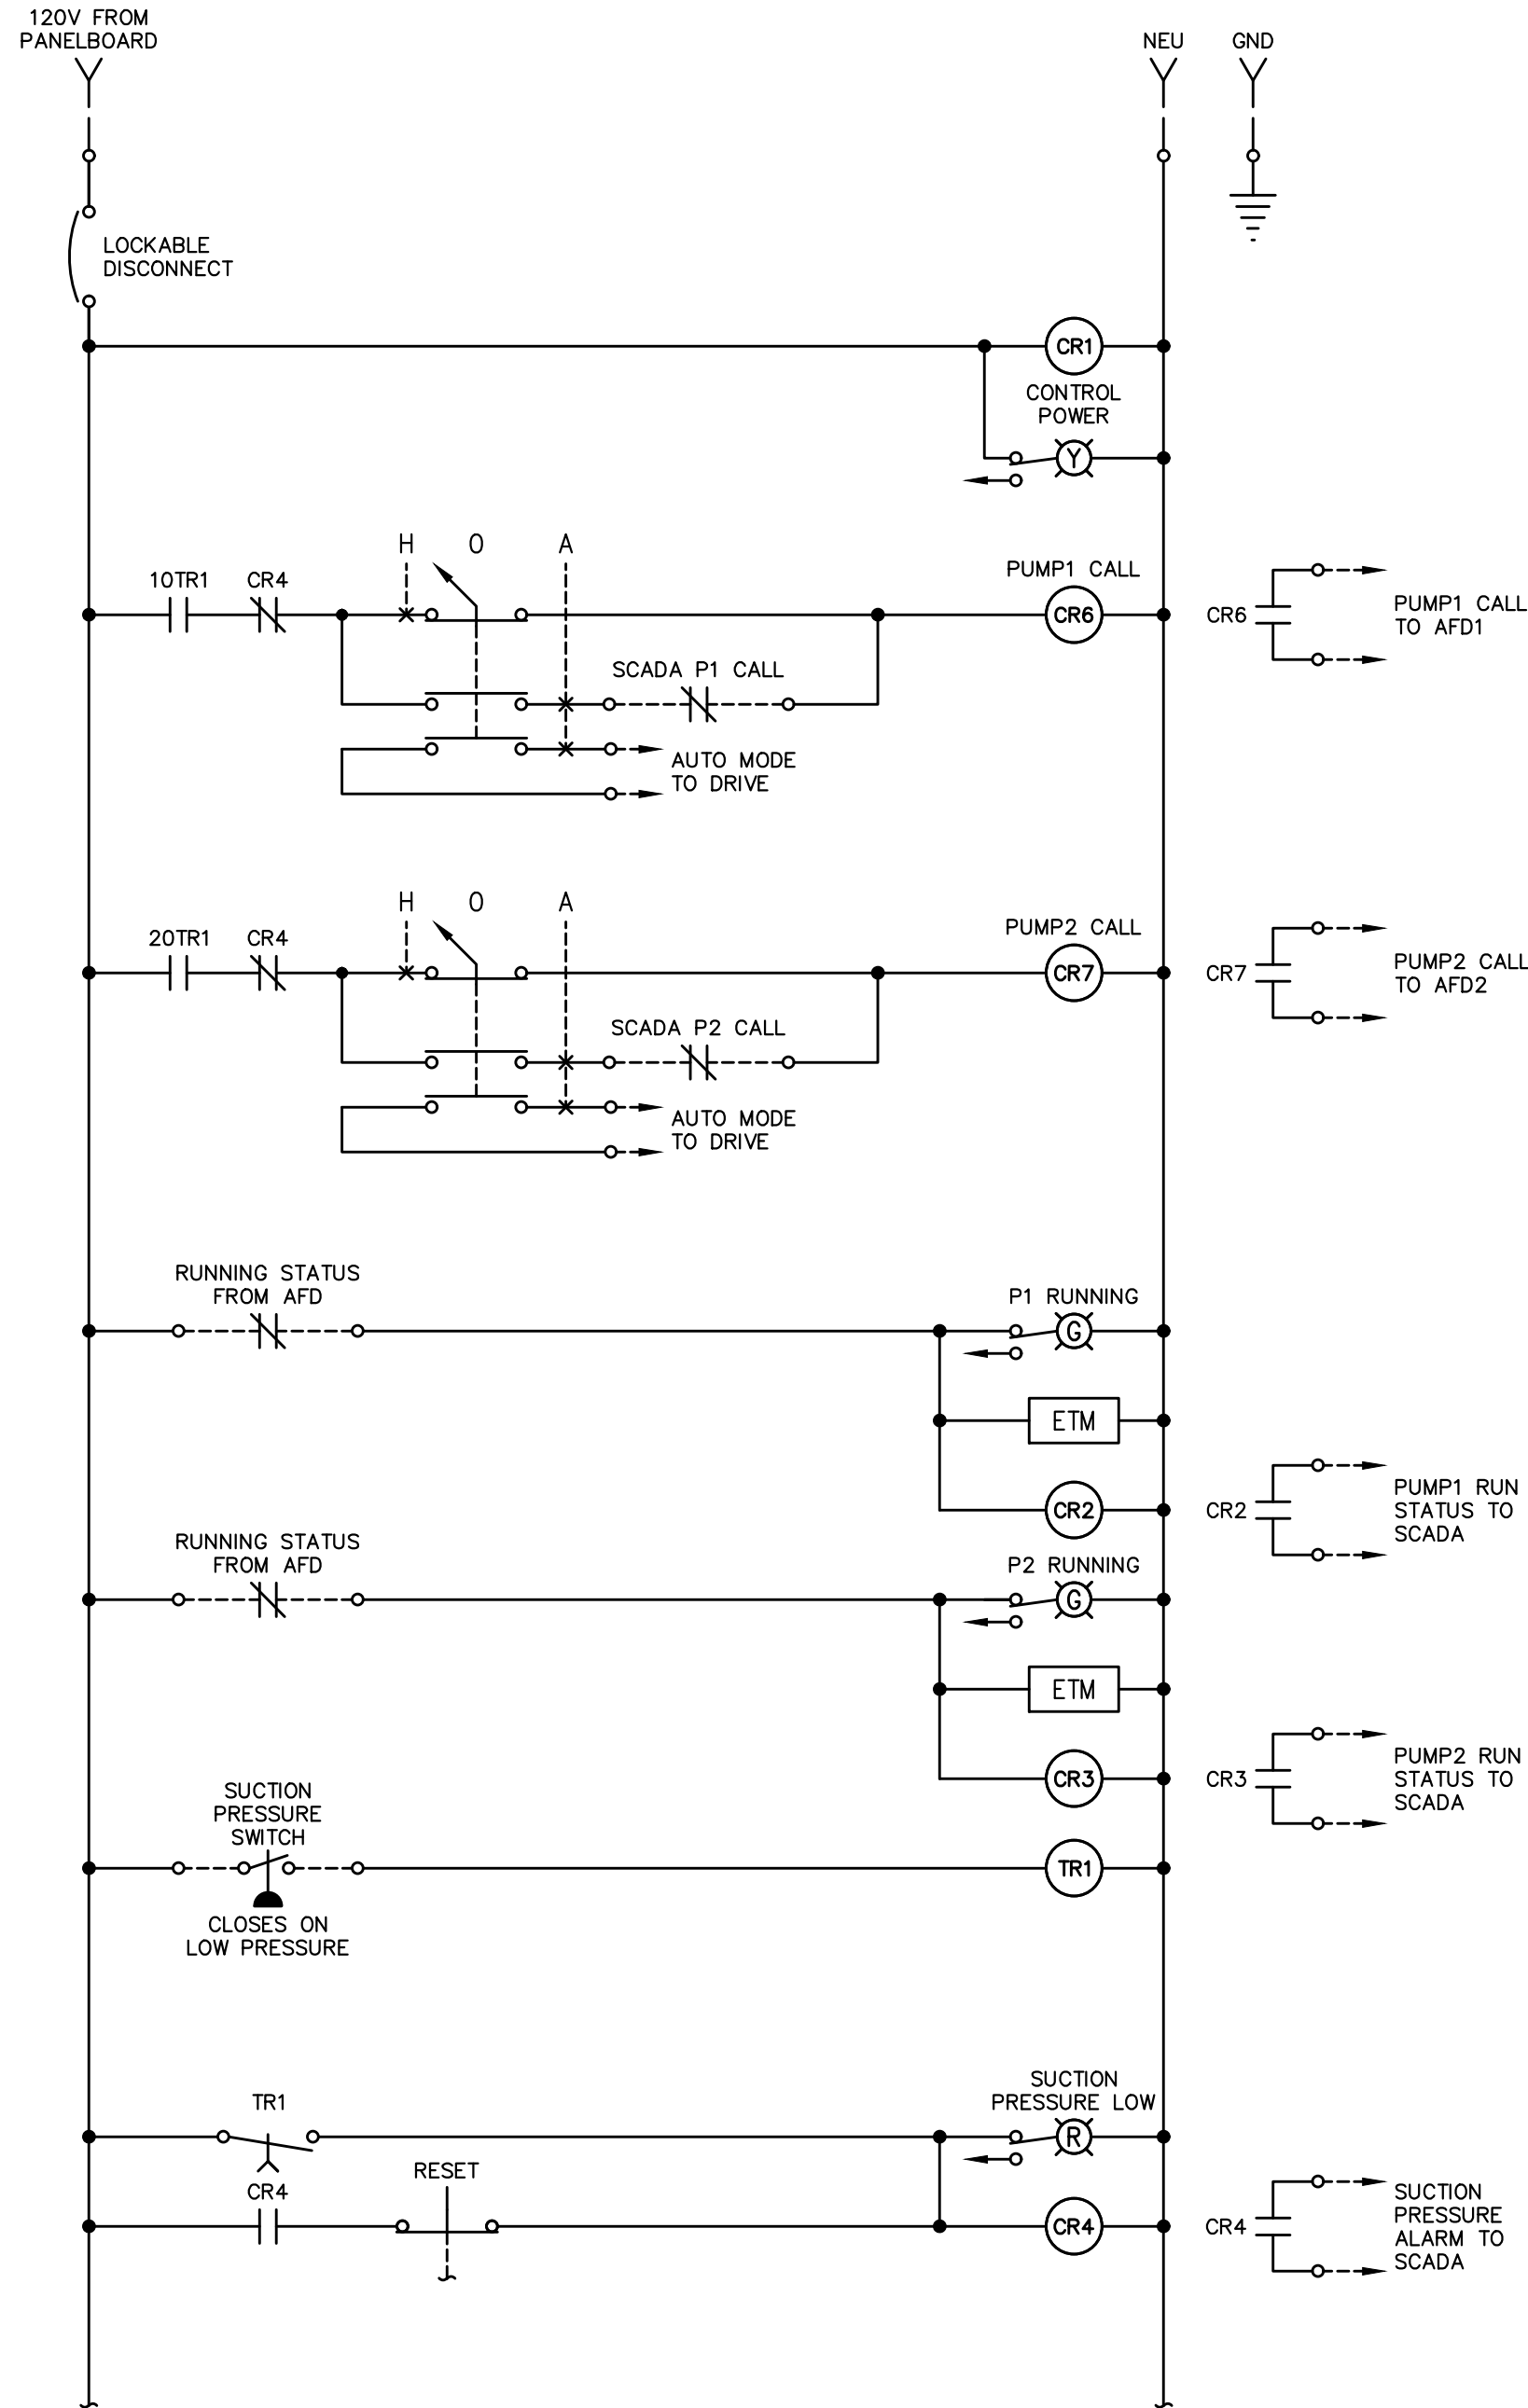


- IN HAND MODE, SPEED SHALL BE SET FROM DRIVE INTERFACE MODULE. IN AUTO MODE, SPEED SHALL BE SET IN PRESET FREQUENCY PARAMETER.
- DRIVES SHALL BE WALL-MOUNTED SEPARATE FROM PANEL AS INDICATED ON PLANS.
- PANEL TO INCLUDE SPARE SPACE AND TERMINALS TO EXPAND TO 3 PUMP CONTROL PANEL.
- PUMPS RUN ALTERNATING BASED ON TIME.

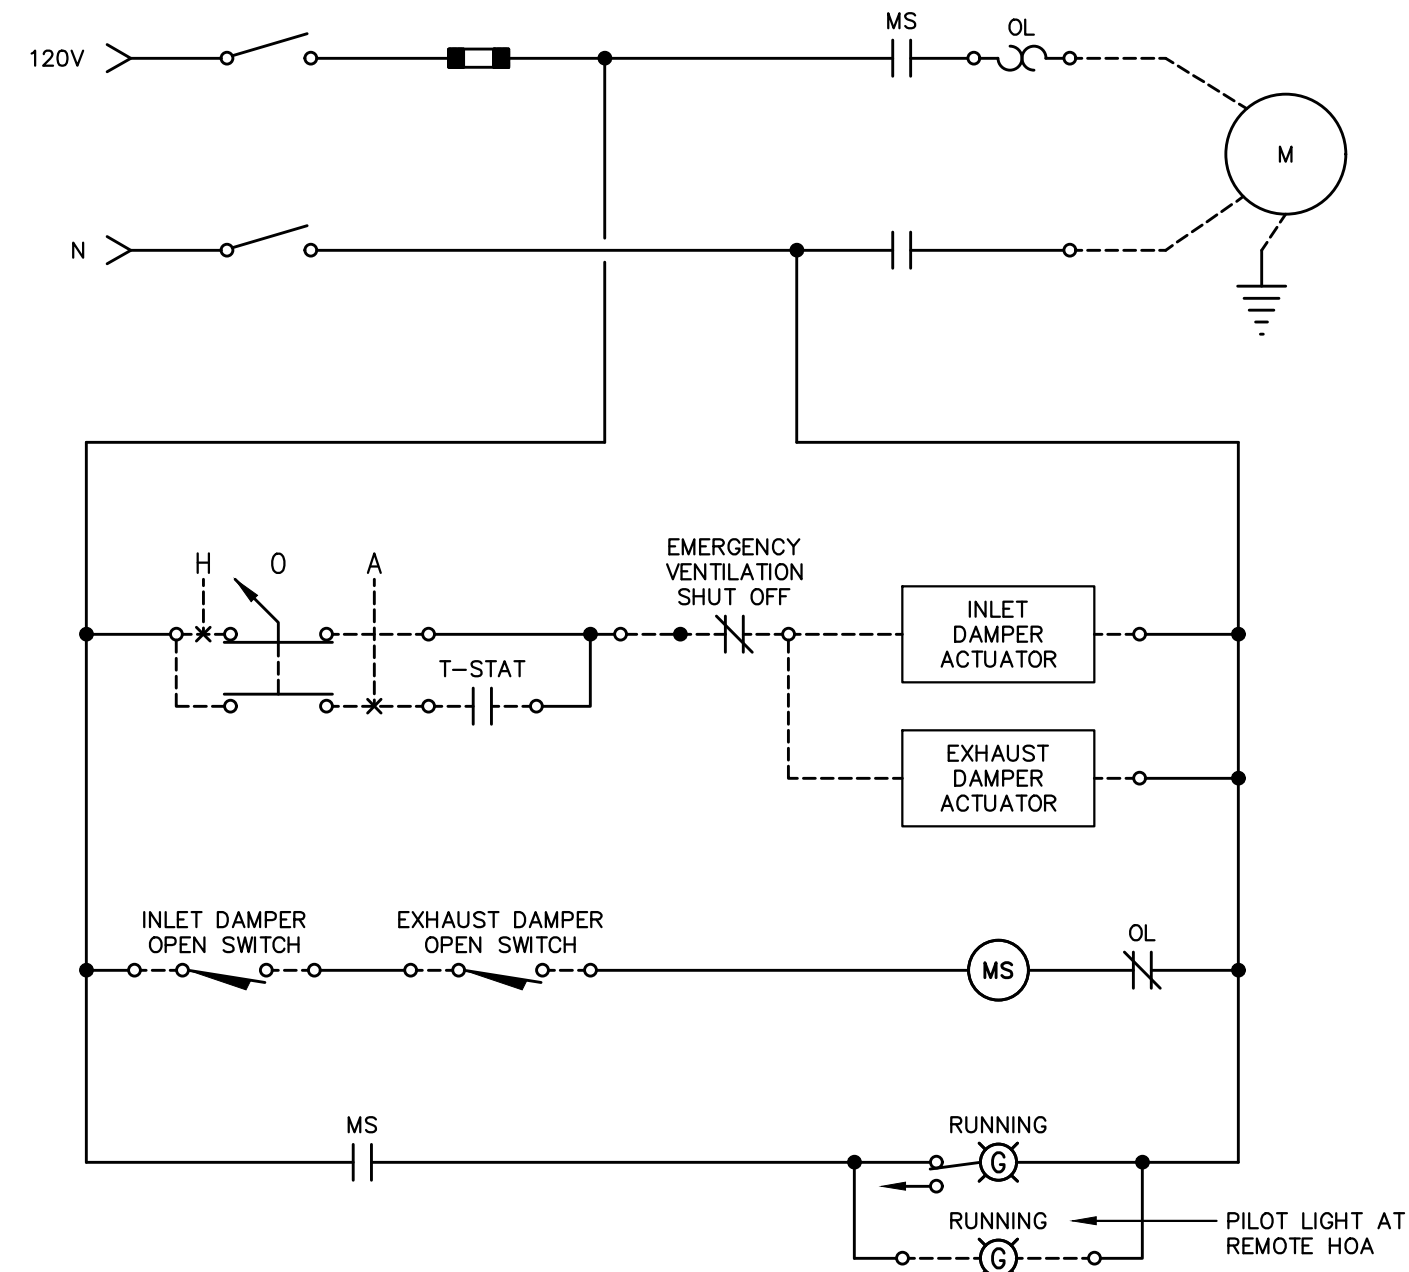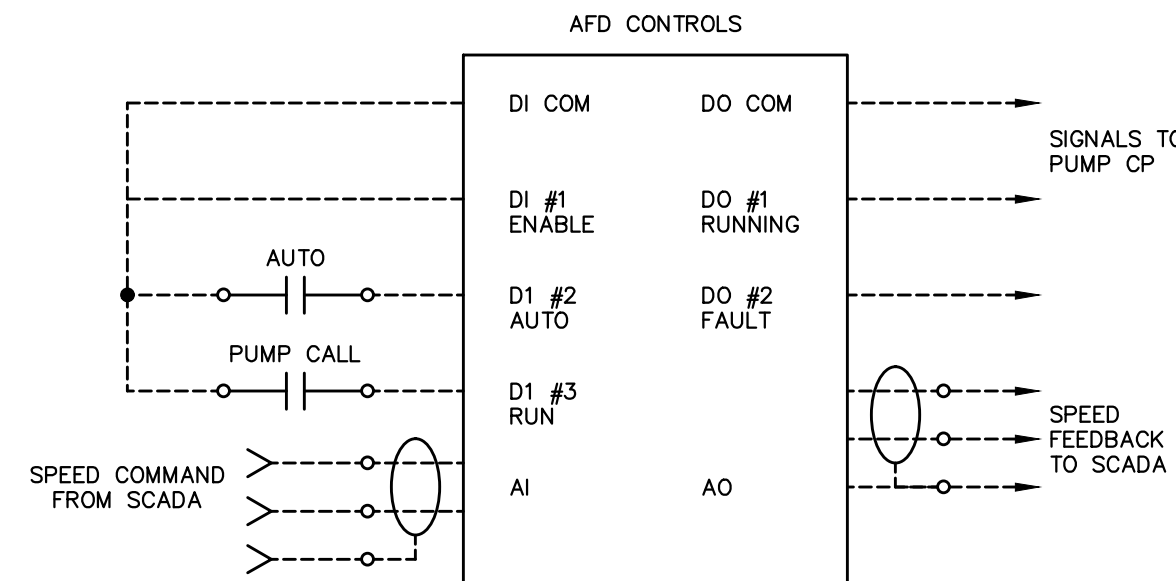


EXHAUST FAN/LOUVER
CONTROL CIRCUIT WITH REMOTE HOA SWITCH
NOT TO SCALE



DESIGNER	LBA	DATE	BY	REVISION
DRAWN	TEW			
CHECKED	LBA			
APPROVED	LBA			

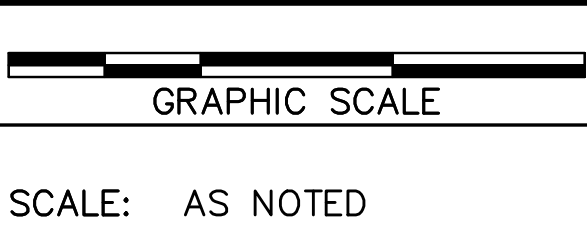

ALL RIGHTS RESERVED
THIS DOCUMENT IS THE PROPERTY OF BELL ENGINEERING AND SHALL NOT BE REPRODUCED IN WHOLE OR IN PART OR USED FOR CONSTRUCTION OF OTHER THAN THIS SPECIFIC PROJECT WITHOUT THE WRITTEN PERMISSION OF BELL ENGINEERING. FACSIMILES OF LICENSED PROFESSIONAL ENGINEER AND/OR LAND SURVEYOR SEALS, IF AFFIXED TO THIS DOCUMENT, SHALL BE CONSIDERED LEGITIMATE ONLY IF SIGNED AND DATED BY THE REGISTRANT.

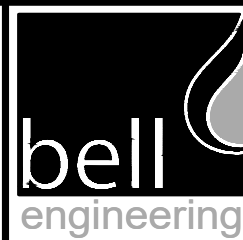


Lexington, KY (859) 278-5412
Hopkinsville, KY (270) 886-5466
Somerset, KY (606) 485-4011


WATER SYSTEM IMPROVEMENTS
SHOPES CREEK ROAD AREA
CANNONBURG WATER DISTRICT
CANNONBURG, KENTUCKY

ELECTRICAL WIRING DIAGRAMS


DIVISION	-
CONTRACT NO.	691-21-01
DATE	SEPTEMBER 2021
SHEET NO.	E06 OF E07

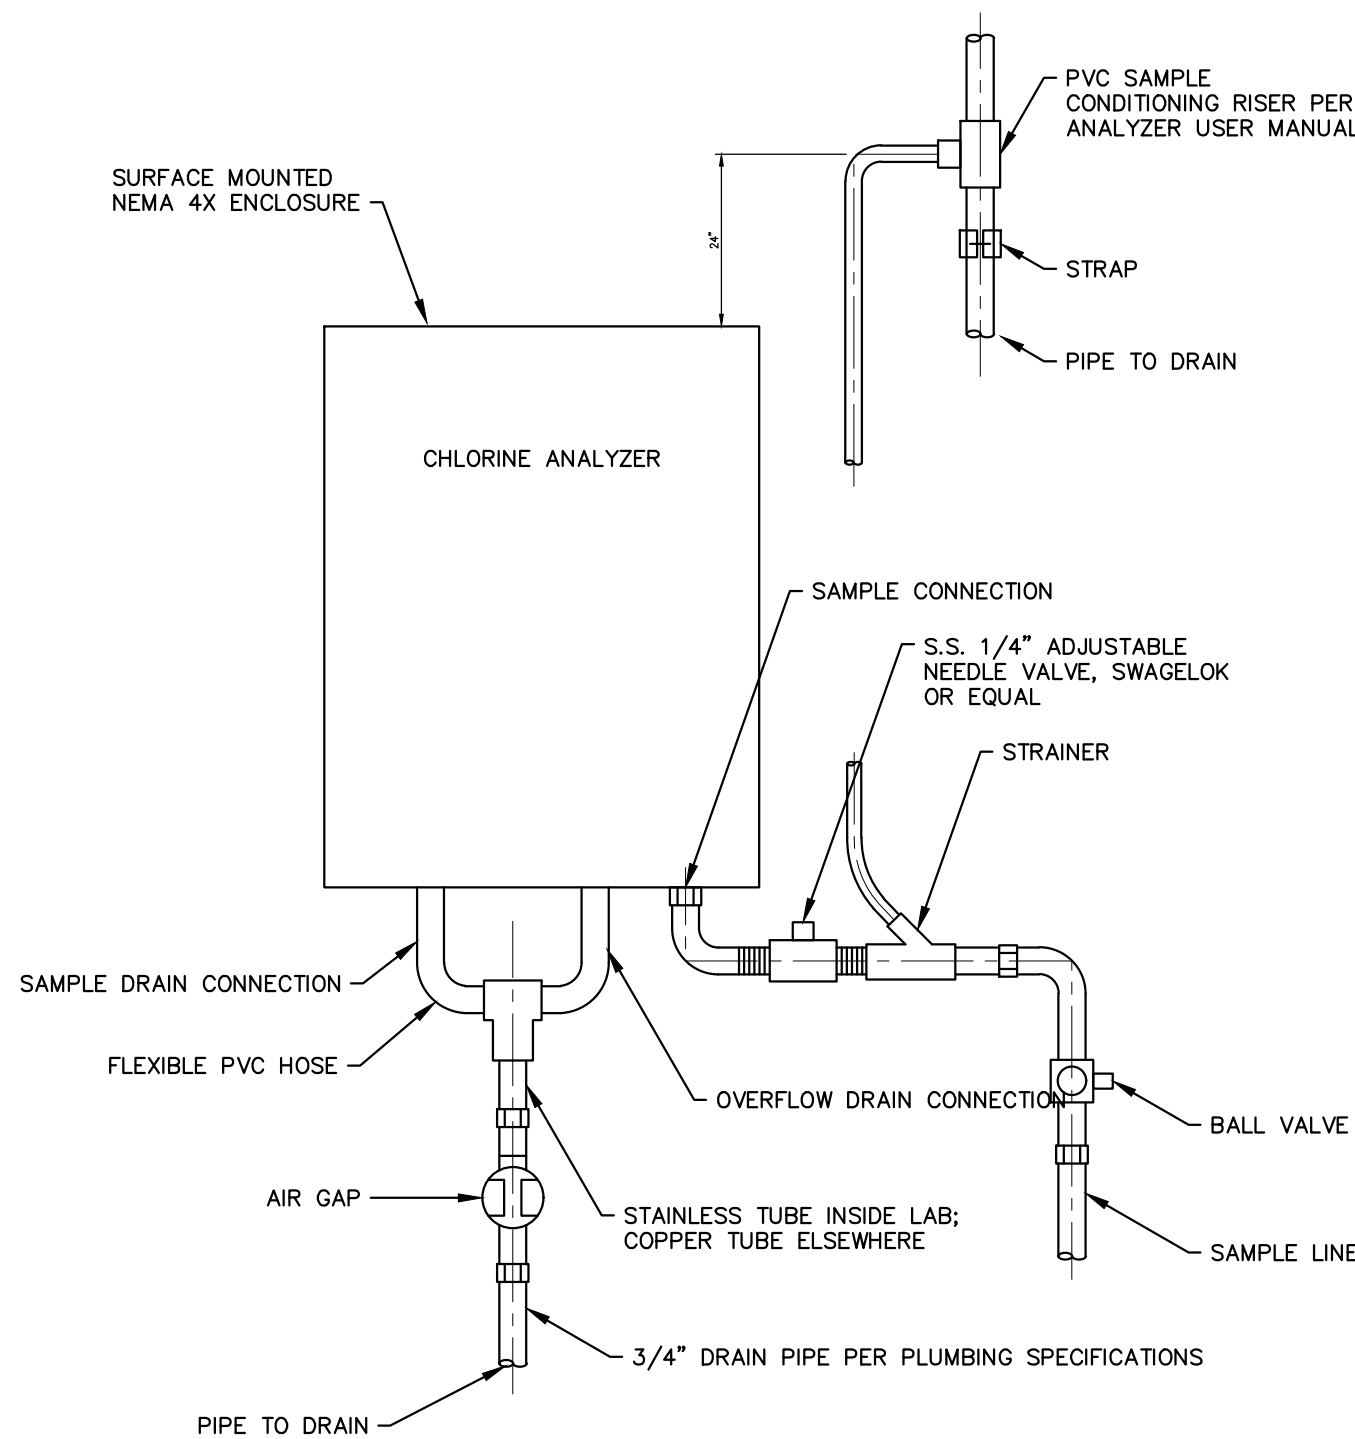


CHLORINE ANALYZER DETAIL
NOT TO SCALE
NOTE: ALL FITTINGS SHALL BE STAINLESS STEEL WHERE AVAILABLE.

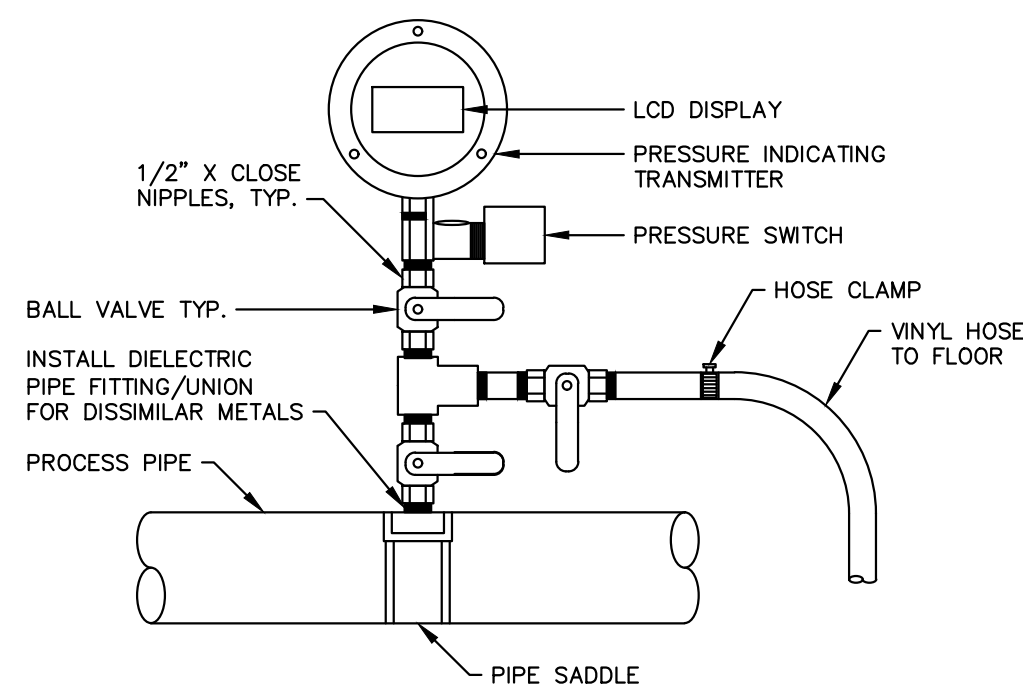

PRESSURE SWITCH PIPING DETAIL
NOT TO SCALE

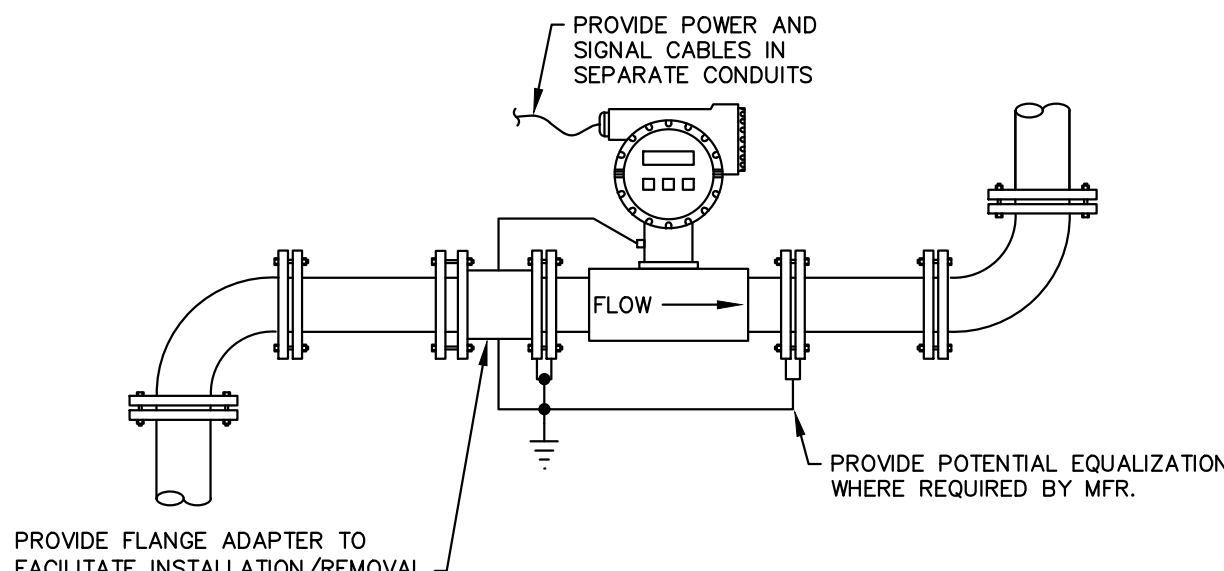

MAGMETER INSTALLATION DETAIL
NOT TO SCALE

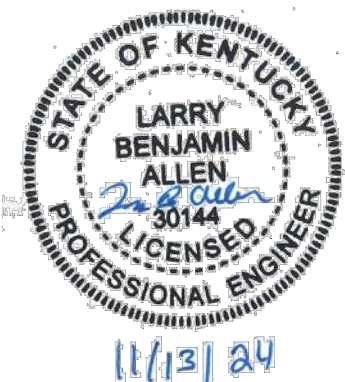


11/13/24

DESIGNER	LBA	DATE	BY	REVISION
DRAWN	TEW			
CHECKED	LBA			
APPROVED	LBA			

GRAPHIC SCALE
SCALE: AS NOTED

ALL RIGHTS RESERVED
THIS DOCUMENT IS THE PROPERTY OF BELL ENGINEERING AND SHALL NOT BE REPRODUCED IN WHOLE OR IN PART OR USED FOR CONSTRUCTION OF OTHER THAN THIS SPECIFIC PROJECT WITHOUT THE WRITTEN PERMISSION OF BELL ENGINEERING. FACSIMILES OF LICENSED PROFESSIONAL ENGINEER AND/OR LAND SURVEYOR SEALS, IF AFFIXED TO THIS DOCUMENT, SHALL BE CONSIDERED LEGITIMATE ONLY IF SIGNED AND DATED BY THE REGISTRANT.

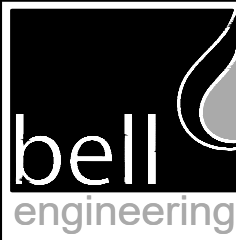


Lexington, KY (859) 278-5412
Hopkinsville, KY (270) 886-5466
Somerset, KY (606) 485-4011

WATER SYSTEM IMPROVEMENTS
SHOPE'S CREEK ROAD AREA
CANNONSBURG WATER DISTRICT
CANNONSBURG, KENTUCKY

INSTRUMENTATION DETAILS

DIVISION	-
CONTRACT NO.	691-21-01
DATE	SEPTEMBER 2021
SHEET NO.	E07 OF E07

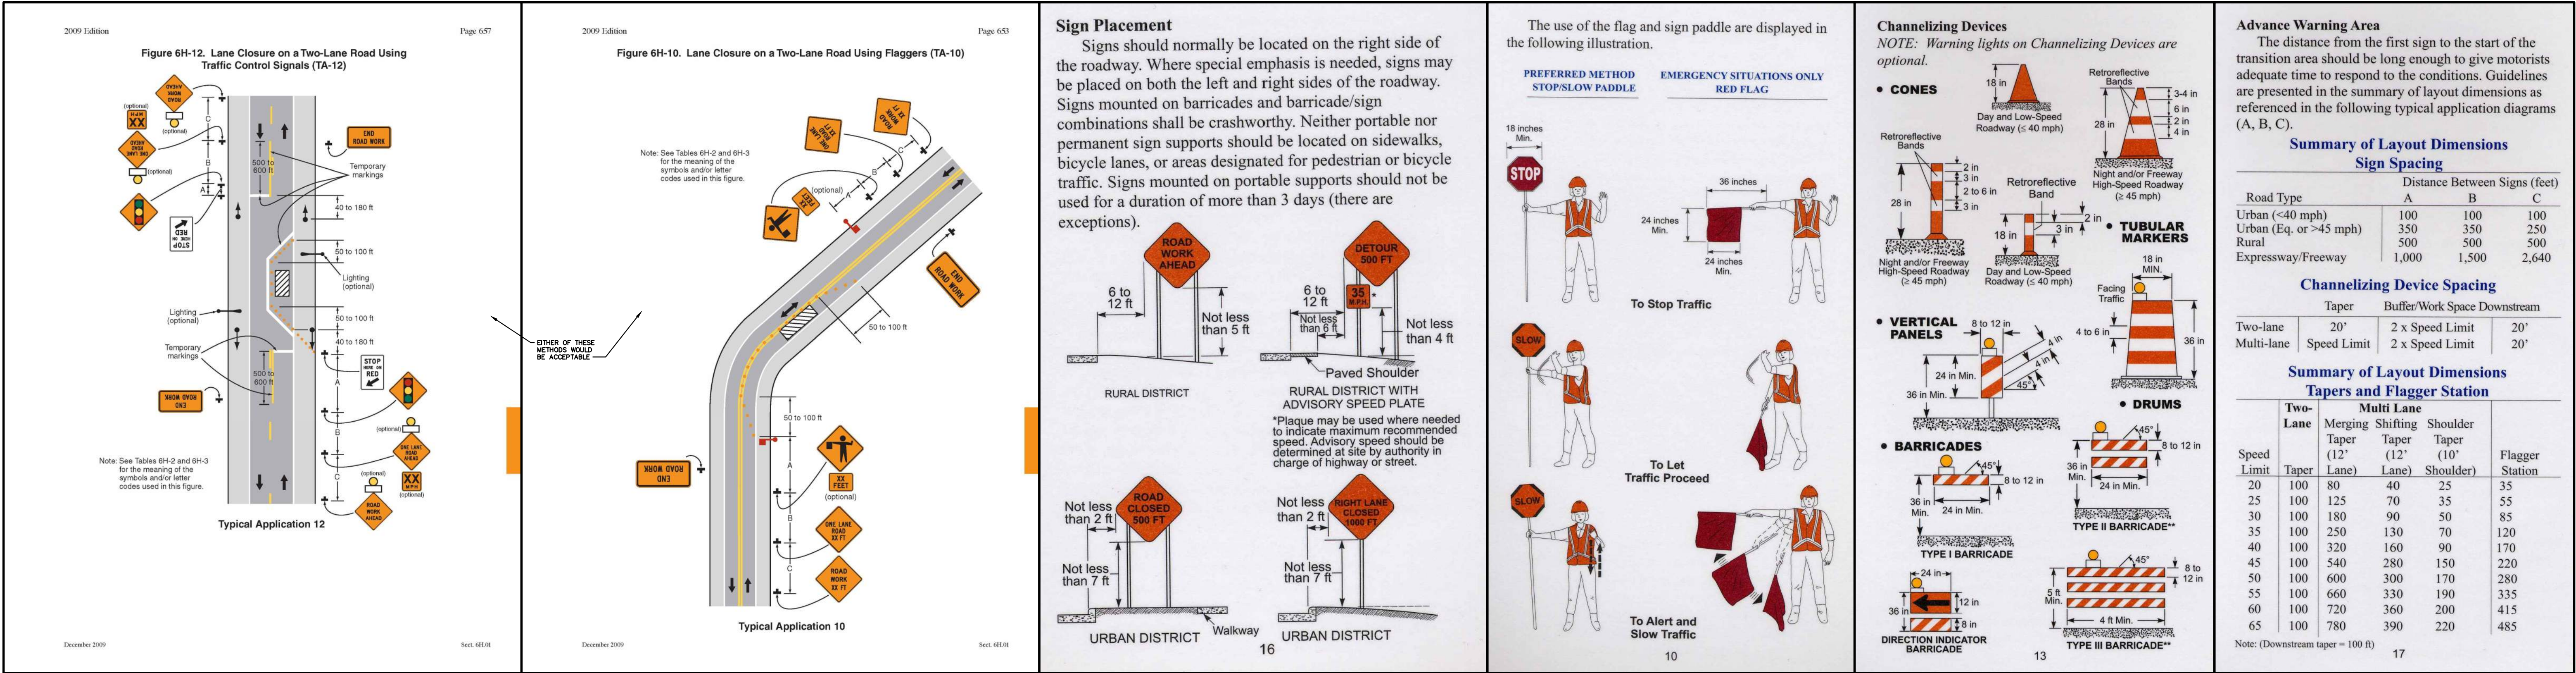


112.03.01 GENERAL TRAFFIC CONTROL


MAINTAIN THE PORTION OF THE PROJECT USED BY PUBLIC TRAFFIC, AND ADEQUATELY ACCOMMODATE THROUGH AND LOCAL TRAFFIC. THE DEPARTMENT'S INTENT IS FOR THE TRAFFIC CONTROL PLAN AND DEVICES TO PROVIDE THE PUBLIC A SAFE AND MANAGEABLE ROADWAY. IN THE EVENT THE CONTRACTOR FEELS ADDITIONAL MEASURES ARE NECESSARY TO PROTECT THE WORK, THESE CHANGES SHALL BE DISCUSSED WITH THE ENGINEER AND IF AGREED UPON WILL BE PAID AT CONTRACT BID PRICES OR ADDED BY SUPPLEMENTAL AGREEMENT. THE DEPARTMENT WILL BE RESPONSIBLE FOR NORMAL ROUTINE MAINTENANCE ACCORDING TO SUBSECTION 105.11. FURNISH, ERECT, AND MAINTAIN ALL TRAFFIC CONTROL DEVICES, INCLUDING SIGNS, SIGNALS, CHANNELIZATION DEVICES, TEMPORARY PAVEMENT MARKINGS, PILOT CARS AND OTHER ITEMS NECESSARY TO MAINTAIN TRAFFIC ACCORDING TO THE STANDARD DRAWINGS, MUTCD, PLANS, TCP, AND THE ATSSA "QUALITY STANDARD FOR WORK ZONE TRAFFIC CONTROL DEVICES" MANUAL THROUGHOUT THE DURATION OF THE PROJECT.

WORK ZONE TRAFFIC CONTROL (DIST. 9)

PRIOR TO BEGINNING OF WORK ON KENTUCKY TRANSPORTATION RIGHTS-OF-WAY THE CONTRACTOR SHALL HAVE COMPLETED THE KENTUCKY TRANSPORTATION CABINET'S WORK ZONE TRAFFIC CONTROL EMPLOYEE QUALIFICATION PROGRAM. INDIVIDUALS PERFORMING FLAGGING OPERATIONS ON ANY KENTUCKY ROADWAY MUST BE QUALIFIED AND CERTIFIED BY THE KENTUCKY TRANSPORTATION CABINET. INDIVIDUALS WHO PLACE, MONITOR, AND MAINTAIN TRAFFIC CONTROL DEVICES ON PUBLIC ROADWAYS IN KENTUCKY SHALL HAVE SUCCESSFULLY COMPLETED THE WORK ZONE TRAFFIC CONTROL TECHNICIAN PROGRAM. THE CONTRACTOR SHALL ALSO BE RESPONSIBLE FOR PREPARING AND IMPLEMENTING THE TRAFFIC CONTROL PLAN, THE INDIVIDUALS RESPONSIBLE FOR THIS WORK SHALL HAVE SUCCESSFULLY COMPLETED THE WORK ZONE TRAFFIC CONTROL SUPERVISOR PROGRAM. FOR MORE INFORMATION ON THE WORK ZONE TRAFFIC CONTROL EMPLOYEE QUALIFICATION PROGRAM AS PRESENTED BY THE TECHNOLOGY TRANSFER PROGRAM, KENTUCKY TRANSPORTATION CENTER, UNIVERSITY OF KENTUCKY CALL THE CENTER'S TOLL FREE NUMBER 1-800-432-0719 OR CONTACT THE DEPARTMENT OF HIGHWAYS, DISTRICT 9, 822 ELIZAVILLE, FLEMINGSBURG KENTUCKY 41041, PHONE 606-854-2551.

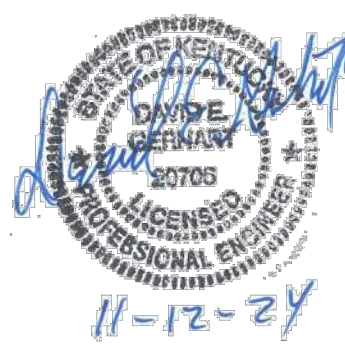

DESIGNER	DEG	DATE	BY	REVISION
DRAWN	TEW			
CHECKED	DEG			
APPROVED	DEG			

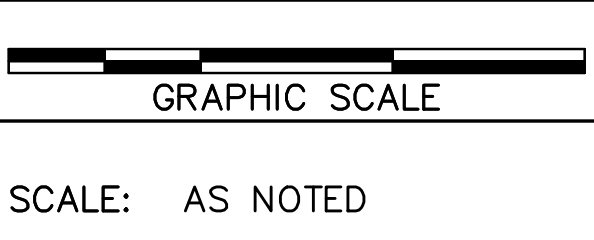

ALL RIGHTS RESERVED

THIS DOCUMENT IS THE PROPERTY OF BELL ENGINEERING AND SHALL NOT BE REPRODUCED IN WHOLE OR IN PART OR USED FOR CONSTRUCTION OF OTHER THAN THIS SPECIFIC PROJECT WITHOUT THE WRITTEN PERMISSION OF BELL ENGINEERING. FACSIMILES OF LICENSED PROFESSIONAL ENGINEER AND/OR LAND SURVEYOR SEALS, IF AFFIXED TO THIS DOCUMENT, SHALL BE CONSIDERED LEGITIMATE ONLY IF SIGNED AND DATED BY THE REGISTRANT.

Lexington, KY (859) 278-5412
Hopkinsville, KY (270) 886-5466
Somerset, KY (606) 485-4011

WATER SYSTEM IMPROVEMENTS
SHOPES CREEK ROAD AREA
CANNONBURG WATER DISTRICT
CANNONBURG, KENTUCKY

TRAFFIC CONTROL PLAN

DIVISION	—
CONTRACT NO.	691-21-01
DATE	SEPTEMBER 2021
SHEET NO.	TC-1 OF TC-1